



FM 3549  
CIP-WT2016-001

|      |                           |                                                |              |              |                      |
|------|---------------------------|------------------------------------------------|--------------|--------------|----------------------|
|      |                           |                                                |              |              |                      |
|      |                           |                                                |              |              |                      |
|      |                           |                                                |              |              |                      |
|      |                           |                                                |              |              |                      |
|      |                           |                                                |              |              |                      |
|      |                           |                                                |              |              |                      |
| REV. | CITY REVISION DESCRIPTION | AFFECTED SHEETS<br>REV. (R) ADD. (A) VOID. (V) | REV.<br>REV. | REV.<br>DATE | APPROVED BY THE CITY |



Jan 02, 2018 - 5:06p - nls2008 - K:\Projects\Atkins\100049910-Rockwall\2.0 Drawings\Sheet\A - RW-WL-GN01.dwg

GENERAL

1.

ALL WORK SHALL BE DONE IN ACCORDANCE WITH THE STANDARD SPECIFICATIONS OF THE CITY OF ROCKWALL, WHICH ADOPTED THE STANDARD SPECIFICATIONS FOR PUBLIC WORKS CONSTRUCTION, 4RD EDITION, NORTH CENTRAL TEXAS, (COG), WITH CITY AMENDMENTS. COPIES MAY BE OBTAINED FROM THE "NORTH CENTRAL TEXAS COUNCIL OF GOVERNMENTS",616 SIX FLAGS DR., P.O. BOX 5888, ARLINGTON, TEXAS 76005-5888. PH (817) 640-3300.
2.

THESE PLANS, PREPARED BY ATKINS, DO NOT EXTEND TO OR INCLUDE DESIGNS OR SYSTEMS PERTAINING TO THE SAFETY OF THE CONSTRUCTION CONTRACTOR OR ITS EMPLOYEES, AGENTS, OR REPRESENTATIVES IN THE PERFORMANCE OF THE WORK. THE SEAL(S) OF ATKINS REGISTERED PROFESSIONAL ENGINEER(S) HEREON DOES NOT EXTEND TO ANY SUCH SAFETY SYSTEMS THAT MAY NOW OR HEREAFTER BE INCORPORATED IN THE WORK. THE CONSTRUCTION CONTRACTOR IS TO PREPARE OR OBTAIN THE APPROPRIATE SAFETY SYSTEMS, INCLUDING THE PLANS AND SPECIFICATIONS.
3.

THE CONTRACTOR SHALL ABIDE BY ALL APPLICABLE LOCAL, STATE, AND FEDERAL LAWS GOVERNING EXCAVATION. TRENCH SIDE SLOPES SHALL MEET OCCUPATIONAL SAFETY AND HEALTH ADMINISTRATION (OSHA) STANDARDS THAT ARE IN EFFECT AT THE TIME OF CONSTRUCTION. SHEETING, SHORING, AND BRACING WILL BE REQUIRED WHEN SIDE SLOPE STANDARDS ARE NOT MET. A TRENCH PULL BOX, MEETING OSHA STANDARDS, WILL BE ACCEPTABLE. THE APPARENT LOW BIDDER WILL SUBMIT DETAILED PLANS AND SPECIFICATIONS FOR TRENCH SAFETY SYSTEMS WHEN TRENCH EXCAVATION WILL EXCEED A DEPTH OF FIVE (5) FEET THAT MEET OSHA STANDARDS THAT ARE IN EFFECT AT THE TIME OF CONSTRUCTION.
4.

ALL CONSTRUCTION OPERATIONS ARE TO BE ACCOMPLISHED IN ACCORDANCE WITH APPLICABLE REGULATIONS OF THE OSHA. COPIES OF OSHA STANDARDS MAY BE PURCHASED FROM THE U.S. GOVERNMENT PRINTING OFFICE; INFORMATION AND RELATED REFERENCE MATERIALS MAY BE OBTAINED FROM OSHA, 903 SAN JACINTO, AUSTIN, TEXAS 78701.
5.

THE CONTRACTOR SHALL OBTAIN ALL CONSTRUCTION PERMITS REQUIRED FROM THE CITY OF ROCKWALL PRIOR TO COMMENCEMENT OF WORK.
6.

THE CITY OF ROCKWALL (972-771-7746) AND TXDOT (972-962-3617) ARE TO BE NOTIFIED BY TELEPHONE AT LEAST 48 HOURS IN ADVANCE OF ALL CONSTRUCTION, FOLLOWED BY A LETTER OF CONFIRMATION, TO THE CITY.
7.

THE CONTRACTOR SHALL GIVE NOTICE TO ALL AUTHORIZED INSPECTORS, SUPERINTENDENTS, OR PERSONS IN CHARGE OF PRIVATE AND PUBLIC UTILITIES AFFECTED BY THESE OPERATIONS PRIOR TO COMMENCEMENT OF WORK.
8.

THE CONTRACTOR SHALL VERIFY ALL CONDITIONS AND DIMENSIONS AT THE JOB SITE AND NOTIFY THE OWNER'S REPRESENTATIVE OF ANY OMISSIONS, DISCREPANCIES, OR DIMENSIONAL ERRORS PRIOR TO BEGINNING OR FABRICATING ANY WORK OR MATERIALS. OTHERWISE THE CORRECTIONS (AND ASSOCIATED COST) WILL BE THE RESPONSIBILITY OF THE CONTRACTOR.
9.

THE CONTRACTOR IS TO TAKE ALL DUE PRECAUTIONS TO PROTECT EXISTING FACILITIES FROM DAMAGE. ANY DAMAGE TO EXISTING FACILITIES INCURRED AS A RESULT OF THESE CONSTRUCTION OPERATIONS ARE TO BE REPAIRED IMMEDIATELY BY THE CONTRACTOR TO AT LEAST THE PRE-EXISTING CONDITION AT THE CONTRACTOR'S EXPENSE.
10.

THE CONTRACTOR SHALL BE RESPONSIBLE FOR REPAIRING ANY DAMAGE CAUSED BY THESE CONSTRUCTION OPERATIONS OUTSIDE THE DESIGNATED WORK AREA WITH EQUAL OR BETTER QUALITY MATERIAL AT THE CONTRACTOR'S EXPENSE.
11.

ALL EXISTING MONUMENTS, PROPERTY PINS, OR IRON RODS SHALL BE PRESERVED BY THE CONTRACTOR. IF ANY OF THESE ITEMS NEEDS TO BE REMOVED OR DISRUPTED TO ACCOMMODATE CONSTRUCTION, THE CONTRACTOR SHALL BE FULLY RESPONSIBLE FOR REPLACING IT BACK TO ITS ORIGINAL LOCATION AND/OR ELEVATION AT THE CONTRACTOR'S EXPENSE.
12.

NO TREES SHALL BE CUT OR REMOVED EXCEPT ON SPECIFIC APPROVAL BY THE CITY OF ROCKWALL. ANY TREES THAT ARE APPROVED FOR REMOVAL MUST BE REMOVED IN A MANNER WHICH DOES NOT IMPACT TREES THAT ARE TO BE PRESERVED.
13.

THE CONTRACTOR IS RESPONSIBLE FOR THE REMOVAL AND DISPOSAL OF STUMPS, ROOTS, AND VEGETATION FROM THE PROJECT SITE.

14.

ALL TREES, BUSHES, AND BRUSH THAT MUST BE REMOVED IN ORDER TO PROCEED WITH CONSTRUCTION SHALL BE CONSIDERED INCIDENTAL TO CONSTRUCTION AND NOT MEASURED SEPARATELY FOR PAYMENT.
15.

VEGETATION MUST BE PRUNED TO PROVIDE CLEARANCE FOR STRUCTURES, VEHICULAR TRAFFIC, AND EQUIPMENT BEFORE DAMAGE OCCURS (RIPPING OF BRANCHES, ETC.). ALL FINISHED PRUNING IS TO BE DONE ACCORDING TO RECOGNIZED, APPROVED STANDARDS OF THE INDUSTRY (REFER TO THE "NATIONAL ARBORIST ASSOCIATION PRUNING STANDARDS FOR SHADE TREES").
16.

THE CONTRACTOR IS TO COMPLY WITH ALL APPLICABLE LOCAL, STATE, AND FEDERAL REQUIREMENTS REGARDING EXCESS AND WASTE MATERIAL, INCLUDING METHODS OF HANDLING AND DISPOSAL.
17.

THE LOCATION FOR THE DISPOSAL OF CONSTRUCTION MATERIAL SHALL BE APPROVED BY THE CITY OF ROCKWALL DEPARTMENT OF ENGINEERING AND PUBLIC WORKS PRIOR TO THE START OF CONSTRUCTION.
18.

MATERIAL MAY NOT BE STOCKPILED WITHIN THE 100-YEAR FLOODPLAIN.
19.

INTENTIONAL RELEASE OF VEHICLE OR EQUIPMENT FLUIDS ONTO THE GROUND IS NOT ALLOWED. CONTAMINATED SOIL RESULTING FROM AN ACCIDENTAL SPILL IS TO BE REMOVED AND DISPOSED OF PROPERLY AT THE CONTRACTOR'S EXPENSE.

CONSTRUCTION

1.

THE CONTRACTOR SHALL NOTIFY THE CITY OF ROCKWALL DEPARTMENT OF ENGINEERING (972-771-7746)AND PUBLIC WORKS BY TELEPHONE (972-771-7730) AT LEAST 48 HOURS IN ADVANCE FOR ALL WATER OR WASTEWATER MODIFICATIONS,LOCATES, OR TUNOFFS.
2.

ONLY THE CITY OF ROCKWALL WATER DEPARTMENT SHALL OPERATE EXISTING WATER VALVES. CONTACT THE WATER DEPARTMENT AT 972-771-7730 FOR ASSISTANCE AT LEAST 24 HOURS IN ADVANCE (EXCEPT IN THE CASE OF AN EMERGENCY).
3.

FIELD ADJUSTMENTS MAY BE NECESSARY AND SHALL BE CARRIED OUT AS DIRECTED BY THE ENGINEER AT NO EXTRA PAY.
4.

A MINIMUM OF 48 INCHES OF COVER, OR AS OTHERWISE NOTED ON THE PLANS, IS REQUIRED OVER ALL UTILITY LINES.
5.

COMPACTION OF BACKFILL MATERIAL BY FLOODING OR JETTING WILL NOT BE PERMITTED. ALL TRENCH BACKFILLL TO BE COMPACTED TO A MIN. 95% DENSITY.
6.

THE CONTRACTOR CAN OBTAIN A CONSTRUCTION METER THROUGH THE CITY OF ROCKWALL AND PAY FOR THE WATER USED.
7.

DURING CONSTRUCTION AND AT THE COMPLETION OF CONSTRUCTION, THE CONTRACTOR SHALL ENSURE THAT DRAINAGE OF STORM RUNOFF IS NOT BLOCKED. THE CONTRACTOR SHALL LEVEL WASHES, RUTS, MOUNDS AND DEPRESSIONS TO GIVE THE AREA A SMOOTH FINISH. ROADWAY DITCHS AND OTHER DRAINAGE WAYS DISTURBED BY THE CONSTRUCTION SHALL BE GRADED TO ORIGINAL GRADES AND SHAPE.
8.

THE CONTRACTOR IS TO MAINTAIN ACCESS TO PUBLIC AND PRIVATE FACILITIES DURING CONSTRUCTION. CONSTRUCTION ACTIVITIES ARE TO BE COORDINATED WITH THE OWNER, OWNER'S REPRESENTATIVE, AND THE CITY OF ROCKWALL.
9.

THE CONTRACTOR SHALL REPAIR ANY DAMAGE TO EXISTING IRRIGATION SYSTEMS WITH NEW MATERIALS. IRRIGATION HEADS, VALVES, AND METERS MAY BE TEMPORARILY REMOVED TO ALLOW FOR CONSTRUCTION OF THE PROJECT. IRRIGATION HEADS, VALVES, AND METERS SHALL BE REPLACED IN THE SAME LOCATION AND IN WORKING ORDER.
10.

THE CONTRACTOR MUST NOTIFY EACH PROPERTY OWNER 48 HOURS PRIOR TO SHUTTING OFF WATER FOR CONNECTION TO NEW MAIN.
11.

THE CONTRACTOR SHALL MAINTAIN IN SERVICE THE EXISTING WATER MAINS AND SERVICE CONNECTIONS DURING ALL PHASES OF CONSTRUCTION AT NO EXTRA PAY. LEAKS CAUSED BY THE CONTRACTOR SHALL BE REPAIRED IMMEDIATELY AT THE CONTRACTOR'S EXPENSE.
12.

EXISTING 16" WATER LINE TO REMAIN IN SERVICE UNTIL THE PROPOSED 16" WATER LINE IS ACCEPTED BY THE CITY.

13.

ALL SALVAGEABLE MATERIALS (VALVES, FIRE HYDRANTS, VALVE BOXES, ETC.) SHALL BE DELIVERED TO THE CITY OF ROCKWALL PUBLIC WORKS YARD. ALL NON-SALVAGEABLE MATERIALS TO BECOME PROPERTY OF THE CONTRACTOR AND TO BE DISPOSED OF OFFSITE.
14.

FOR EACH OPEN CUT DRIVEWAY, CONTRACTOR SHALL REPAIR DRIVEWAY WITH SIMILAR TYPE AND QUALITY MATERIALS AND MATCHING EXISTING GRADE, IN ACCORDANCE WITH THE PAVEMENT CUT AND REPAIR DETAIL ON SHEET 14, UNLESS OTHERWISE NOTED.
15.

FOR EACH OPEN CUT STREET, CONTRACTOR SHALL REPAIR STREET WITH SIMILAR TYPE AND QUALITY MATERIALS AND MATCH EXISTING GRADE. IN ACCORDANCE WITH PAVING REPLACEMENT DETAIL ON SHEET 14. UNLESS OTHERWISE NOTED.
16.

SITE RESTORATION INCLUDES FINAL GRADING OF ALL AREAS DISTURBED BY THE CONSTRUCTION AND THE ESTABLISHMENT OF A PERMANENT VEGETATIVE COVER ON THOSE AREAS. BROADCAST SEEDING SHALL BE PERFORMED IN CONFORMANCE WITH TXDOT SPECIFICATIONS ITEM NO. 164. THE FERTILIZER USED SHALL HAVE AN ANALYSIS OF 10-20-10 AND SHALL BE APPLIED AT A RATE OF 500 LBS PER ACRE. THE ESTABLISHMENT OF A UNIFORM PERENNIAL VEGETATIVE COVER WITH A DENSITY OF 70 PERCENT OF THE ADJACENT UNDISTURBED AREAS WILL BE REQUIRED FOR FINAL ACCEPTANCE OF THE WORK.
17.

THE MAXIMUM DEFLECTION OF PIPE JOINTS SHALL NOT EXCEED THAT RECOMMENDED BY THE PIPE MANUFACTURER. IF IT IS NECESSARY TO DEFLECT THE PIPE GREATER THAN THE RECOMMENDED AMOUNT, THE CONTRACTOR SHALL PROVIDE FITTINGS. THERE SHALL BE NO ADDITIONAL COMPENSATION ALLOWED.
18.

THE CONTRACTOR SHALL INSTALL BLUE ELECTRONIC MARKER SYSTEM (EMS) LOCATOR PADS ALONG THE WATER LINE EVERY 250', AT VALVES, AT CHANGES IN DIRECTION, AND AT SERVICES.
19.

ALL PIPE FITTINGS SHALL BE DUCTILE IRON AND SHALL BE MECHANICAL JOINT FITTINGS UNLESS OTHERWISE NOTED IN THE PLANS. ALL FITTINGS SHALL BE WRAPPED WITH MINIMUM 8 MIL POLYWRAP PER AWWA C 105. COMPACT FITTINGS WILL BE ALLOWED. ALL FITTINGS MUST BE AMERICAN MADE. MAXIMUM ALLOWABLE WEIGHT TO BE PAID PER FITTING IS LISTED IN THE TABLE ON THE QUANTITY SHEET.
20.

THE CONTRACTOR SHALL MAINTAIN ACCESS TO ALL UTILITIES AND SERVICES WITH THE APPLICABLE UTILITY COMPANIES AND/OR AGENCIES. ALL WORK IS TO BE DONE IN ACCORDANCE WITH THE REQUIREMENTS OF THE APPLICABLE UTILITY COMPANY OR AGENCY INVOLVED. THE CONTRACTOR SHALL CONTACT THE TEXAS ONE-CALL SYSTEM FOR UTILITY LOCATIONS PRIOR TO ANY WORK IN PUBLIC EASEMENTS OR RIGHT-OF-WAY AT 1-800 545-6005.
21.

THE CONTRACTOR SHALL MAINTAIN IN SERVICE THE EXISTING WATER MAINS AND SERVICE CONNECTIONS DURING ALL PHASES OF CONSTRUCTION AT NO EXTRA PAY. LEAKS CAUSED BY THE CONTRACTOR SHALL BE REPAIRED IMMEDIATELY AT THE CONTRACTOR'S EXPENSE.
22.

EXISTING 16" WATER LINE TO REMAIN IN SERVICE UNTIL THE PROPOSED 16" WATER LINE IS ACCEPTED BY THE CITY.
23.

ATMOS GAS 800-344-8377  
ONCOR 972-888-1302  
COMCAST 214-320-7546  
VERIZON COMMUNICATIONS 972-434-0622  
AT&T 214-745-8200  
NORTH TEXAS MUNICIPAL WATER DISTRICT 972-442-5405  
BLACKLAND WSC 972-771-6375
24.

WHEN AN UN-LOCATED OR INCORRECTLY LOCATED UNDERGROUND UTILITY OR A BREAK IN A UTILITY IS ENCOUNTERED DURING SITE WORK OPERATIONS, THE CONTRACTOR IS TO NOTIFY THE APPLICABLE UTILITY COMPANY IMMEDIATELY TO OBTAIN PROCEDURE DIRECTIONS. NO EXTRA PAY ITEM.

25.

THE CONTRACTOR SHALL BE REQUIRED TO ARRANGE TEMPORARY/PERMANENT RELOCATION, SUPPORT AND/OR PROTECT ALL POWER, ELECTRIC, TELEPHONE, OR LIGHT POLES THAT MAY INTERFERE WITH CONSTRUCTION. COORDINATION WITH THE VARIOUS UTILITY COMPANIES SHALL BE THE CONTRACTOR'S RESPONSIBILITY. NO EXTRA PAY ITEM.
26.

CONTRACTOR IS RESPONSIBLE FOR PERSONNEL SAFETY IN PROXIMITY OF OVERHEAD POWER UTILITIES. CONTRACTOR SHALL ARRANGE FOR POLE RELOCATIONS OR DE-ENERGIZING LINES AS NEEDED. NO EXTRA PAY ITEM.

TRAFFIC CONTROL

27.

THE CONTRACTOR IS RESPONSIBLE FOR PLACEMENT AND MAINTENANCE OF ALL NECESSARY BARRICADES AS REQUIRED BY THE CITY OF ROCKWALL AND TXDOT. CONTRACTOR SHALL PROVIDE, INSTALL, AND MAINTAIN TRAFFIC CONTROL DEVICES IN CONFORMANCE WITH THE 2006 TEXAS MANUAL OF UNIFORM TRAFFIC CONTROL DEVICES (TMUTCD) TEXAS DEPARTMENT OF TRANSPORTATION. CONTRACTOR SHALL SUBMIT A TRAFFIC CONTROL PLAN SIGNED AND SEALED BY AN ENGINEER IN THE STATE OF TEXAS, FOR APPROVAL PRIOR TO CONSTRUCTION. THE TRAFFIC CONTROL PLAN SHALL BE SUBMITTED FOR APPROVAL BY THE CITY OF ROCKWALL AND TXDOT.
28.

NO STOP OR YIELD SIGN IS TO BE RELOCATED OR REMOVED WITHOUT PRIOR APPROVAL BY THE CITY AND TXDOT. THE CONTRACTOR MUST CALL TXDOT (972-962-3617) AND OBTAIN PERMISSION FOR ANY CHANGES IN THESE SIGNS.
29.

NORMAL TRAFFIC CONDITIONS MUST BE MAINTAINED AT ALL TIMES ON THIS PROJECT UNLESS SPECIFIED OTHERWISE IN THE PLANS AND SPECIFICATIONS. THE TRAVELWAY WIDTH SHALL NOT BE LESS THAN 10 FEET, FOR EACH LANE.
30.

ACCESS TO ABUTTING PROPERTY DURING THE CONSTRUCTION OF THIS PROJECT MUST BE MAINTAINED FOR EMERGENCY AND LOCAL TRAFFIC AT ALL TIMES.

STORM WATER POLLUTION PREVENTION

31.

UNLESS OTHERWISE NOTED, ALL STORM WATER POLLUTION PREVENTION MEASURES SHALL CONFORM TO THE CITY OF ROCKWALL STANDARDS OR TO APPLICABLE GUIDELINES OF THE NORTH CENTRAL TEXAS COUNCIL OF GOVERNMENTS, STORM WATER QUALITY BEST MANAGEMENT PRACTICES FOR CONSTRUCTION ACTIVITIES, LATEST EDITION OR AMENDMENTS, FOR COMPLIANCE WITH NATIONAL POLLUTION DISCHARGE ELIMINATION SYSTEM REQUIREMENTS.
32.

CONTRACTOR IS RESPONSIBLE FOR MAINTAINING SURFACE DRAINAGE AND EROSION CONTROL FACILITIES ON SITE DURING CONSTRUCTION.
33.

THE CONTRACTOR IS RESPONSIBLE FOR KEEPING STREETS AND SIDEWALKS ADJACENT TO THE PROJECT FREE OF MUD AND DEBRIS FROM THE CONSTRUCTION AT ALL TIMES.
34.

CONTRACTOR IS RESPONSIBLE FOR OBTAINING AND COMPLETING ANY APPLICABLE LOCAL, STATE, OR FEDERAL PERMITTING REQUIREMENTS WHICH MAY APPLY. NO EXTRA PAY ITEM.

THRUST BLOCKING & JOINT RESTRAINTS

35.

ALL PIPE FITTINGS SHALL BE RESTRAINED WITH MEGA-LUG SERIES 2000PV MECHANICAL JOINT RESTRAINT GLANDS OR APPROVED EQUAL AND THRUST BLOCKED AT ALL HORIZONTAL AND VERTICAL CHANGES IN PIPE DIRECTION. NO EXTRA PAY ITEM FOR MEGA-LUG OR APPROVED EQUAL RESTRAINED JOINTS, OR FOR THRUST BLOCKING.
36.

ALL VALVES SHALL HAVE CONCRETE SUPPORT BLOCKING. NO EXTRA PAY ITEM.

**RECORD DRAWING**  
THESE RECORD DRAWINGS WERE PREPARED BY THE ENGINEER BASED UPON AS-CONSTRUCTED DRAWINGS PROVIDED BY THE CONSTRUCTION CONTRACTOR, WHO REPRESENTED THAT ALL FIELD CHANGES AND OTHER DEVIATIONS FROM THE APPROVED CONSTRUCTION DRAWINGS WERE INCLUDED.

DESIGNED BY: E.J.H.

DRAWN BY: PMH

CHECKED BY: FCG

APPROVED BY: FCG

DATE: MARCH 22, 2017

BY

REVISION

NO.

**ATKINS**

18383 PRESTON RD., SUITE 500  
DALLAS, TEXAS 75252 • (972) 818-7775  
TPOE REC. NO. F-474

**F.M. 3549 16" WATERLINE  
RELOCATION PROJECT**

**GENERAL NOTES**

SHEET NO.

2

OF

14

SHEETS

FILE NO. RW-WL-GN01

PROJECT NO. 100049910



# LEGEND OF UTILITY TYPES

|                          |                                   |
|--------------------------|-----------------------------------|
| ABANDONED UTILITY        | _____ UGU _____                   |
| PROPOSED UTILITY         | _____ <b>W</b> _____              |
| UNKNOWN                  | _____ _____                       |
| <b>Communications</b>    |                                   |
| AT&T/SPRINT (FIBER/DUCT) | _____ FO _____ FO _____           |
| AT&T (CABLE)             | _____ UGT _____ UGT _____         |
| UNKNOWN (CATV)           | _____ UG CATV _____ UG CATV _____ |
| <b>Gas / Petroleum</b>   |                                   |
| ATMOS                    | _____ G _____ G _____ G _____     |
| <b>Potable Water</b>     |                                   |
| NTMWD                    |                                   |
| BLACK LAND WS CO         | _____ W _____ W _____ W _____     |
| CITY OF ROCKWALL         |                                   |
| <b>Electric / Power</b>  |                                   |
| FARMERS ELEC. COOP       | _____ USE _____ USE _____         |

| LEGEND OF UTILITY SYMBOLS       |  |
|---------------------------------|--|
| TEST HOLE                       |  |
| END CAP                         |  |
| UTILITY CONTINUATION            |  |
| TELEPHONE CABINET               |  |
| TELEPHONE PEDESTAL              |  |
| TELEPHONE HANDHOLE (VAULT)      |  |
| TELEPHONE MANHOLE               |  |
| TELEPHONE POLE                  |  |
| TELEPHONE POLE W/ RISER         |  |
| FIBER HANDHOLE                  |  |
| WATER VAULT                     |  |
| WATER VALVE                     |  |
| WATER METER                     |  |
| WATER MANHOLE                   |  |
| FIRE HYDRANT                    |  |
| GAS VENT PIPE (GAS RISER)       |  |
| GAS VALVE                       |  |
| GAS METER                       |  |
| GAS TEST STATION                |  |
| WASTE WATER MANHOLE             |  |
| WASTE WATER CLEANOUT            |  |
| STORM SEWER MANHOLE             |  |
| STORM SEWER INLET               |  |
| CATV HANDHOLE                   |  |
| CATV CABINET                    |  |
| CATV PEDESTAL                   |  |
| LIGHT POLE                      |  |
| ELECTRIC JUNCTION BOX (CABINET) |  |
| ELECTRIC POLE (POWER)           |  |
| ELECTRIC POLE W/ RISER          |  |
| TRANSMISSION POLE               |  |
| ELECTRIC HANDHOLE               |  |
| ELECTRIC MANHOLE                |  |
| SIGNAL POLE                     |  |
| SIGNAL HANDHOLE/BOX             |  |
| PROPOSED FIRE HYDRANT           |  |
| PROPOSED GATE VALVE             |  |
| PROPOSED BUTTERFLY VALVE        |  |
| PROPOSED AIR RELEASE VALVE      |  |

| LEGEND                 |                                                                                     |
|------------------------|-------------------------------------------------------------------------------------|
| PROPOSED RIGHT OF WAY  |  |
| EXISTING RIGHT OF WAY  |  |
| EXISTING EASEMENT LINE |  |
| PROPOSED CURB          |  |
| PROPOSED SIDEWALK      |  |
| EXISTING PAVEMENT      |  |

| F.M 3549 16" WATERLINE RELOCATION CONTROL |          |             |             |     |
|-------------------------------------------|----------|-------------|-------------|-----|
| CONTROL POINT                             | STATION  | OFFSET (FT) | N           |     |
| 1                                         | 21+84.25 | 22.06' RT   | 7025756.000 | 260 |
| 2                                         | 28+27.54 | 36.27' LT   | 7026398.005 | 260 |
| 529                                       | 33+14.08 | 1.42' RT    | 7026885.200 | 260 |
| 3                                         | 33+26.18 | 36.34' RT   | 7026897.991 | 260 |
| 4                                         | 37+52.02 | 77.45' TR   | 7027327.093 | 260 |
| 5                                         | 41+22.92 | 18.18' LT   | 7027692.958 | 260 |
| 100                                       | 44+16.83 | 110.39' LT  | 7021984.987 | 260 |
| 6                                         | 46+83.51 | 18.30' LT   | 7028253.443 | 260 |

| LEGEND |                            |
|--------|----------------------------|
|        | SPOT ELEVATION             |
|        | CULVERT PIPE               |
|        | RAILROAD CONTROL BOX       |
|        | RAILROAD SIGNAL            |
|        | RAILROAD SWITCH            |
|        | POST                       |
|        | STREET LIGHT               |
|        | UTILITY METER              |
|        | UTILITY POLE               |
|        | HORIZONTAL CONTROL POINT   |
|        | VERTICAL CONTROL POINT     |
|        | GUY WIRE                   |
|        | MANHOLE                    |
|        | LAMP POST                  |
|        | TRAFFIC SIGNAL             |
|        | ELECTRIC TOWER             |
|        | GUY POLE                   |
|        | TELEPHONE PEDESTAL         |
|        | ELECTRIC UTILITY BOX       |
|        | ELECTRIC TRANSFORMER       |
|        | TRAFFIC SIGNAL CONTROL BOX |
|        | SIGN                       |
|        | ANTENNA                    |
|        | MAIL BOX                   |
|        | PARKING METER              |
|        | FLAG POLE                  |
|        | SATELLITE DISH             |
|        | STUMP                      |
|        | SHRUB                      |
|        | SMALL TREE OR SAPLING      |
|        | CONIFEROUS TREE            |



NOTES:

1. CONTRACTOR SHALL COORDINATE WITH CITY OF ROCKWALL FOR STAGING AND STORAGE AREAS.
2. CONSTRUCTION STARTUP SHALL BE COORDINATED WITH CITY OF ROCKWALL A MINIMUM OF 48 HOURS BEFORE CONSTRUCTION IS TO BEGIN.
3. THE CONTRACTOR IS RESPONSIBLE FOR VERIFYING THE LOCATION OF ALL EXISTING UTILITIES PRIOR TO CONSTRUCTION.
4. ALL PROPOSED WATER LINE PIPE MATERIAL SHALL BE, 4" TO 12" PVC C900 DR-14, 16" PVC C905 DR-18.
5. PROPOSED WATERLINE SHALL MAINTAIN A MINIMUM COVER OF 4 FEET FROM OUTSIDE TOP OF PIPE.
6. RECONNECT ALL EXISTING SERVICE LEADS TO PROPOSED PIPE.
7. CONTRACTOR SHALL REMOVE AND SALVAGE ABANDONED VALVE STACKS.
8. ALL FITTINGS, BENDS, AND VALVES SHALL BE RESTRAINED.

| Point # | Northing   | Easting    |
|---------|------------|------------|
| 1001    | 7025577.25 | 2607530.67 |
| 1002    | 7025670.11 | 2607533.46 |
| 1003    | 7025841.43 | 2607530.06 |
| 1004    | 7026214.83 | 2607522.65 |
| 1005    | 7026241.36 | 2607522.13 |
| 1006    | 7026342.40 | 2607520.12 |
| 1007    | 7026352.38 | 2607530.11 |
| 1008    | 7026367.39 | 2607530.10 |
| 1009    | 7026522.39 | 2607527.44 |
| 1010    | 7026532.39 | 2607527.28 |
| 1011    | 7026543.19 | 2607516.14 |
| 1012    | 7026553.46 | 2607515.93 |
| 1013    | 7026689.58 | 2607513.23 |
| 1014    | 7026789.83 | 2607511.24 |
| 1015    | 7026822.43 | 2607477.33 |
| 1016    | 7026904.39 | 2607475.70 |
| 1017    | 7026938.04 | 2607508.30 |
| 1018    | 7027062.95 | 2607505.22 |
| 1019    | 7027168.28 | 2607500.26 |
| 1020    | 7027178.87 | 2607509.66 |
| 1021    | 7027450.08 | 2607494.52 |
| 1022    | 7027673.16 | 2607489.71 |
| 1023    | 7027799.32 | 2607487.21 |
| 1024    | 7027823.13 | 2607486.74 |
| 1025    | 7027848.78 | 2607486.23 |
| 1026    | 7028131.36 | 2607480.62 |
| 1027    | 7028248.70 | 2607478.29 |
| 1028    | 7026983.09 | 2607507.41 |
| 1029    | 7027245.20 | 2607505.27 |
| 1030    | 7027511.87 | 2607492.91 |
| 1031    | 7026839.03 | 2607477.00 |
| 1032    | 7026903.44 | 2607475.72 |
| 1033    | 7026793.00 | 2607507.95 |

| ITEM<br>NUMBER | DESCRIPTION                                                         | UNIT | SH 4 |
|----------------|---------------------------------------------------------------------|------|------|
|                |                                                                     |      |      |
|                | MOBILIZATION                                                        | LS   |      |
|                | TIE TO EXISTING 16" WATER LINE                                      | EA   | 1    |
|                | TIE TO EXISTING 12" WATER LINE                                      | EA   |      |
|                | TIE TO EXISTING 8" WATER LINE                                       | EA   |      |
|                | 16" WATERLINE, C-905, DR-18 PVC, OPEN CUT                           | LF   | 424  |
|                | 12" WATERLINE, C-900, CLASS 200 PVC, OPEN CUT                       | LF   |      |
|                | 16" WATERLINE, C-905, DR-18 PVC, OPEN CUT WITH 30" STEEL ENCASEMENT | LF   |      |
|                | REMOVE & SALVAGE EXIST FIRE HYDRANT                                 | EA   | 1    |
|                | FIRE HYDRANT ASSEMBLY                                               | EA   | 1    |
|                | 16" BUTTERFLY VALVE                                                 | EA   | 1    |
|                | 12" GATE VALVE                                                      | EA   |      |
|                | 8" GATE VALVE                                                       | EA   |      |
|                | 6" GATE VALVE                                                       | EA   | 1    |
|                | 4" GATE VALVE                                                       | EA   |      |
|                | 2" AIR RELEASE VALVE                                                | EA   |      |
|                | 3" AIR RELEASE VALVE                                                | EA   |      |
|                | DUCTILE IRON FITTINGS                                               | TON  | 0.78 |
|                | * 16" PLUG ( LBS)                                                   | EA   | 1    |
|                | * 12" PLUG ( LBS)                                                   | EA   |      |
|                | * 8" PLUG ( LBS)                                                    | EA   |      |
|                | * 6" PLUG ( LBS)                                                    | EA   | 1    |
|                | * 4" PLUG ( LBS)                                                    | EA   |      |
|                | * 16" 11.25" BEND ( LBS)                                            | EA   | 1    |
|                | * 16" 45" BEND ( LBS)                                               | EA   | 1    |
|                | * 12" 45" BEND ( LBS)                                               | EA   |      |
|                | * 12" 90" BEND ( LBS)                                               |      |      |
|                | * 16"x6" MJ TEE ( LBS)                                              | EA   | 1    |
|                | * 16"x8" MJ TEE ( LBS)                                              | EA   |      |
|                | * 16"x12" MJ TEE ( LBS)                                             | EA   |      |
|                | * 8"x4" MJ REDUCER ( LBS)                                           | EA   |      |
|                | TRENCH SAFETY SYSTEM                                                | LF   | 424  |
|                | REMOVE/REPLACE REINFORCED CONCRETE PAVEMENT                         | SY   |      |
|                | REMOVE/RELACE ASPHALT PAVEMENT                                      | SY   |      |
|                | EROSION & SEDIMENTATION CONTROL MEASURES                            |      |      |
|                | SILT FENCE                                                          | LF   |      |
|                | INLET PROTECTION                                                    | EA   |      |
|                | TRAFFIC CONTROL PLAN                                                | LS   |      |
|                | SITE RESTORATION & REVEGETATION                                     | SY   |      |

| * FOR CONTRACTOR'S INFORMATION ONLY |          |
|-------------------------------------|----------|
| FITTING                             | WEIGHT   |
| 16" PLUG                            | 150 LBS. |
| 12" PLUG                            | 85 LBS.  |
| 8" PLUG                             | 45 LBS.  |
| 6" PLUG                             | 25 LBS.  |
| 4" PLUG                             | 15 LBS.  |
| 16" 11.25° BEND                     | 385 LBS. |
| 16" 45° BEND                        | 380 LBS. |
| 12" 45° BEND                        | 215 LBS. |
| 12" 90° BEND                        | 255 LBS. |
| 16"x6" MJ TEE                       | 615 LBS. |
| 16"x8" MJ TEE                       | 625 LBS. |
| 16"x12" MJ TEE                      | 660 LBS. |

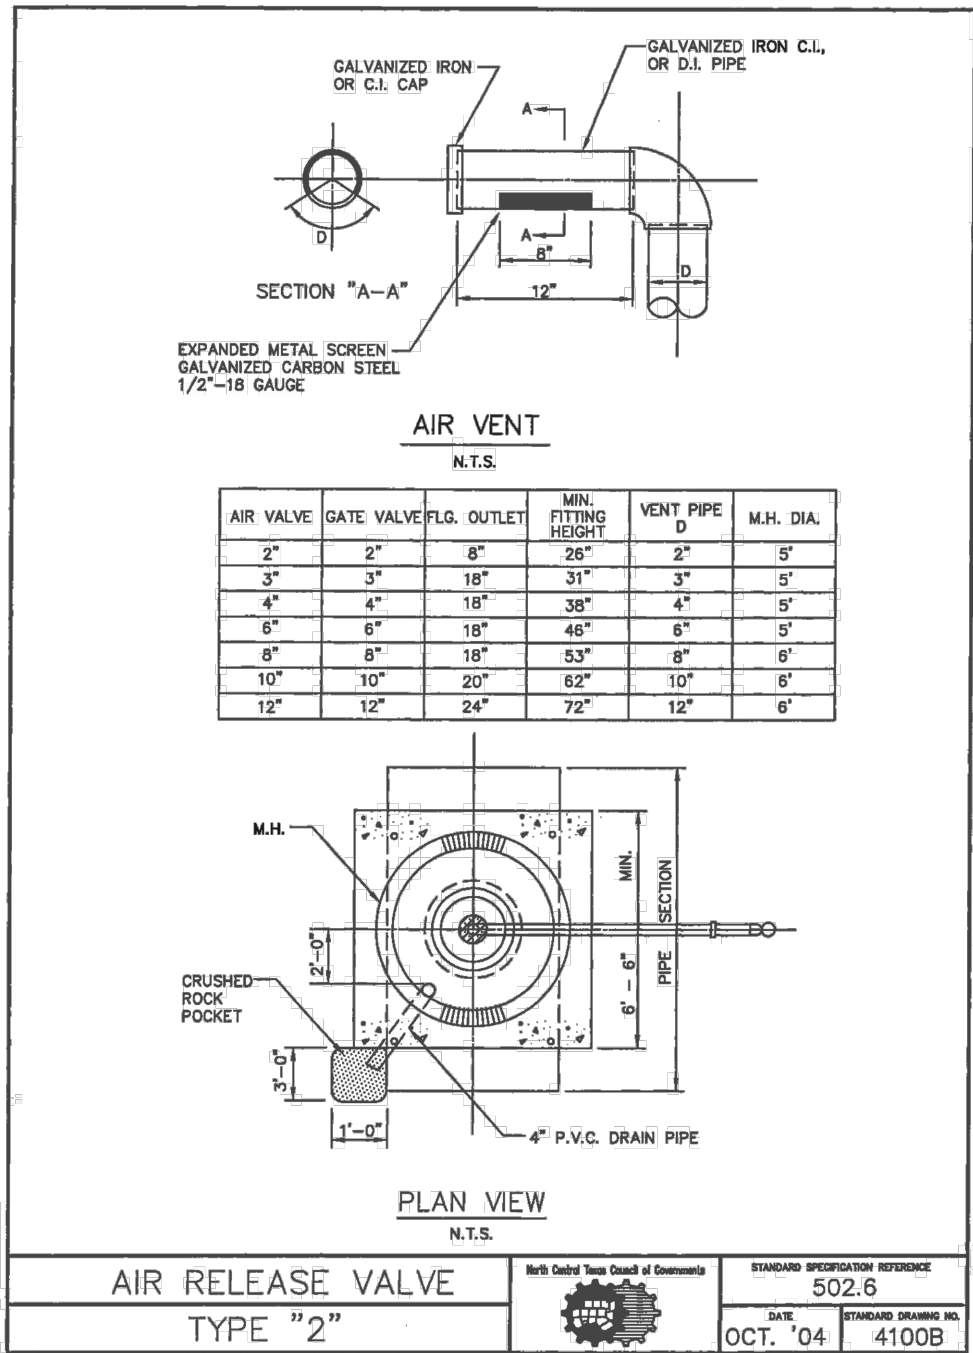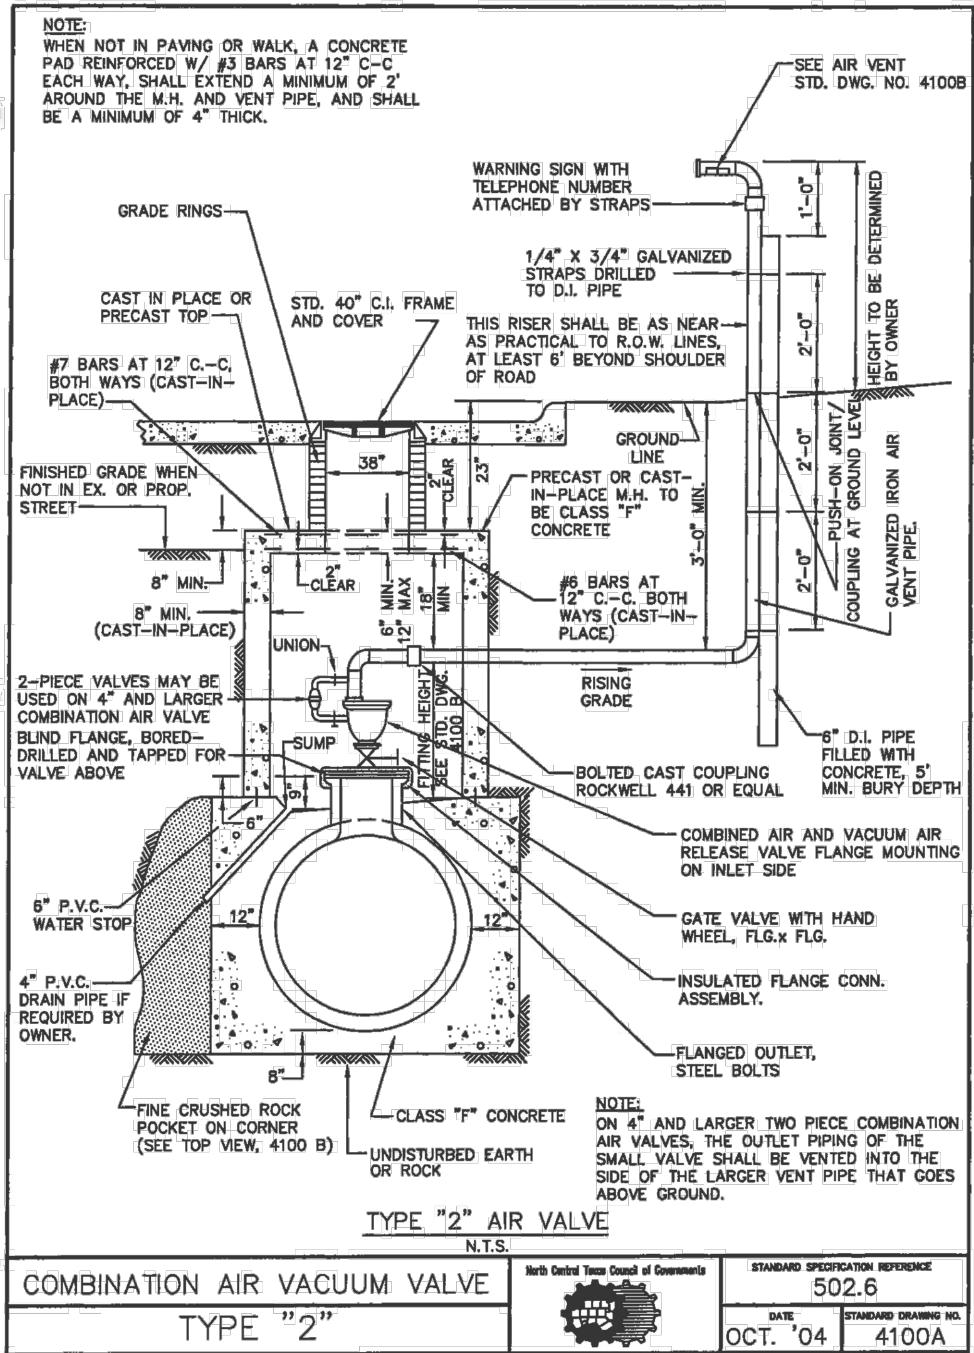


# RECORD DRAWING



THESE RECORD DRAWINGS WERE PREPARED BY THE ENGINEER BASED UPON AS-CONSTRUCTED DRAWINGS PROVIDED BY THE CONSTRUCTION CONTRACTOR, WHO REPRESENTED THAT ALL FIELD CHANGES AND OTHER DEVIATIONS FROM THE APPROVED CONSTRUCTION DRAWINGS WERE INCLUDED.



Jan 02, 2018 - 5:52pm mha3082 K:\Projects\N\100049910-Rockwall\2.0 Drawings\Sheets\_RW-WL-PP.dwg

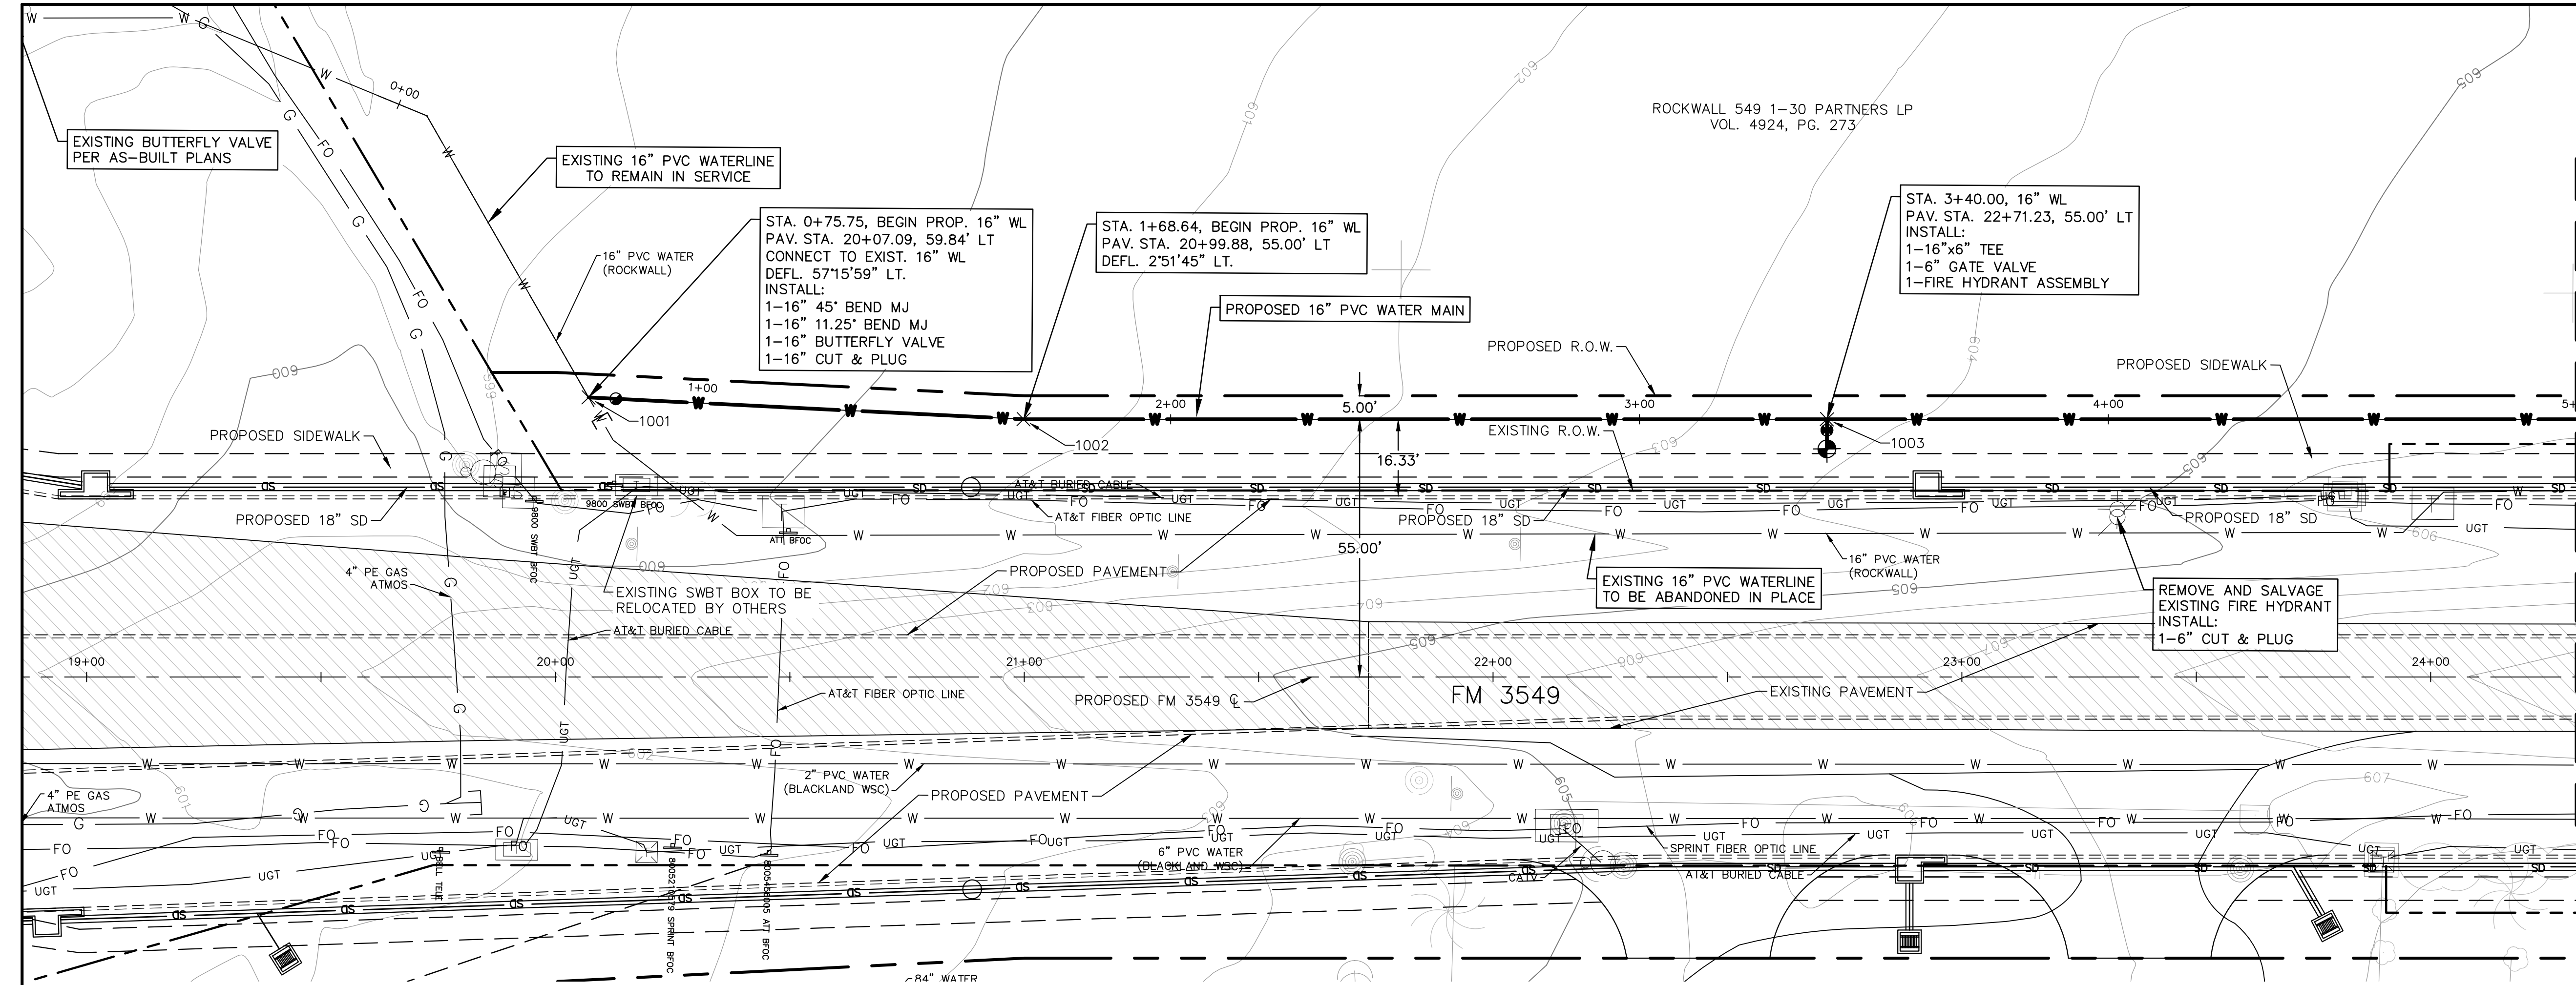

MATCH LINE STA. 5+00 SEE SHEET 5

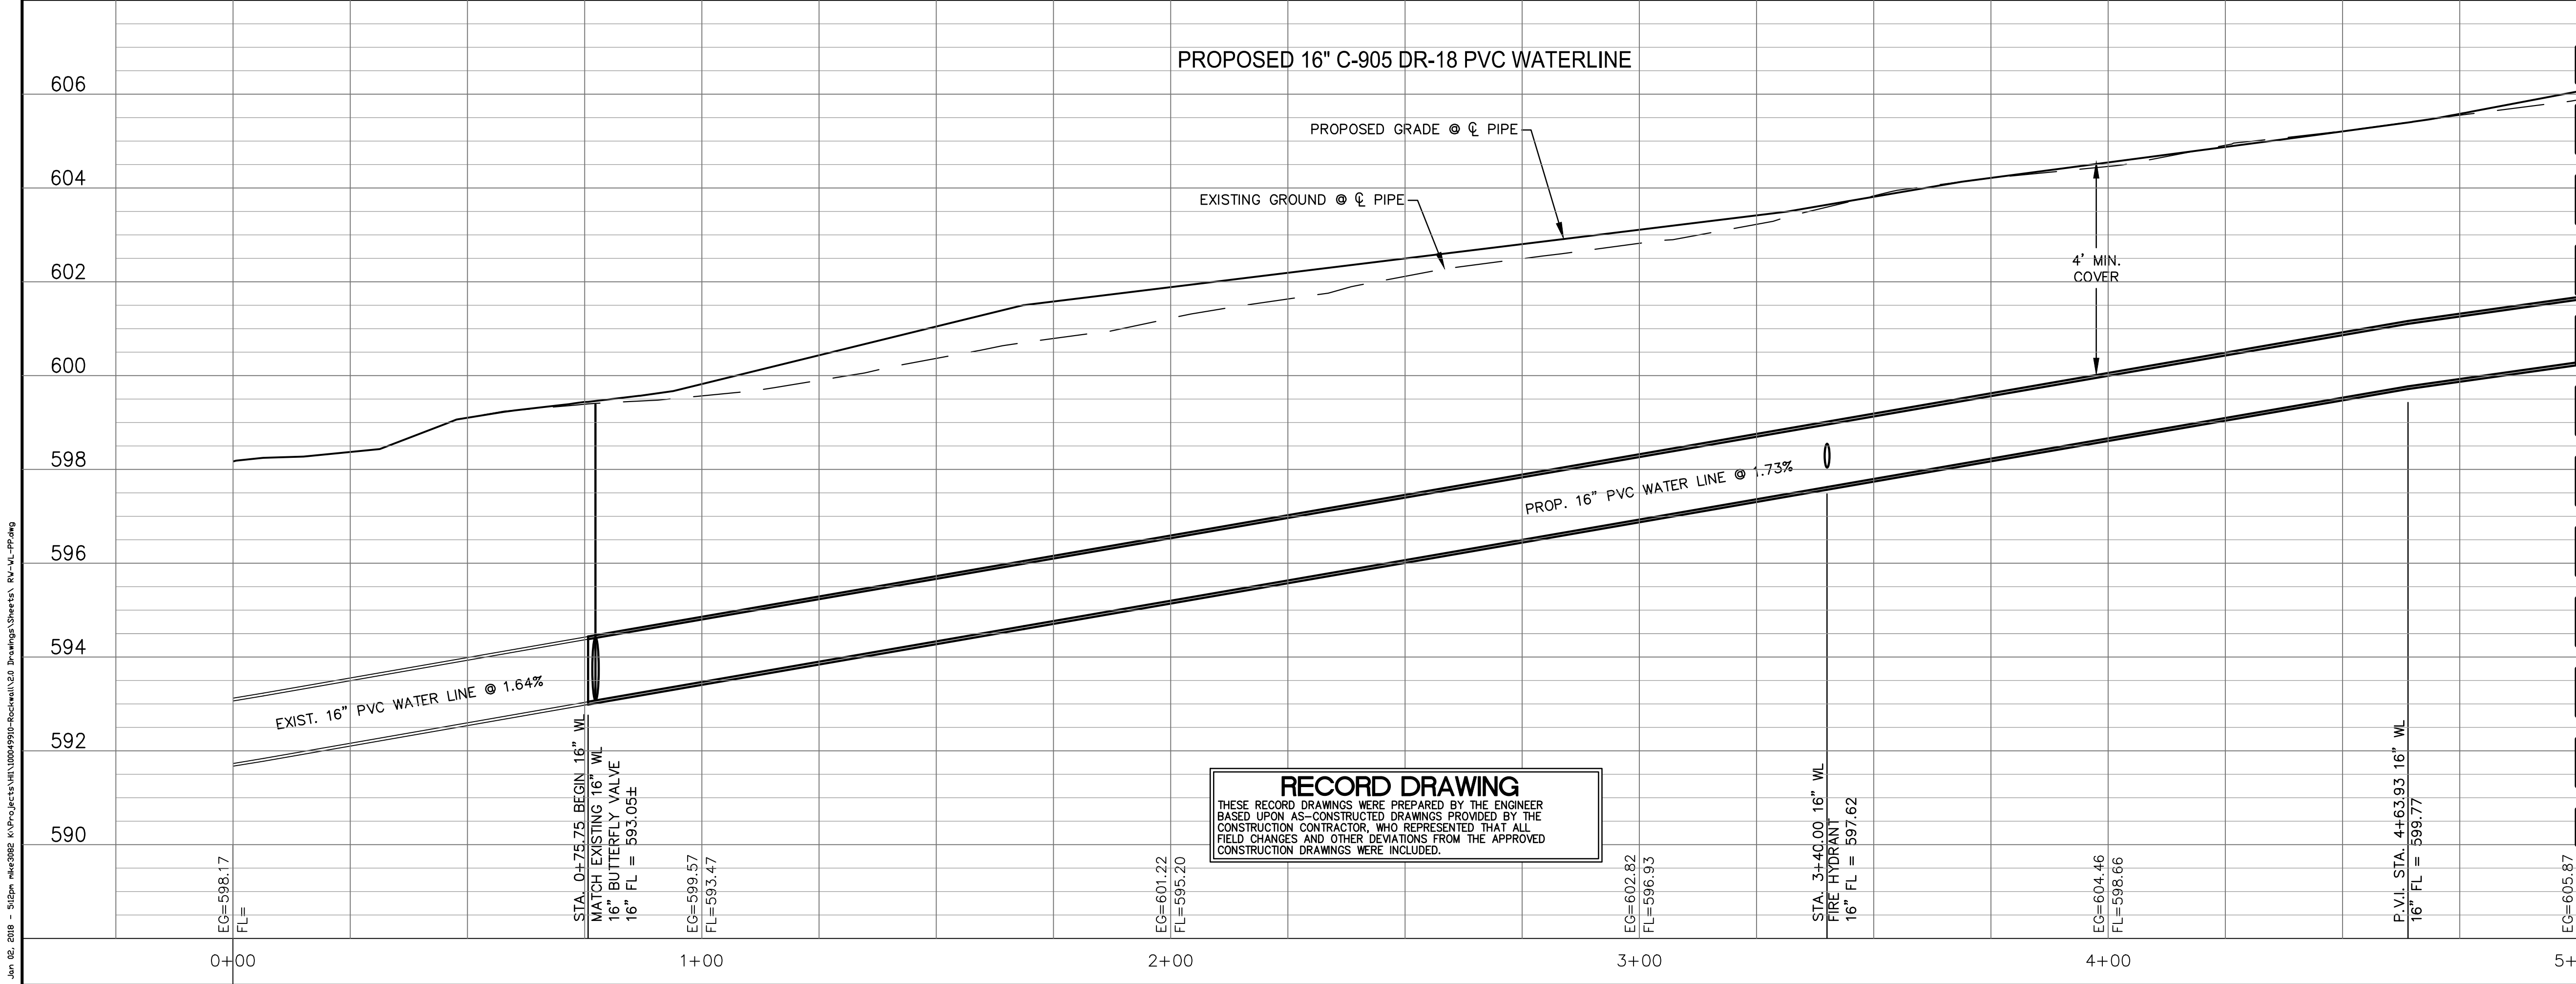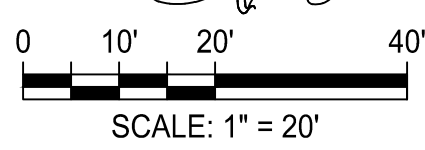

MATCH LINE STA. 5+00 SEE SHEET 5



**RECORD DRAWING**  
THESE RECORD DRAWINGS WERE PREPARED BY THE ENGINEER BASED UPON AS-CONSTRUCTED DRAWINGS PROVIDED BY THE CONSTRUCTION CONTRACTOR, WHO REPRESENTED THAT ALL FIELD CHANGES AND OTHER DEVIATIONS FROM THE APPROVED CONSTRUCTION DRAWINGS WERE INCLUDED.

|                                                                                       |  |               |  |                 |  |                  |  |                      |  |     |  |    |  |      |  |
|---------------------------------------------------------------------------------------|--|---------------|--|-----------------|--|------------------|--|----------------------|--|-----|--|----|--|------|--|
| DESIGNED BY: EJM                                                                      |  | DRAWN BY: PMH |  | CHECKED BY: FCG |  | APPROVED BY: FCG |  | DATE: MARCH 22, 2017 |  | NO. |  | BY |  | DATE |  |
|    |  |               |  |                 |  |                  |  |                      |  |     |  |    |  |      |  |
|  |  |               |  |                 |  |                  |  |                      |  |     |  |    |  |      |  |
| <b>F.M. 3549 16" WATERLINE<br/>RELOCATION PROJECT</b>                                 |  |               |  |                 |  |                  |  |                      |  |     |  |    |  |      |  |
| WATER LINE PLAN AND PROFILE<br>STA. 1+00 TO STA. 5+00                                 |  |               |  |                 |  |                  |  |                      |  |     |  |    |  |      |  |
| SHEET NO. 4                                                                           |  |               |  |                 |  |                  |  |                      |  |     |  |    |  |      |  |
| OF 14 SHEETS                                                                          |  |               |  |                 |  |                  |  |                      |  |     |  |    |  |      |  |
| FILE NO. RW-WL-PP<br>PROJECT NO. 100049910                                            |  |               |  |                 |  |                  |  |                      |  |     |  |    |  |      |  |







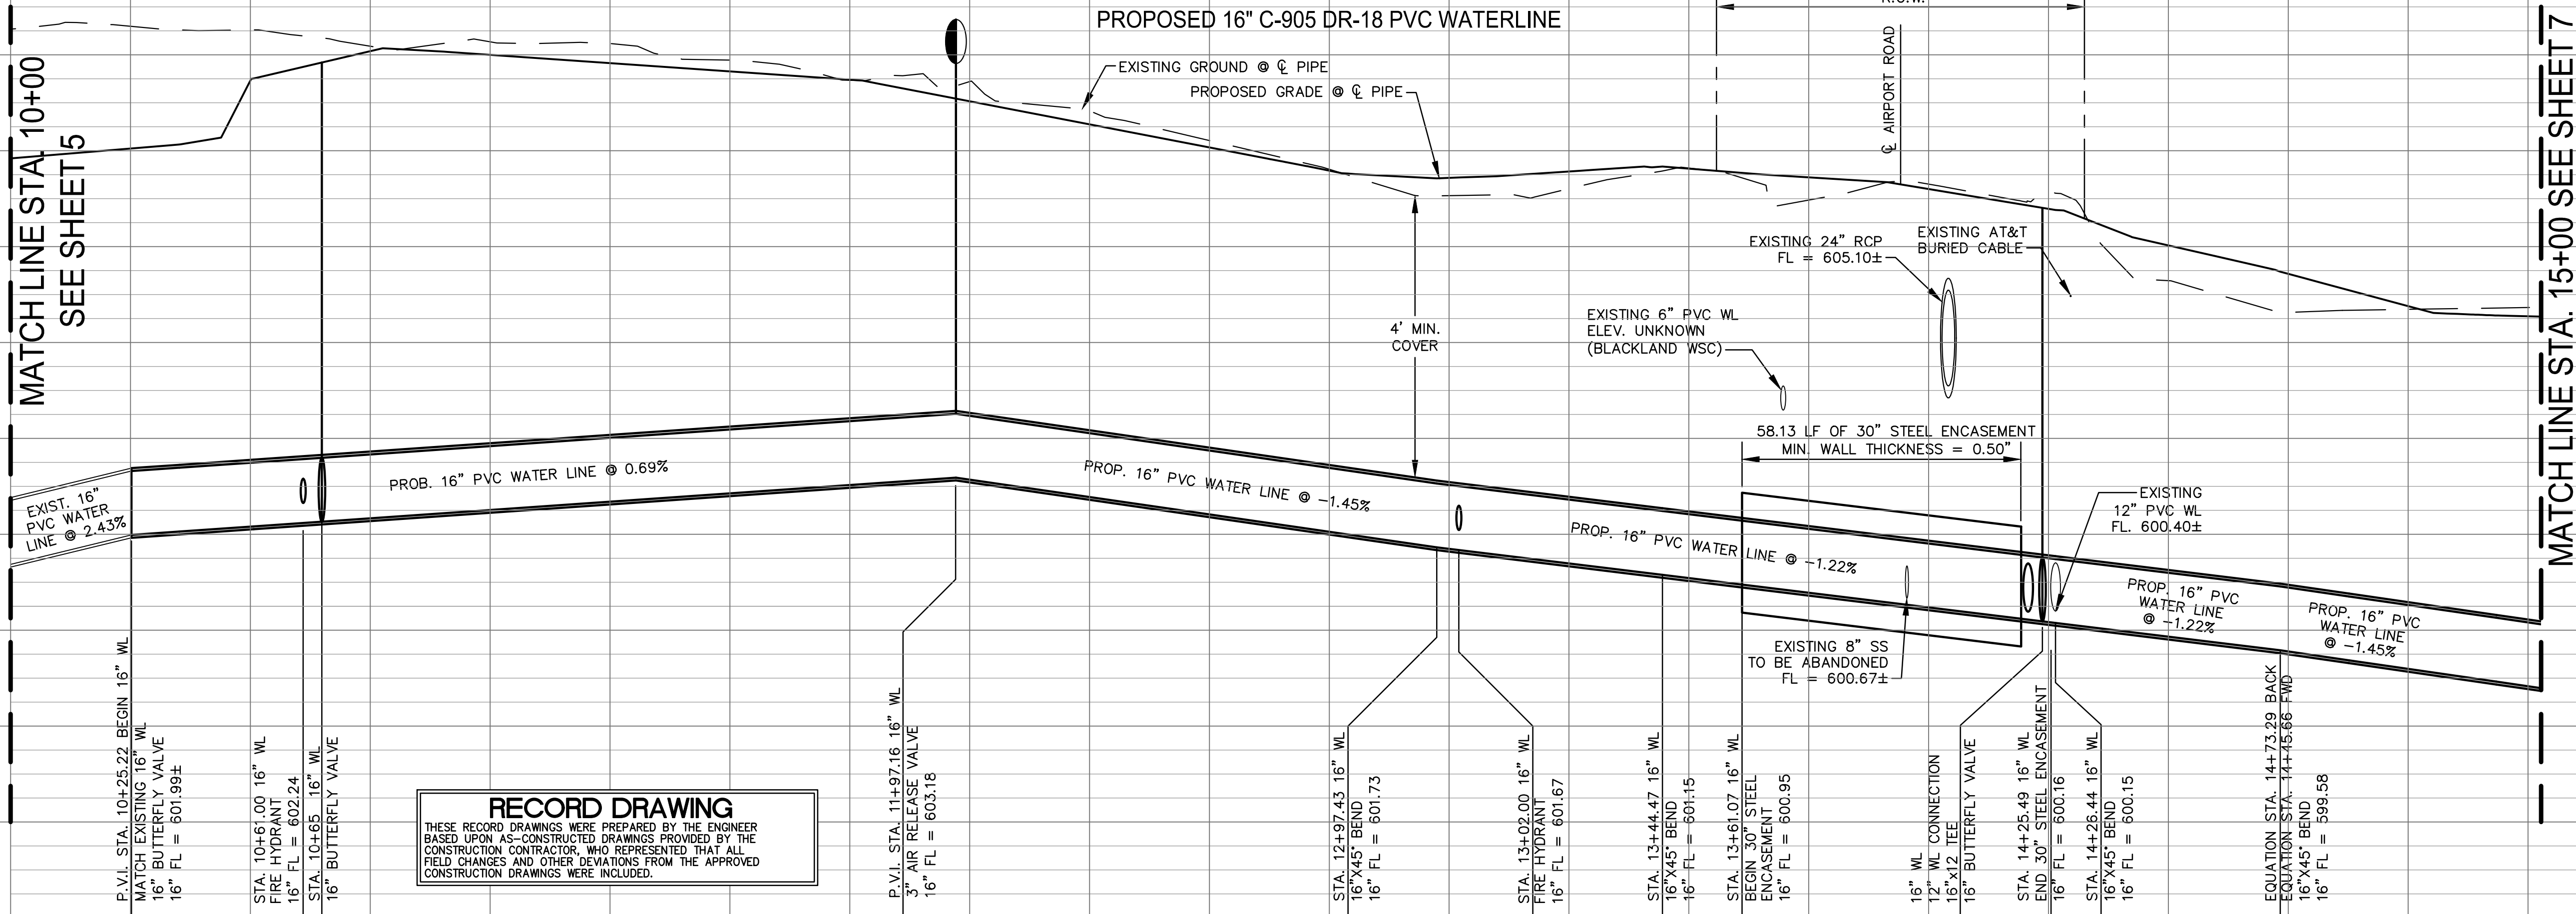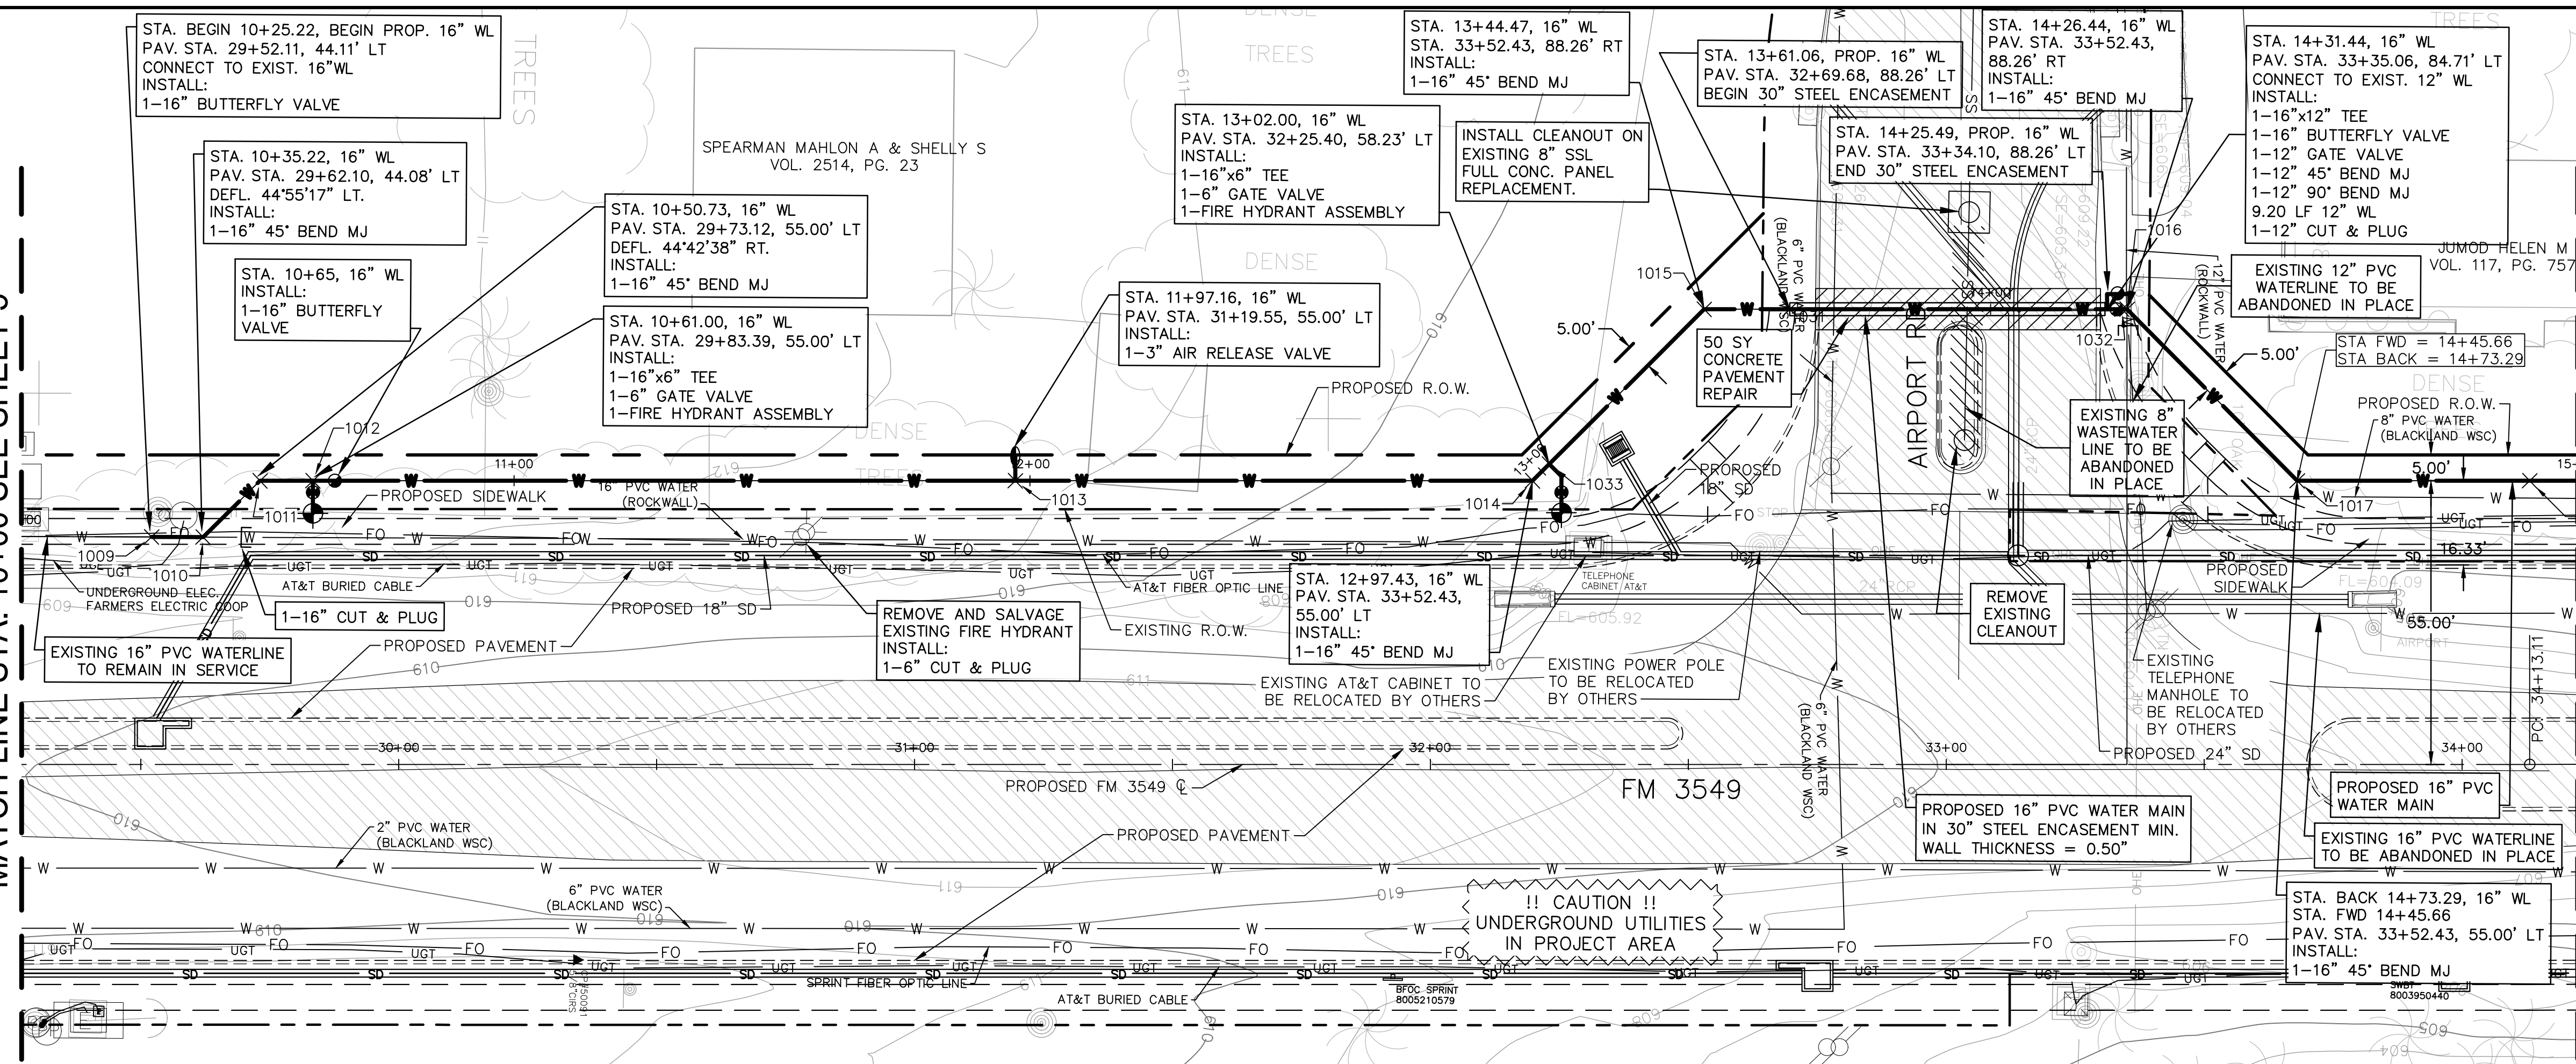

**RECORD DRAWING**  
 THESE RECORD DRAWINGS WERE PREPARED BY THE ENGINEER  
 BASED UPON AS-CONSTRUCTED DRAWINGS PROVIDED BY THE  
 CONSTRUCTION CONTRACTOR, WHO REPRESENTED THAT ALL  
 FIELD CHANGES AND OTHER DEVIATIONS FROM THE APPROVED  
 CONSTRUCTION DRAWINGS WERE INCLUDED.

**MATCH LINE STA. 15+00 SEE SHEET 7**

# ATKINS

8383 PRESTON RD., SUITE 500  
DALLAS, TEXAS 75252 - (972) 818-7275  
TBPE REG. NO. F-474

**F.M. 3549 16" WATERLINE  
RELOCATION PROJECT**



WATER LINE PLAN AND PROFILE  
STA. 10+00 TO STA. 15+00

SHEET NO. 6  
OF 14 SHEETS

FILE NO. RW-WL-PP  
PROJECT NO. 100049910




Jan. 02, 2018 - 5:46pm mha3082 K:\Projects\NAD\009910-Redwall\2.0 Drawings\Sheets\_RW-WL-PP.dwg

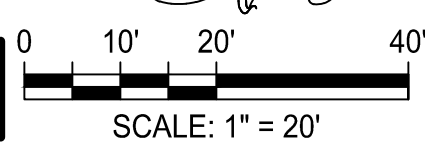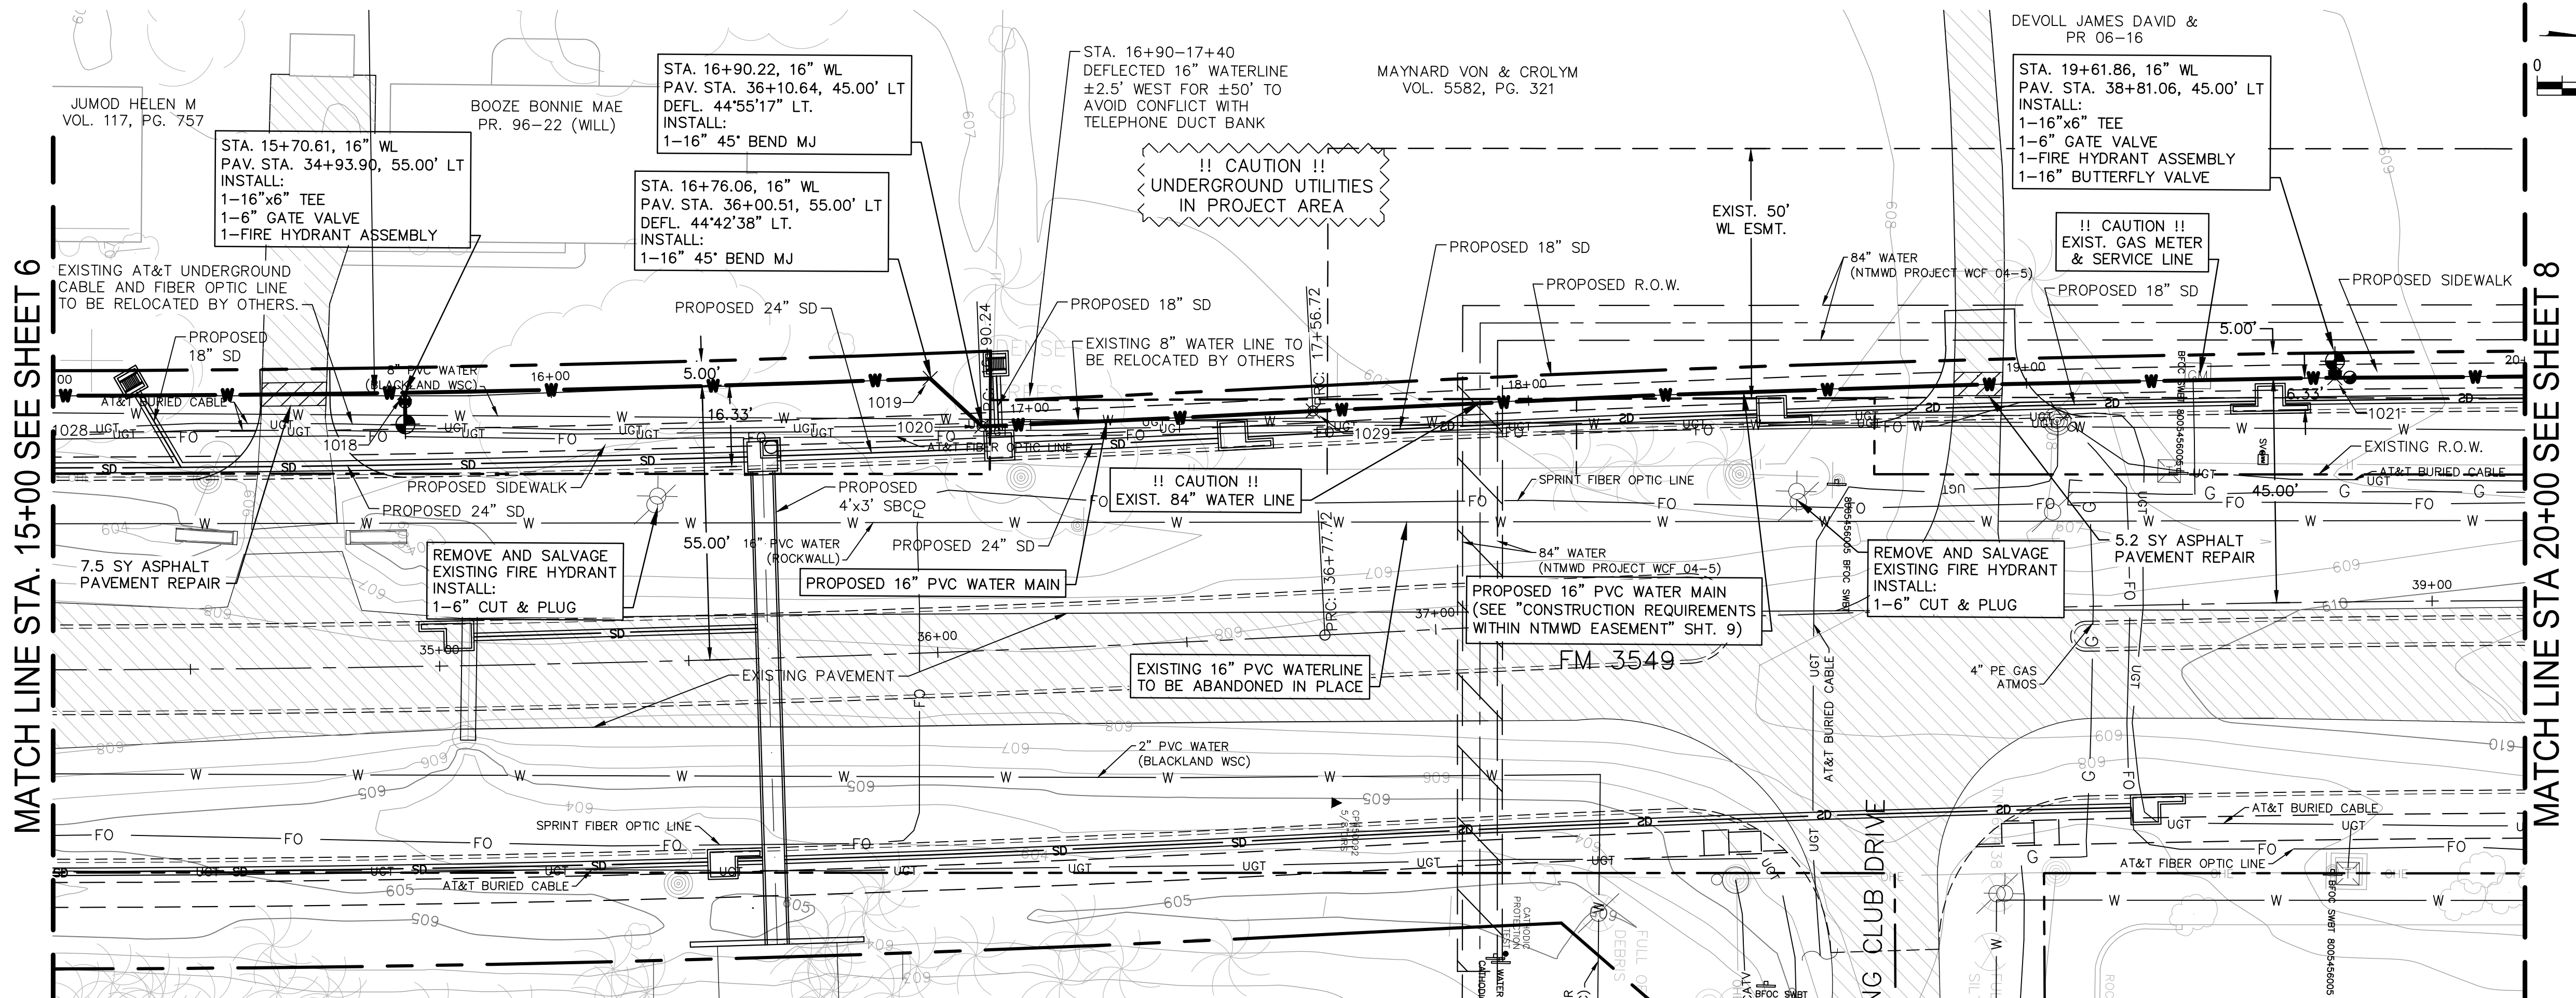

MATCH LINE STA. 15+00 SEE SHEET 6

MATCH LINE STA. 20+00 SEE SHEET 8

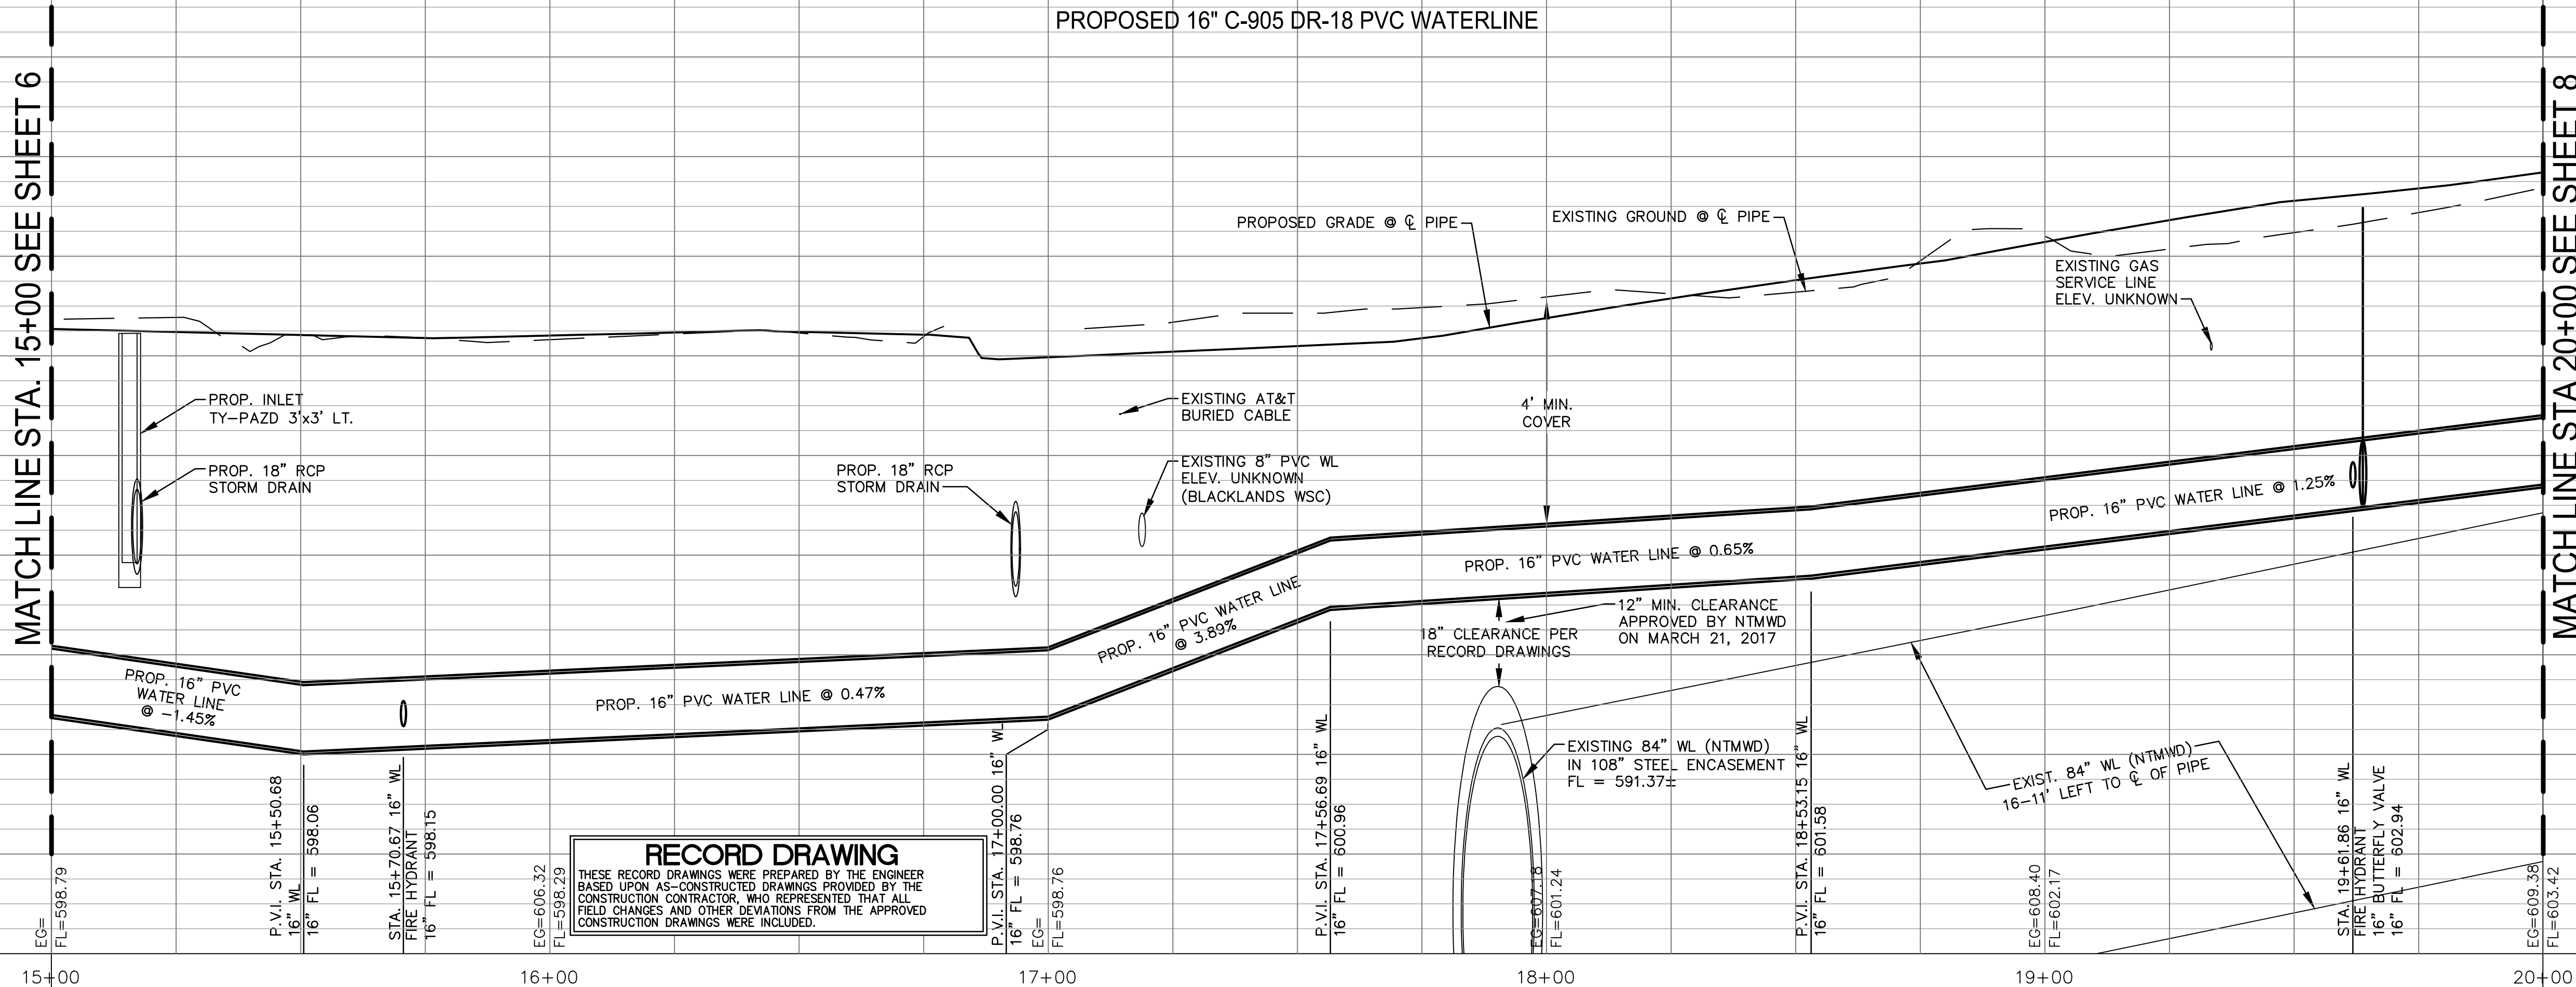

**RECORD DRAWING**  
THESE RECORD DRAWINGS WERE PREPARED BY THE ENGINEER BASED UPON AS-CONSTRUCTED DRAWINGS PROVIDED BY THE CONSTRUCTION CONTRACTOR, WHO REPRESENTED THAT ALL FIELD CHANGES AND OTHER DEVIATIONS FROM THE APPROVED CONSTRUCTION DRAWINGS WERE INCLUDED.

**ATKINS**

18383 PRESTON RD., SUITE 500  
DALLAS, TEXAS 75252 - (972) 818-7715  
TXPE REG. NO. F-474



**F.M. 3549 16" WATERLINE  
RELOCATION PROJECT**  
WATER LINE PLAN AND PROFILE  
STA. 15+00 TO STA. 20+00

SHEET NO. **7**  
OF **14** SHEETS  
FILE NO. RW-WL-PP  
PROJECT NO. 100049910

|              |                |
|--------------|----------------|
| DESIGNED BY: | EJH            |
| DRAWN BY:    | PMH            |
| CHECKED BY:  | FCG            |
| APPROVED BY: | FCG            |
| DATE:        | MARCH 22, 2017 |
| NO.          |                |
| REVISION     |                |
| BY           |                |
| DATE         |                |










Jan 02, 2018 - 5:46pm mha3082 K:\Projects\NLD0049910-Rockwall\2.0 Drawings\Sheets\_Plan\UL-PP.dwg

MATCH LINE STA. 25+00 SEE SHEET 8

MATCH LINE STA. 25+00 SEE SHEET 8

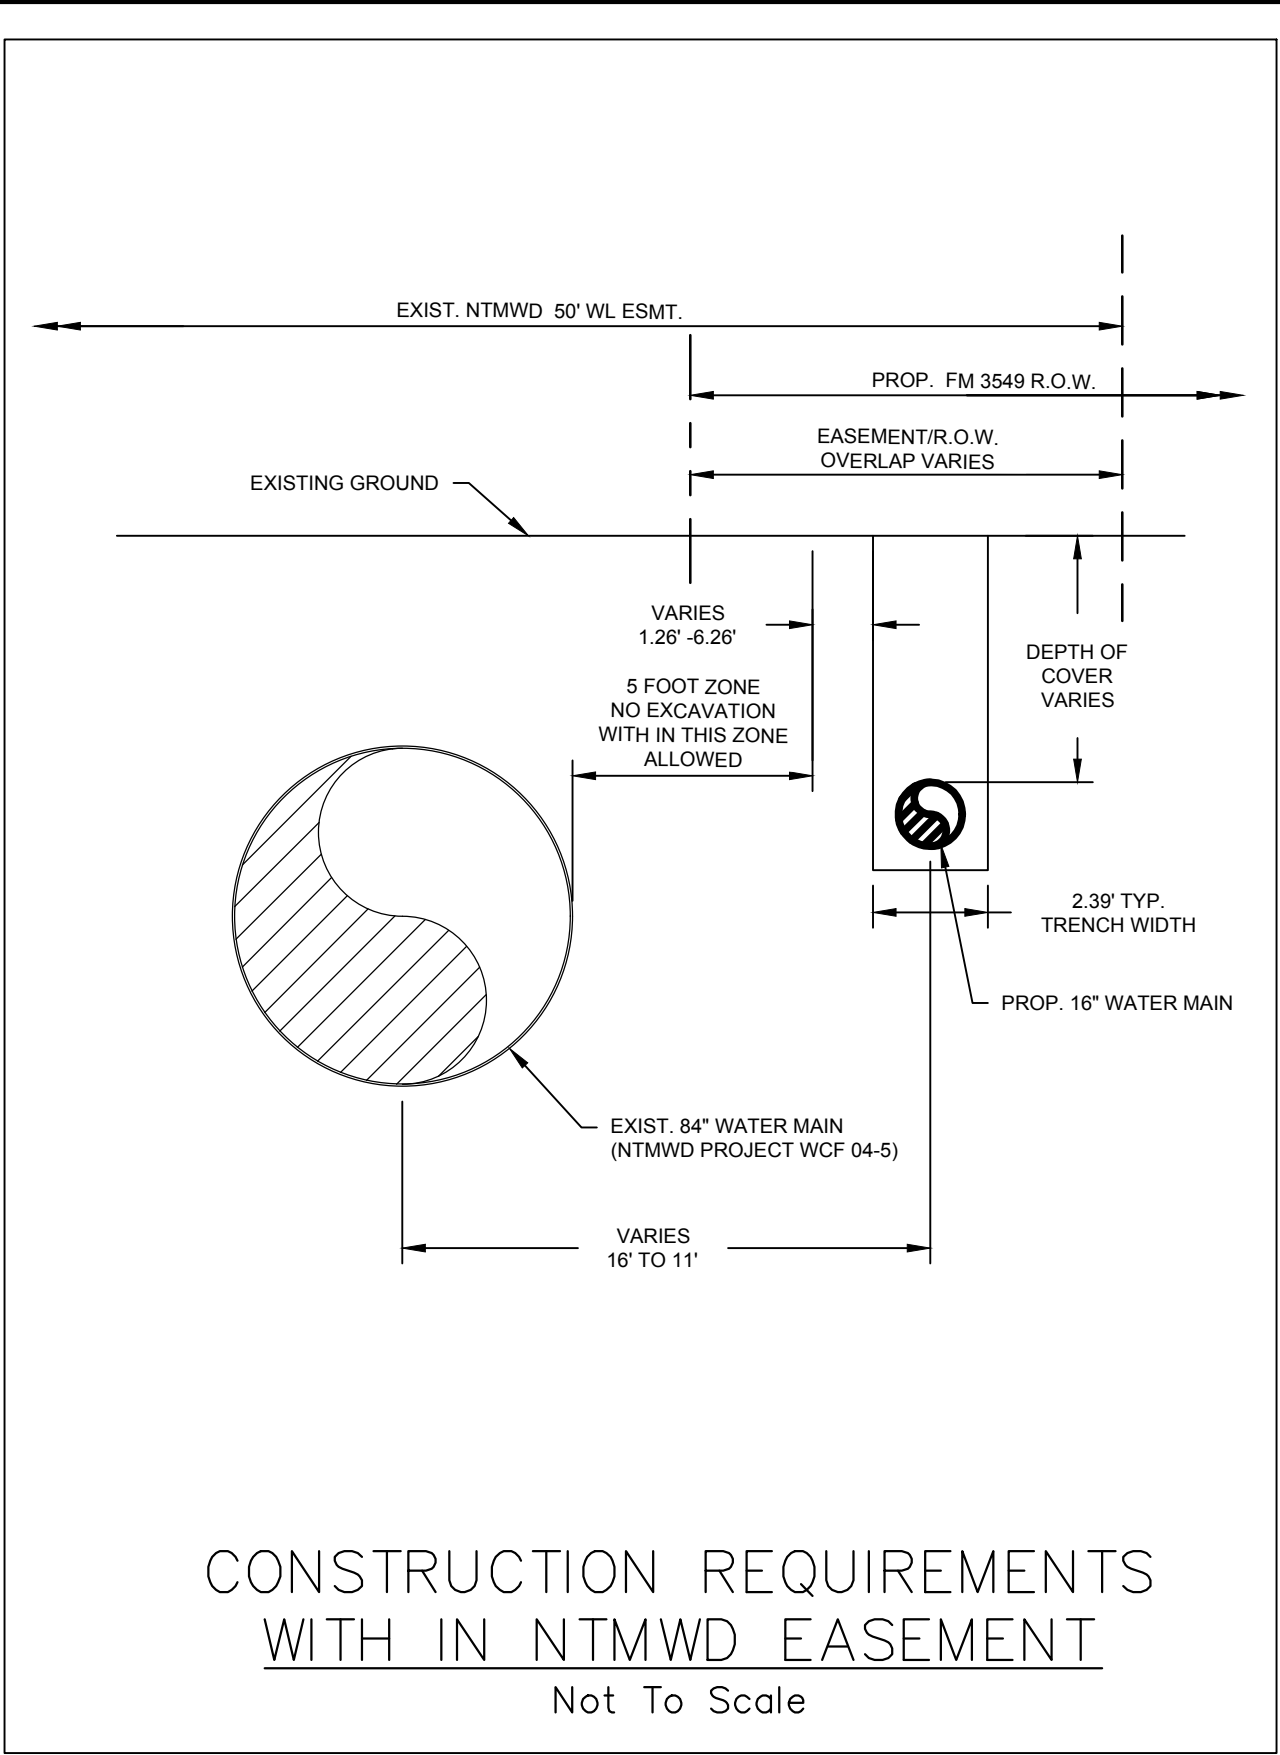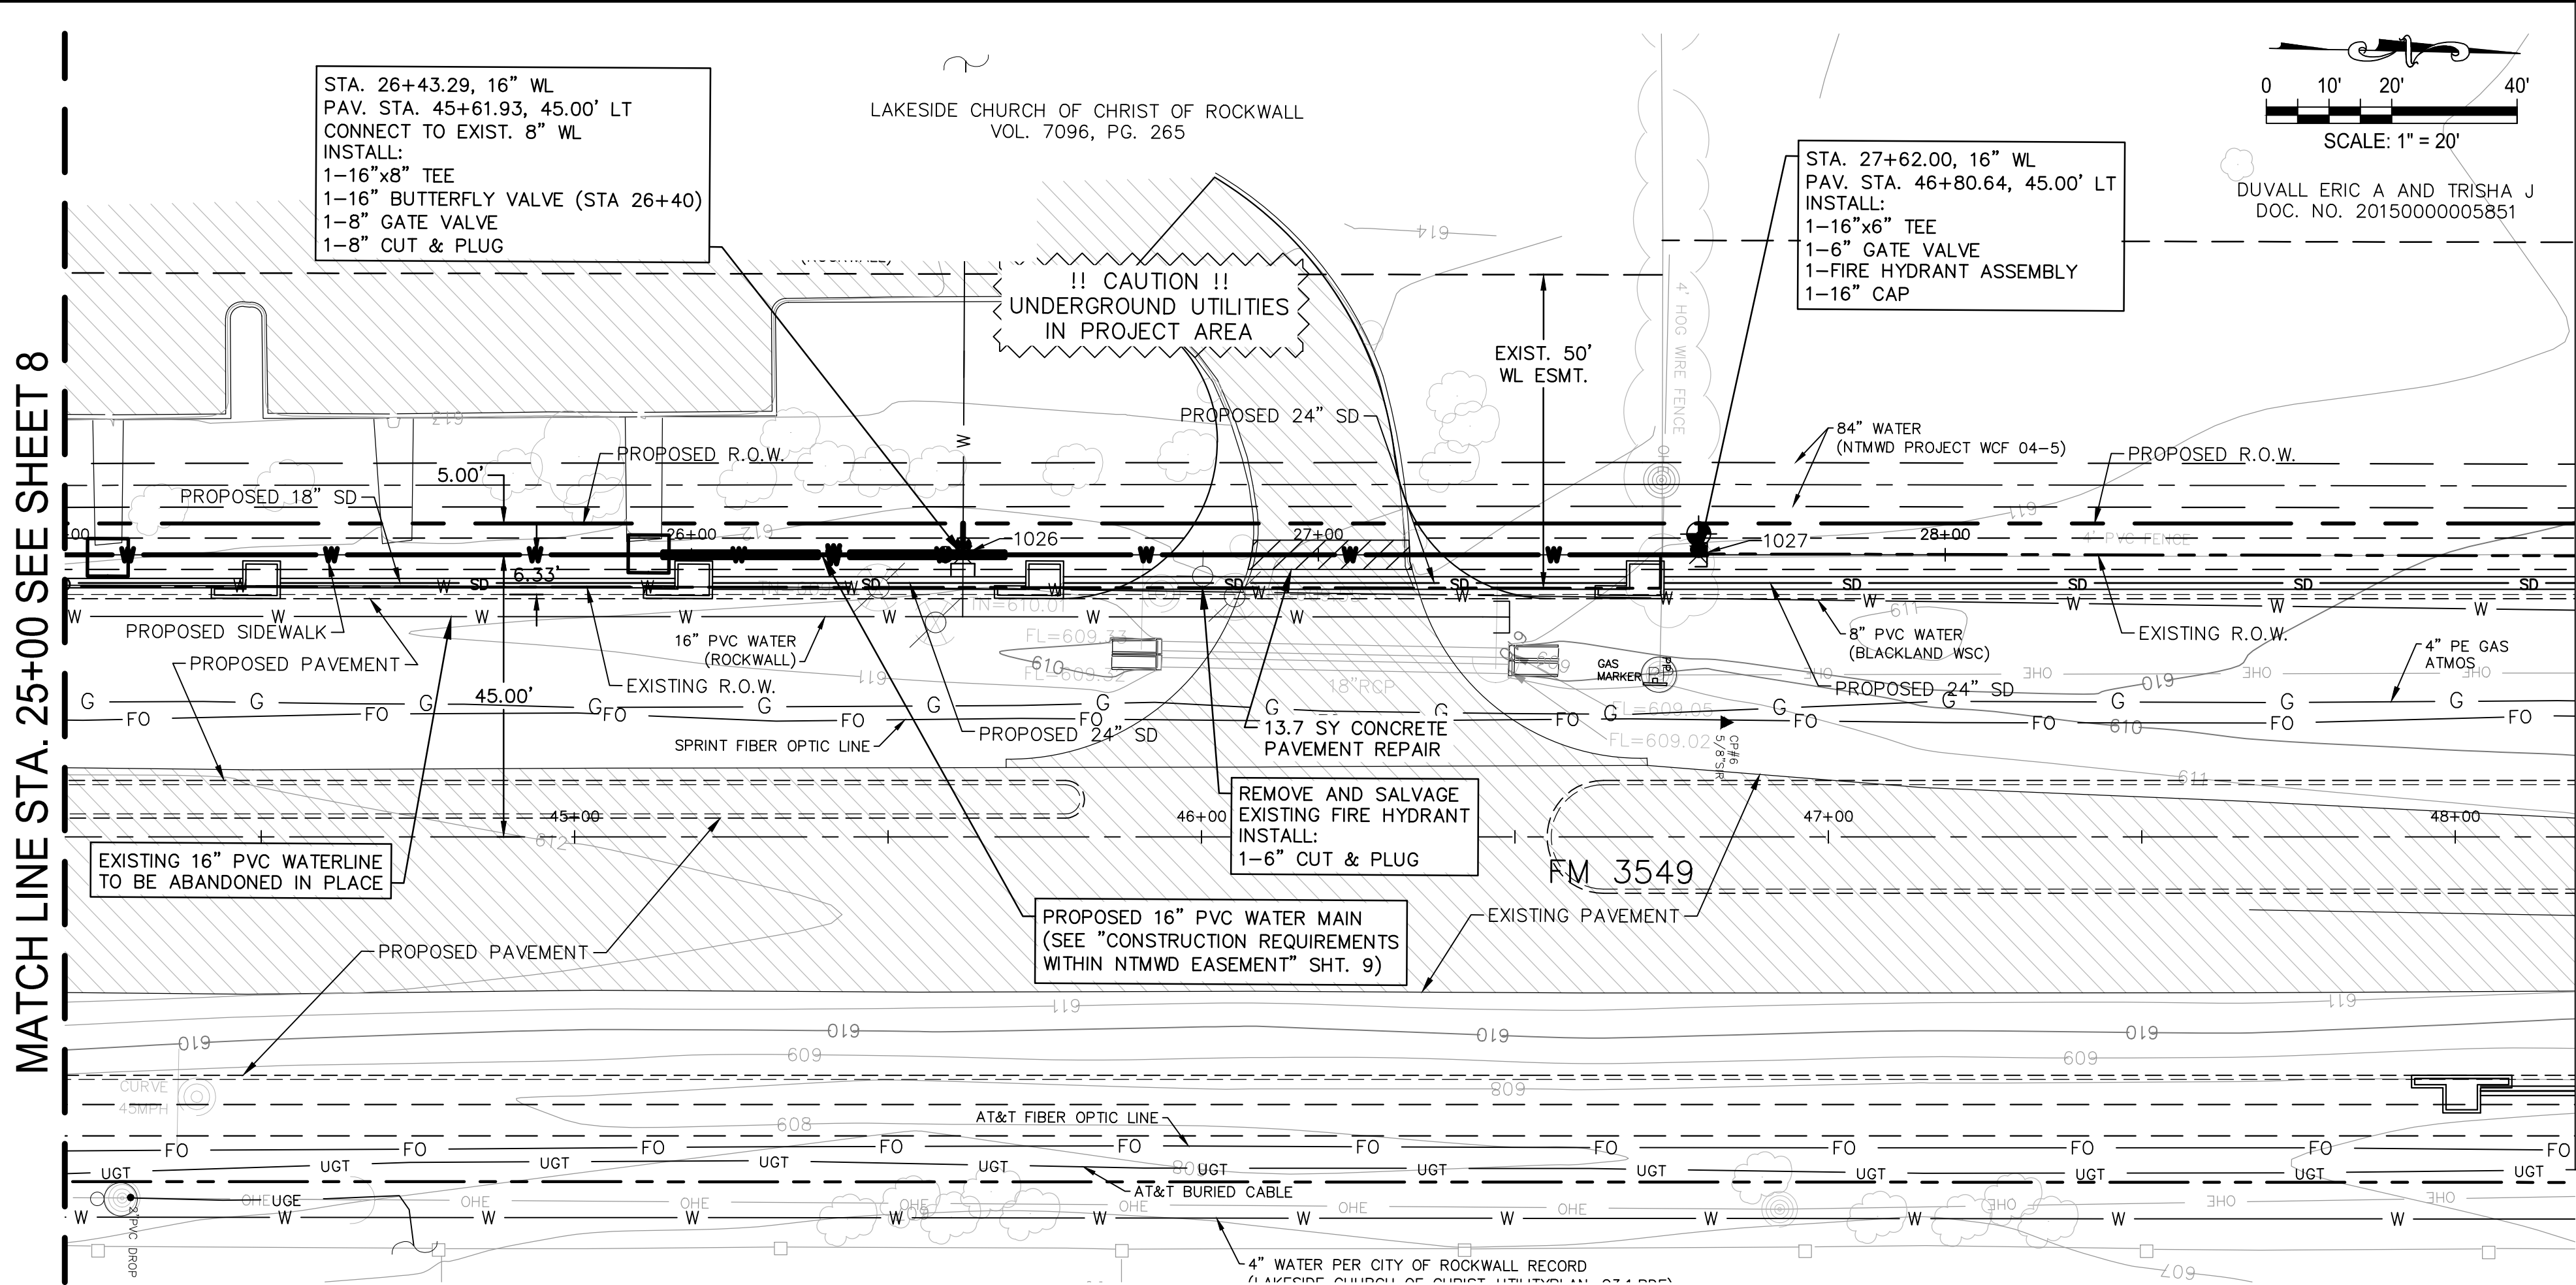

MATCH LINE STA. 25+00 SEE SHEET 8

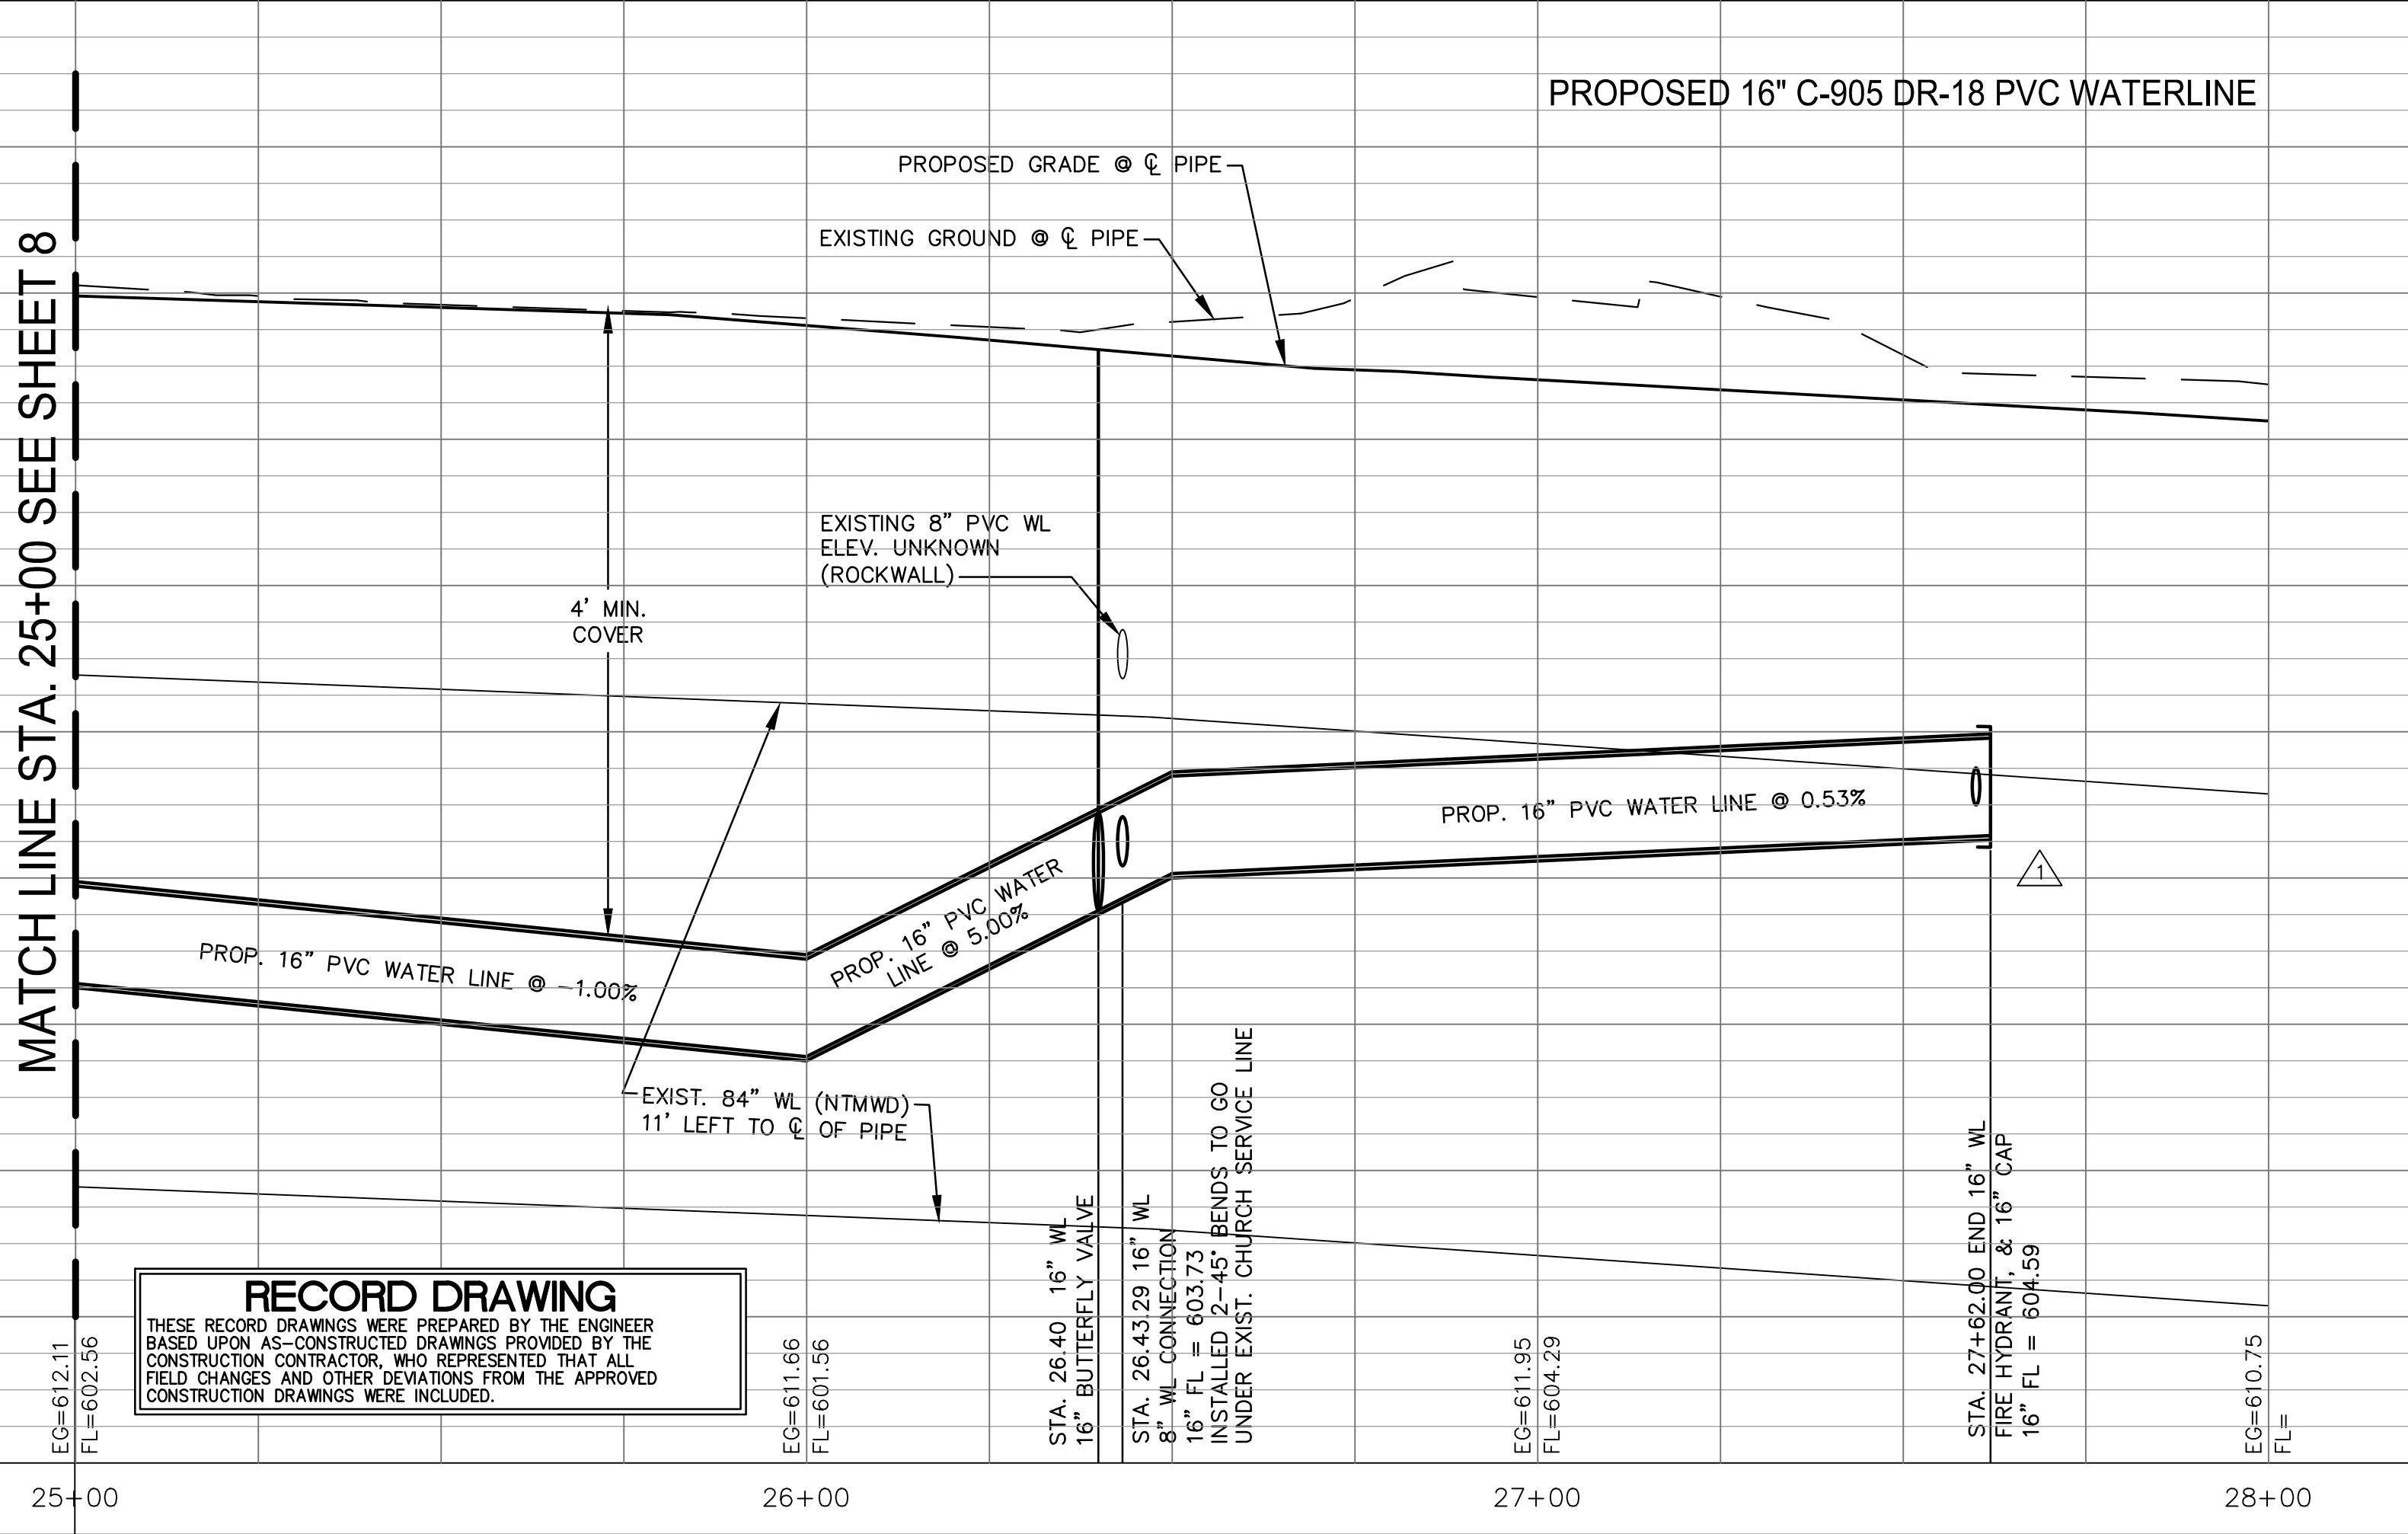

PROPOSED 16" C-905 DR-18 PVC WATERLINE

RESTRAINT LENGTH REQUIREMENTS FOR PIPELINE<sup>3</sup>

| Station         | Fitting Type    | Pipe Material | Nominal Size | Bend Angle | Branch Size | Restraint Length <sup>1</sup> |
|-----------------|-----------------|---------------|--------------|------------|-------------|-------------------------------|
| STA.0+75.75 WL  | Horizontal Bend | PVC           | 16           | 45         |             | 21 ft                         |
| STA.3+40.00 WL  | Tee             | PVC           | 16           |            | 6           | 20 ft                         |
| STA.7+40.00 WL  | Tee             | PVC           | 16           |            | 6           | 20 ft                         |
| STA.8+41.06 WL  | Horizontal Bend | PVC           | 16           | 45         |             | 21 ft                         |
| STA.8+55.18 WL  | Horizontal Bend | PVC           | 16           | 45         |             | 21 ft                         |
| STA.8+70.20 WL  | Dead End/Valve  | PVC           | 16           |            |             | 142 ft                        |
| STA.10+25.22 WL | Dead End/Valve  | PVC           | 16           |            |             | 142 ft                        |
| STA.10+35.22 WL | Horizontal Bend | PVC           | 16           | 45         |             | 21 ft                         |
| STA.10+50.73 WL | Horizontal Bend | PVC           | 16           | 45         |             | 21 ft                         |
| STA.10+61.00 WL | Tee             | PVC           | 16           |            | 6           | 20 ft                         |
| STA.13+03.00 WL | Tee             | PVC           | 16           |            | 6           | 20 ft                         |
| STA.14+40.66 WL | Tee             | PVC           | 16           |            | 12          | 20 ft                         |
| STA.14+40.66 WL | Dead End/Valve  | PVC           | 12           |            |             | 110 ft                        |
| STA.14+40.66 WL | Dead End/Valve  | PVC           | 16           |            |             | 142 ft                        |
| STA.14+40.66 WL | Horizontal Bend | PVC           | 12           | 45         |             | 17 ft                         |
| STA.14+40.66 WL | Horizontal Bend | PVC           | 12           | 45         |             | 17 ft                         |
| STA.15+70.61 WL | Tee             | PVC           | 16           |            | 6           | 20 ft                         |
| STA.16+76.06 WL | Horizontal Bend | PVC           | 16           | 45         |             | 21 ft                         |
| STA.16+90.22 WL | Horizontal Bend | PVC           | 16           | 45         |             | 21 ft                         |
| STA.19+61.86 WL | Tee             | PVC           | 16           |            | 6           | 20 ft                         |
| STA.19+61.86 WL | Dead End/Valve  | PVC           | 16           |            |             | 142 ft                        |
| STA.23+11.19 WL | Tee             | PVC           | 16           |            | 8           | 20 ft                         |
| STA.23+35.00 WL | Tee             | PVC           | 16           |            | 8           | 20 ft                         |
| STA.23+60.66 WL | Tee             | PVC           | 16           |            | 6           | 20 ft                         |
| STA.26+43.29 WL | Tee             | PVC           | 16           |            | 8           | 20 ft                         |
| STA.26+43.29 WL | Dead End/Valve  | PVC           | 16           |            |             | 142 ft                        |
| STA.27+62.00 WL | Tee             | PVC           | 16           |            | 6           | 20 ft                         |
| STA.27+62.00 WL | Dead End        | PVC           | 16           |            |             | 142 ft                        |

Notes:

- 1.- Minimum restrained length to either side of the fitting or valve.
- 2.- All FH assemblies shall be fully restrained from tee to FH barrel.
- 3.- Assuming a maximum test pressure of 150psi.



F.M. 3549 16" WATERLINE  
RELOCATION PROJECT

WATER LINE PLAN AND PROFILE  
STA. 25+00 TO STA. 28+00

SHEET NO.

9

OF 14 SHEETS

FILE NO. RW-WL-PP  
PROJECT NO. 100049910


| DESIGNED BY: | EJH            |
|--------------|----------------|
| DRAWN BY:    | PMH            |
| CHECKED BY:  | FCG            |
| APPROVED BY: | FCG            |
| DATE:        | MARCH 22, 2017 |
| REVISION     |                |
| NO.          |                |
| BY           |                |
| DATE         |                |

ATKINS


18383 PRESTON RD., SUITE 500  
DALLAS, TEXAS 75252 - (972) 818-7715  
TBP REG. NO. F-474



Jan 02, 2018 - 5:59pm mha3082 K:\Projects\14100049910-Rockwall\2.0 Drawings\Sheets\_RW-WL-ES.dwg

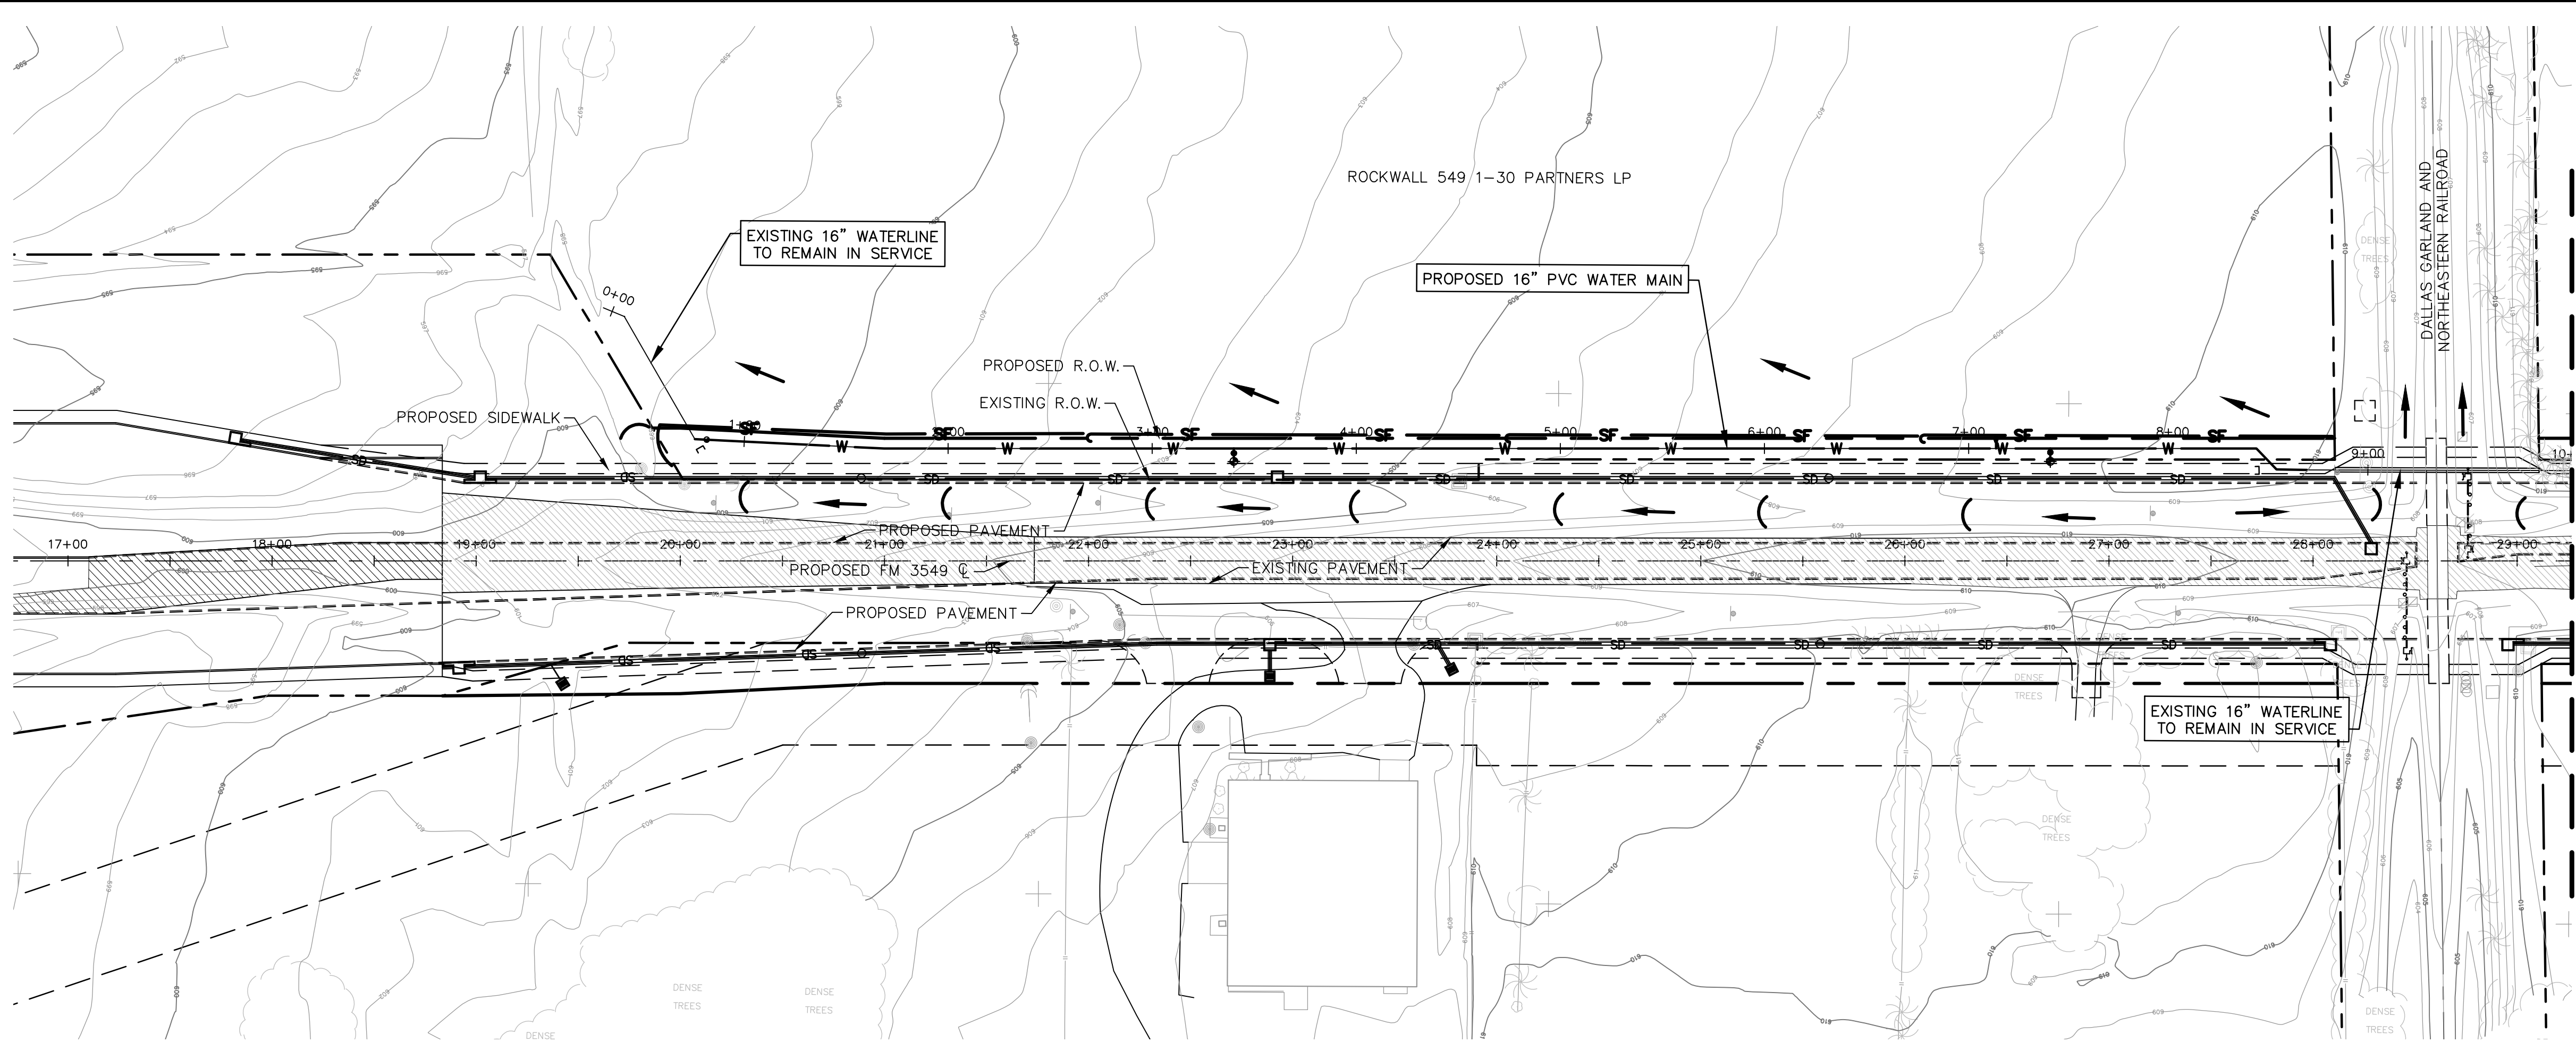


MATCH LINE STA. 10+00 SEE THIS SHEET

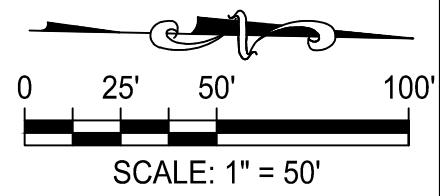


LEGEND

- INLET PROTECTION
- SILT FENCE OR EROSION CONTROL LOGS
- FLOW DIRECTION ARROW

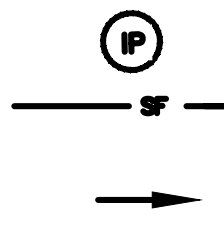

MATCH LINE STA. 10+00 SEE THIS SHEET

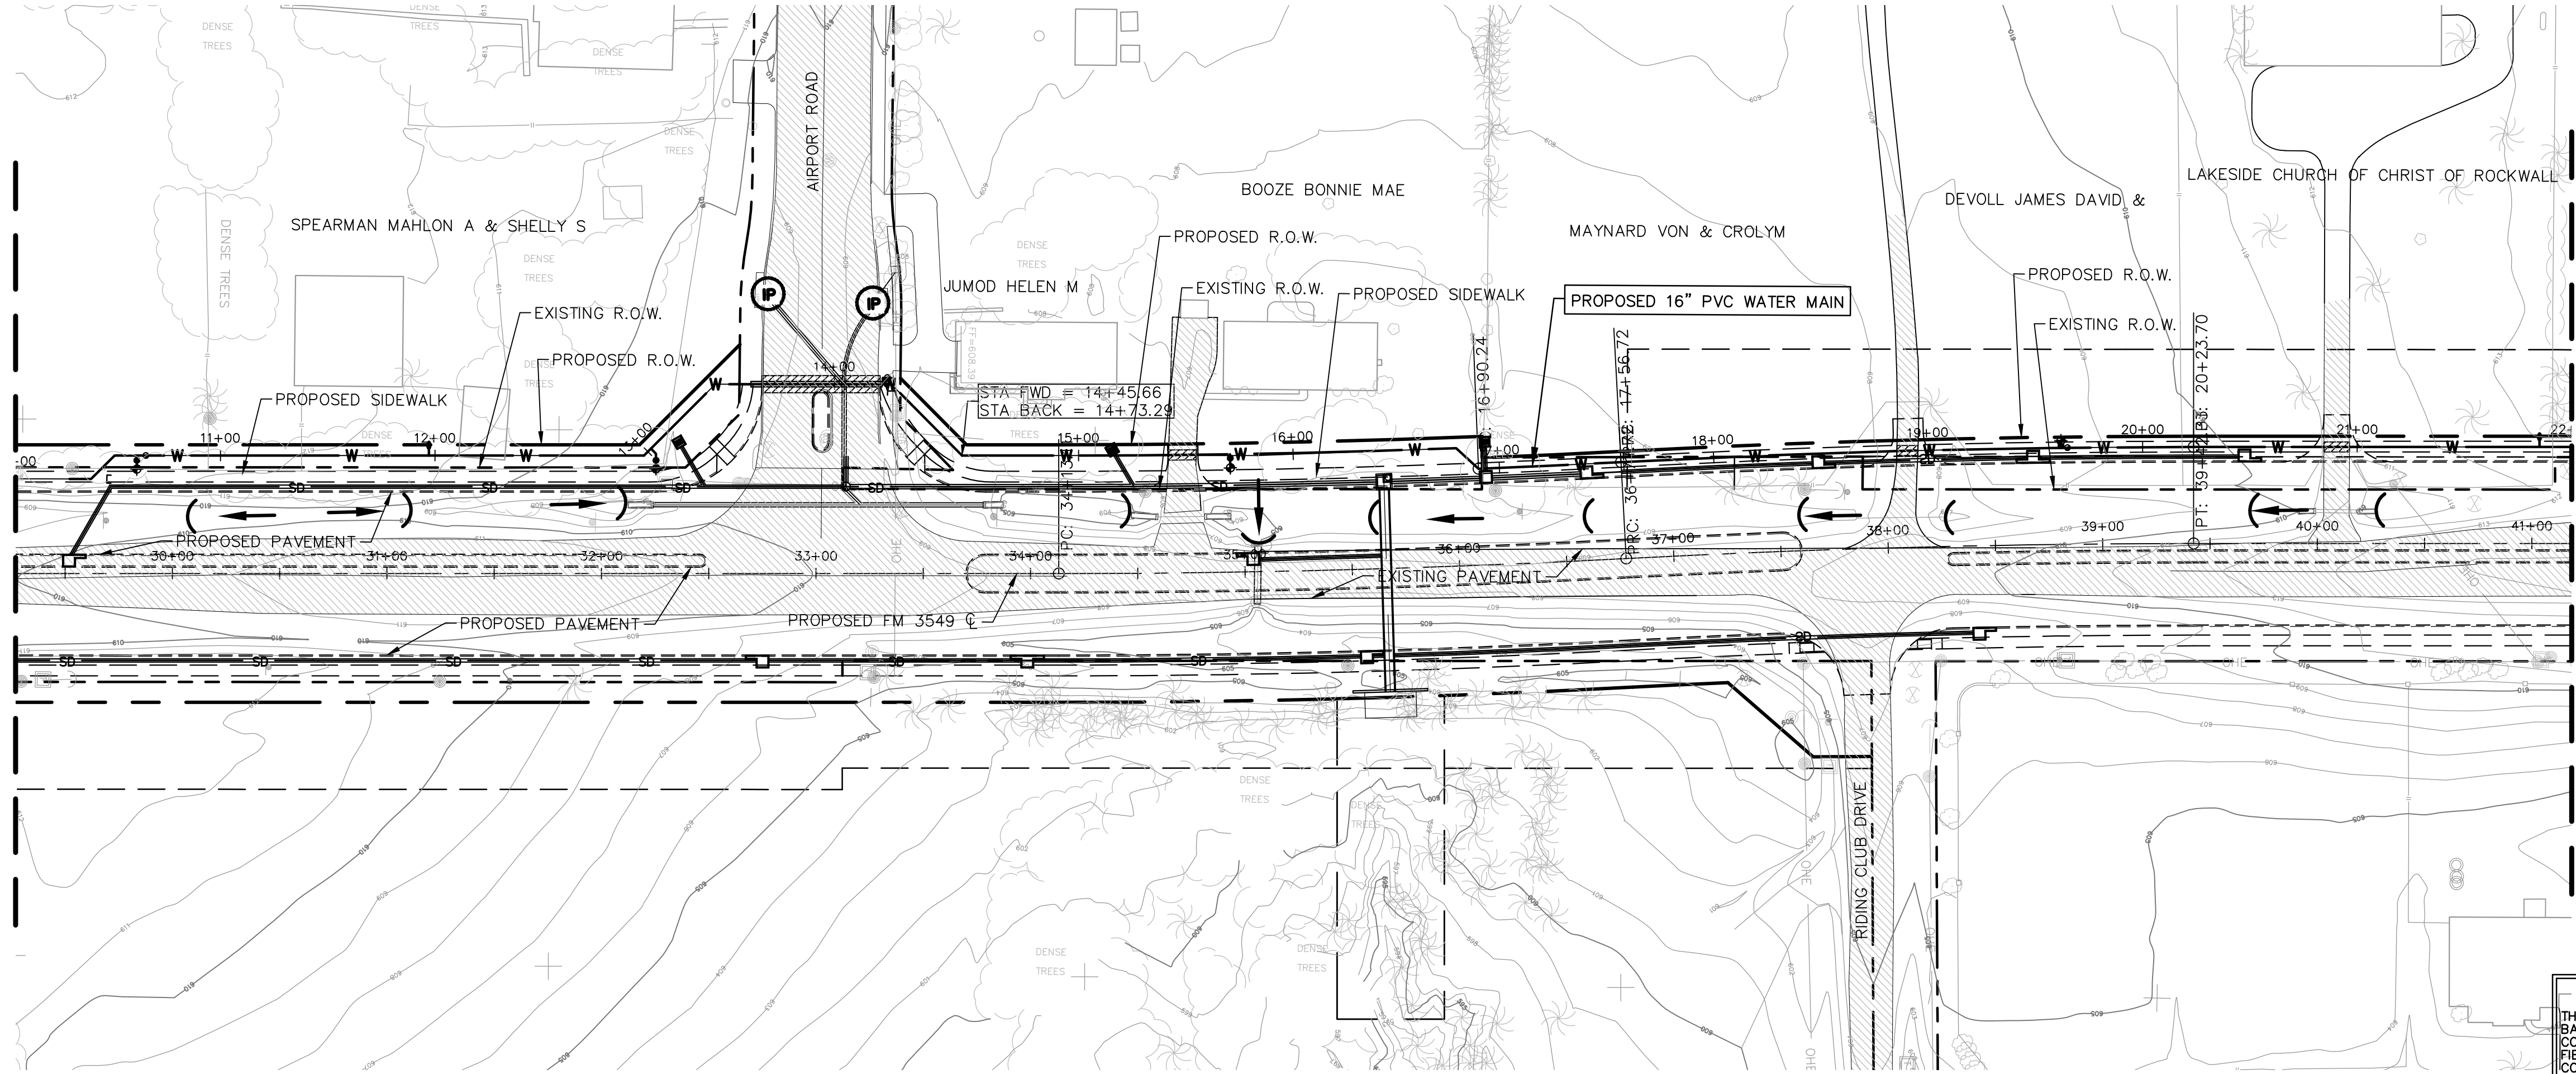

MATCH LINE STA. 22+00 SEE SHEET 11

**RECORD DRAWING**  
THESE RECORD DRAWINGS WERE PREPARED BY THE ENGINEER BASED UPON AS-CONSTRUCTED DRAWINGS PROVIDED BY THE CONSTRUCTION CONTRACTOR, WHO REPRESENTED THAT ALL FIELD CHANGES AND OTHER DEVIATIONS FROM THE APPROVED CONSTRUCTION DRAWINGS WERE INCLUDED.

**F.M. 3549 16" WATERLINE  
RELOCATION PROJECT**

EROSION CONTROL PLAN  
STA. 1+00 TO STA. 22+00

SHEET NO. 10  
OF 14 SHEETS  
FILE NO. RW-WL-ES  
PROJECT NO. 100049910



**ATKINS**

18383 PRESTON RD., SUITE 500  
DALLAS, TEXAS 75252 - (972) 818-7715  
TBP REG. NO. F-474



DESIGNED BY: EJM  
DRAWN BY: PMH  
CHECKED BY: FCG  
APPROVED BY: FCG  
DATE: MARCH 22, 2017

| NO. | REVISION | BY | DATE |
|-----|----------|----|------|
|     |          |    |      |
|     |          |    |      |
|     |          |    |      |
|     |          |    |      |



Jan 02, 2018 - 5:59pm mha3082 K:\Projects\141\100049910-Rockwall\2.0 Drawings\Sheets\ RW-WL-ES.dwg

MATCH LINE STA. 22+00 SEE SHEET 10

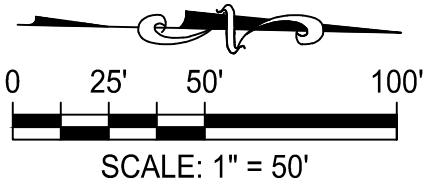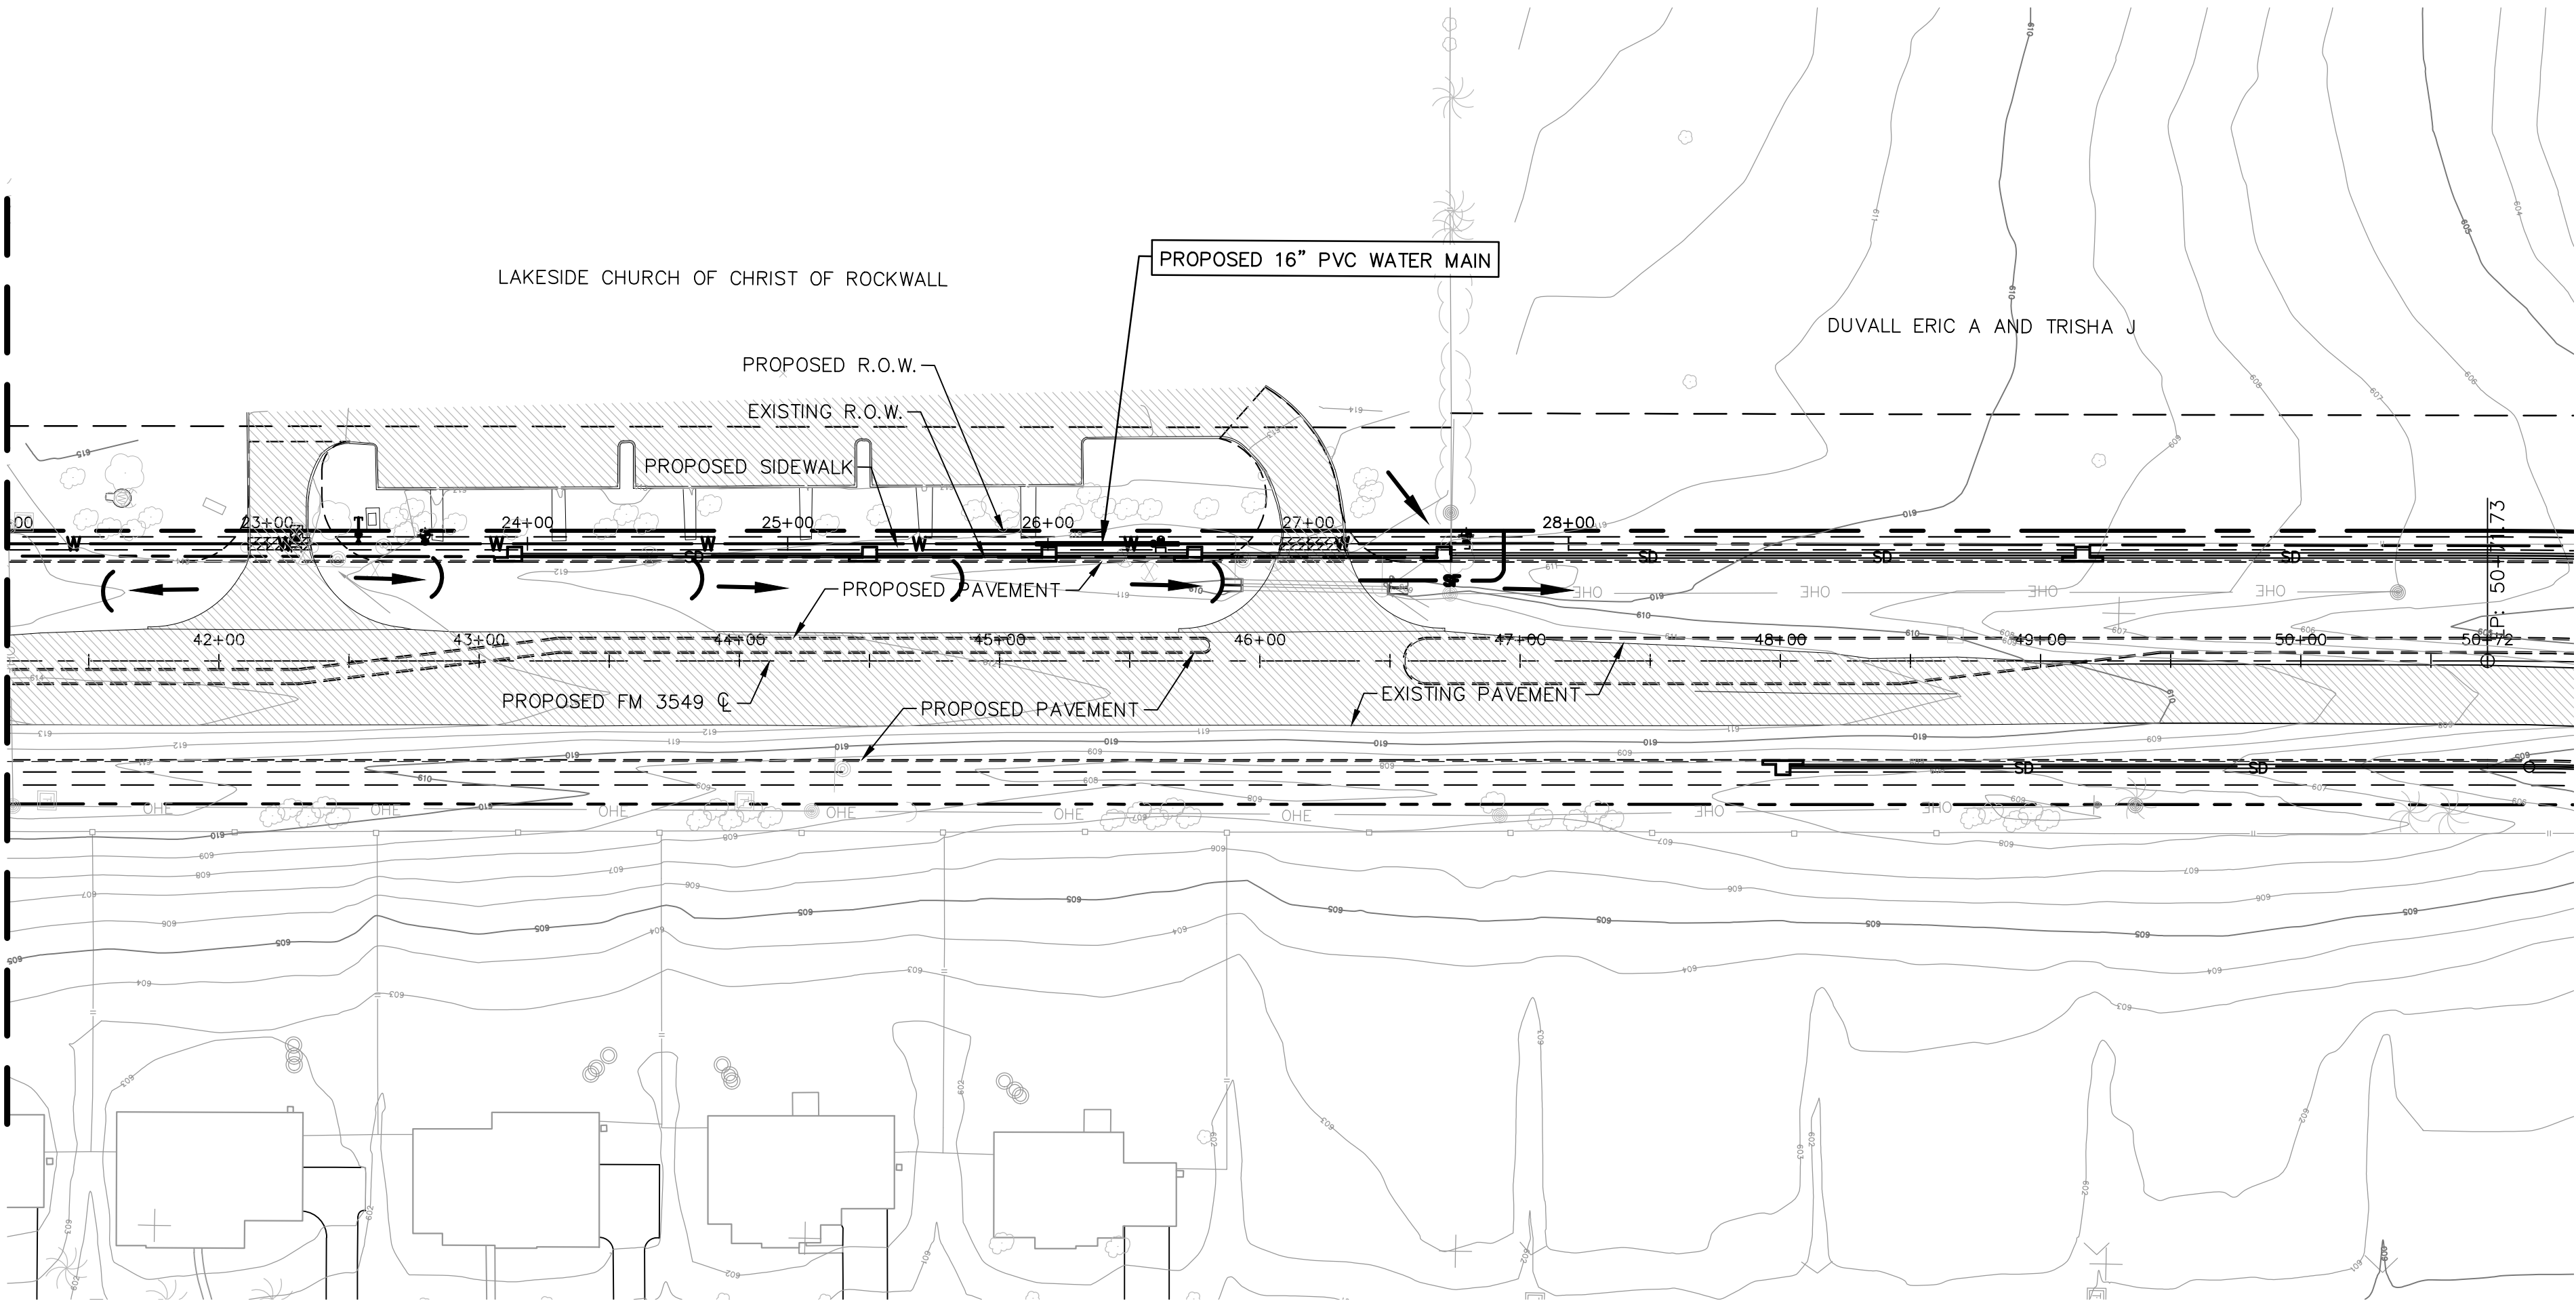

- LEGEND**
- INLET PROTECTION
  - SILT FENCE OR EROSION CONTROL LOGS
  - FLOW DIRECTION ARROW

**RECORD DRAWING**  
THESE RECORD DRAWINGS WERE PREPARED BY THE ENGINEER  
BASED UPON AS-CONSTRUCTED DRAWINGS PROVIDED BY THE  
CONSTRUCTION CONTRACTOR, WHO REPRESENTED THAT ALL  
FIELD CHANGES AND OTHER DEVIATIONS FROM THE APPROVED  
CONSTRUCTION DRAWINGS WERE INCLUDED.

|              |                |
|--------------|----------------|
| DESIGNED BY: | EJH            |
| DRAWN BY:    | PMH            |
| CHECKED BY:  | FCG            |
| APPROVED BY: | FCG            |
| DATE:        | MARCH 22, 2017 |

**ATKINS**  
18383 PRESTON RD., SUITE 500  
DALLAS, TEXAS 75252 - (972) 818-7715  
TBP# REC. NO. F-474



|                                                       |                                                          |
|-------------------------------------------------------|----------------------------------------------------------|
| <b>F.M. 3549 16" WATERLINE<br/>RELOCATION PROJECT</b> | <b>EROSION CONTROL PLAN<br/>STA. 22+00 TO STA. 28+00</b> |
|-------------------------------------------------------|----------------------------------------------------------|

|                       |    |
|-----------------------|----|
| SHEET NO.             | 11 |
| OF 14 SHEETS          |    |
| FILE NO. RW-WL-ES     |    |
| PROJECT NO. 100049910 |    |



















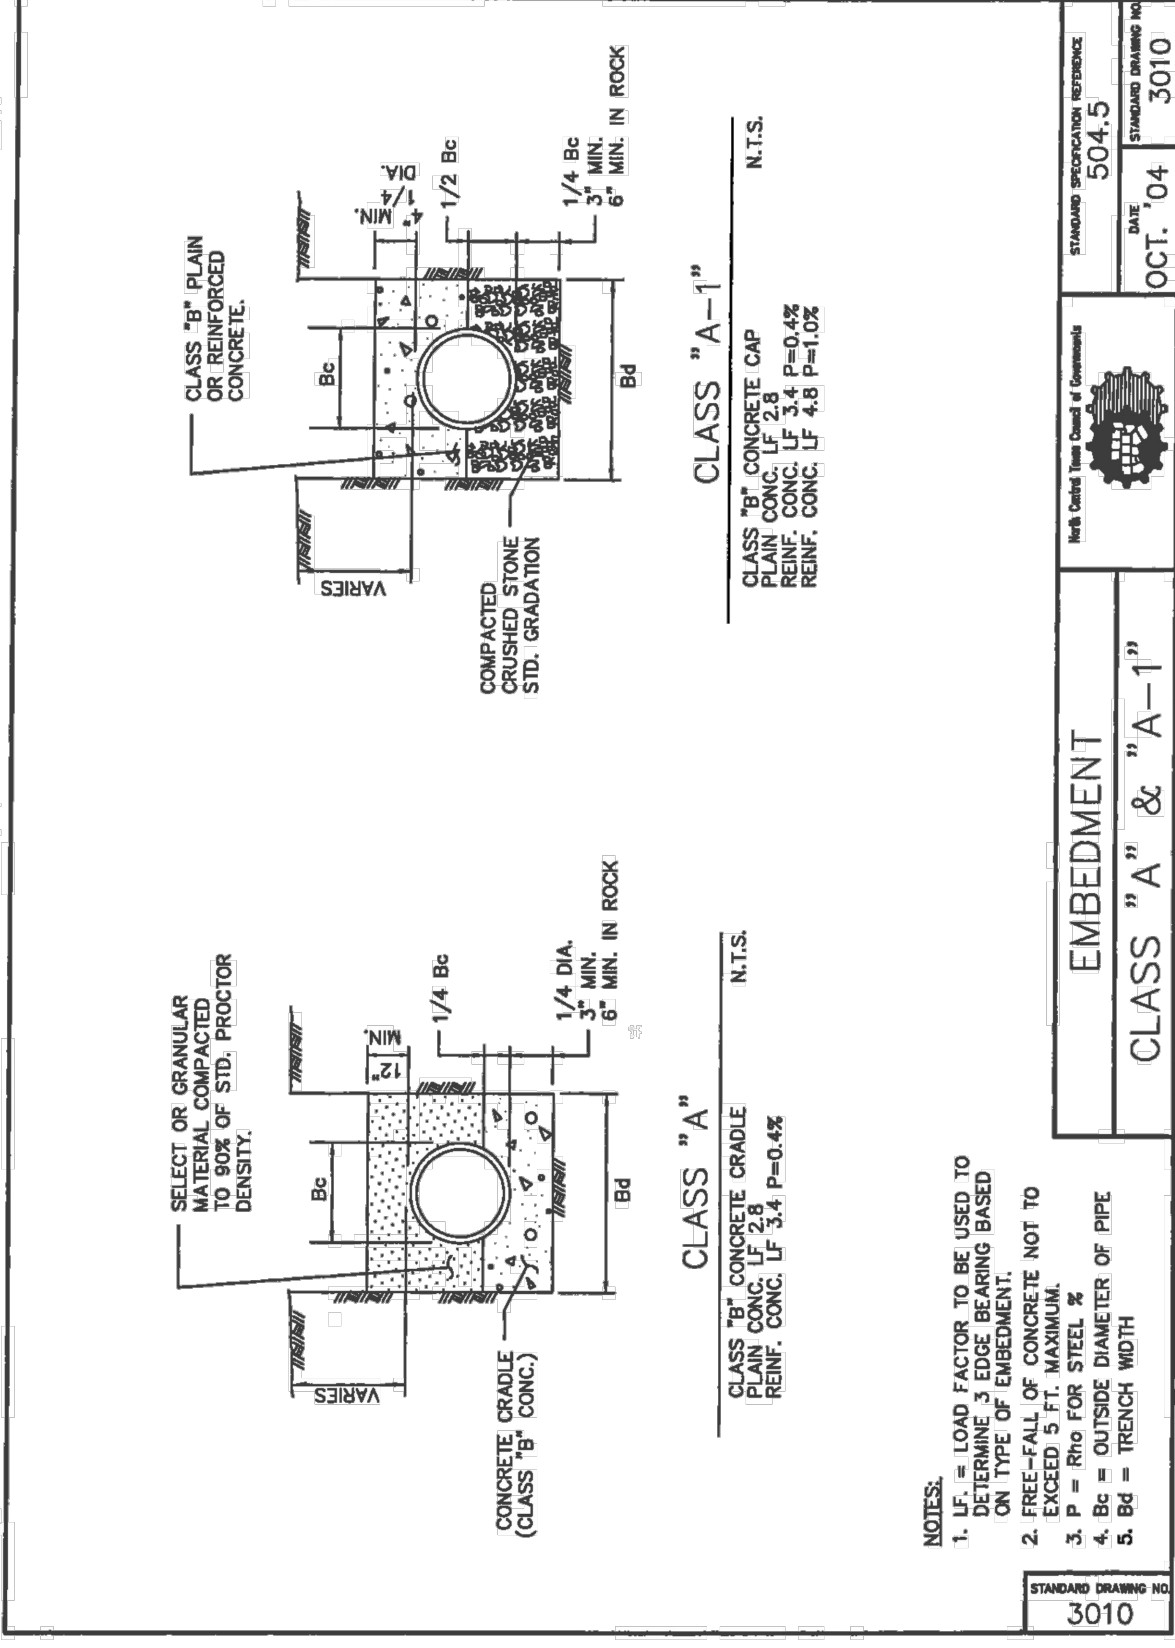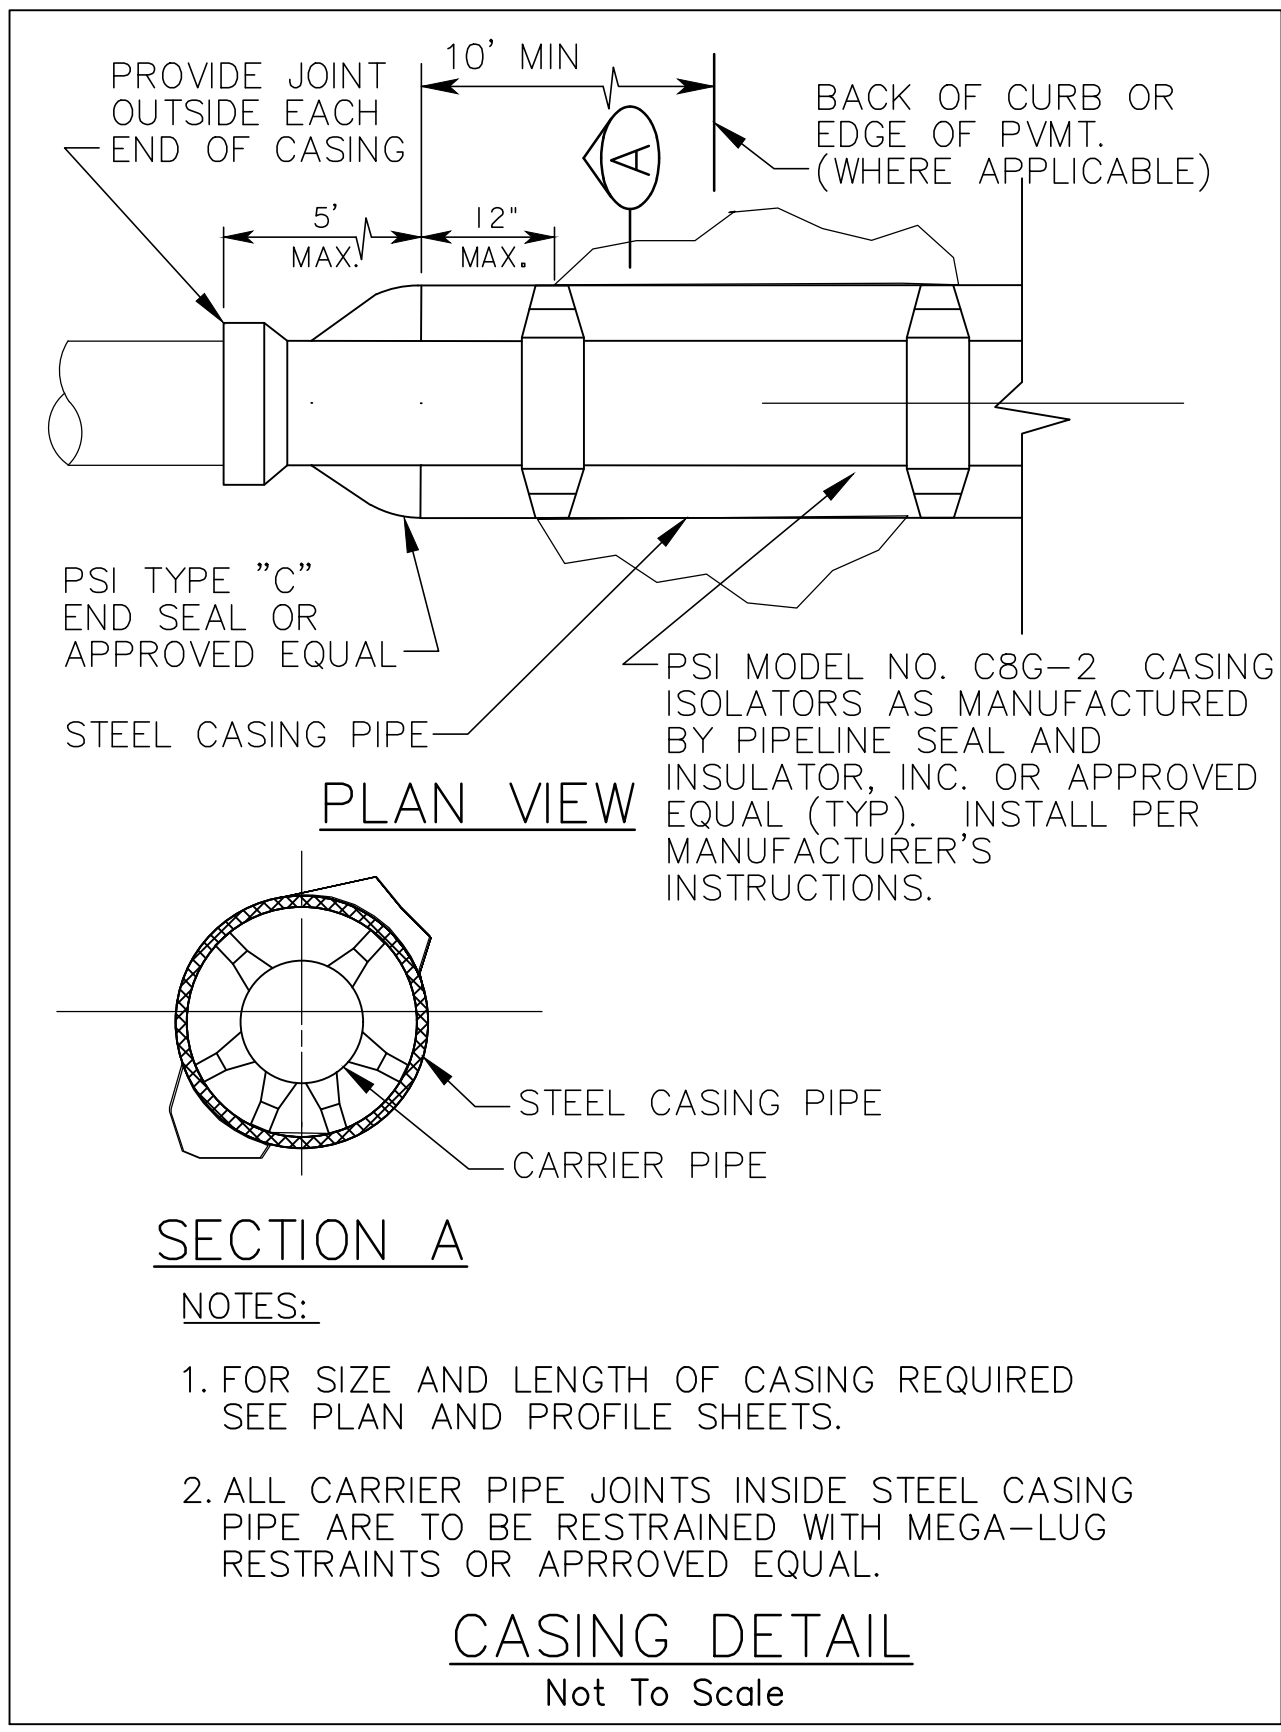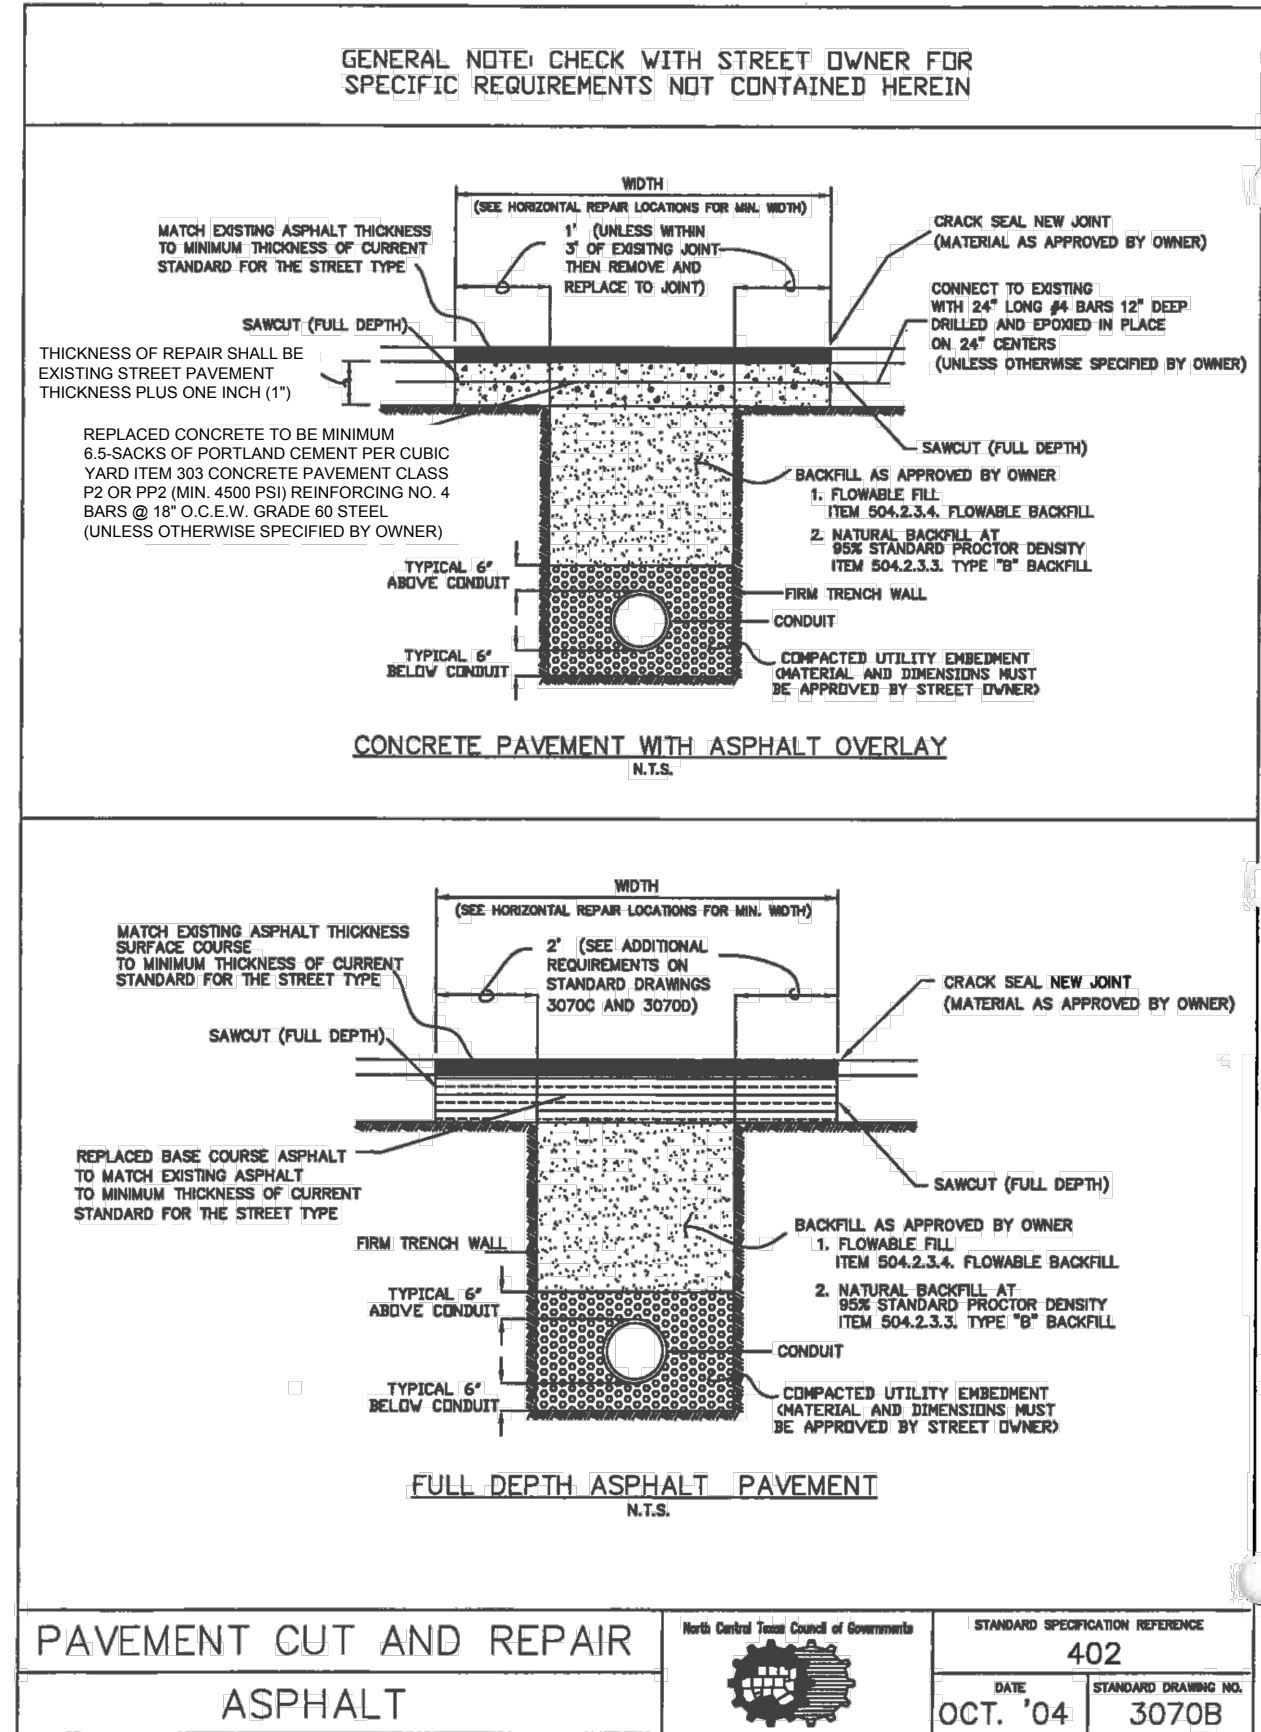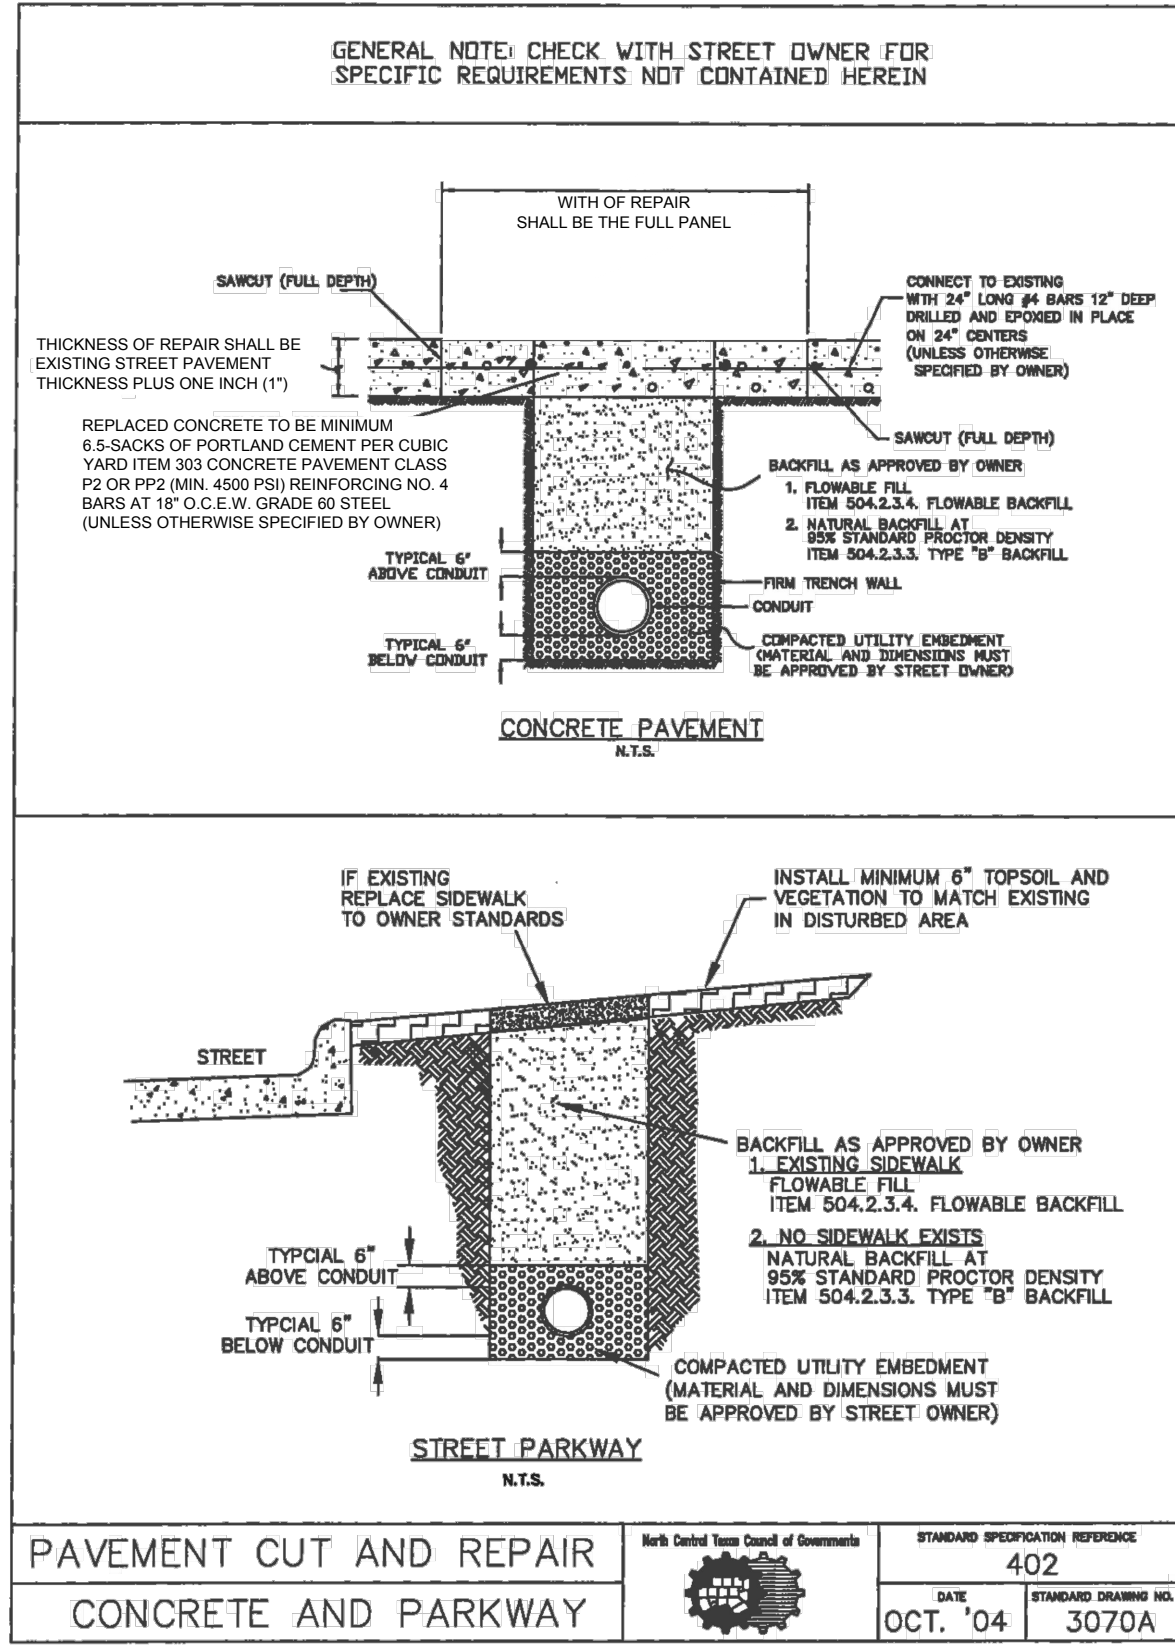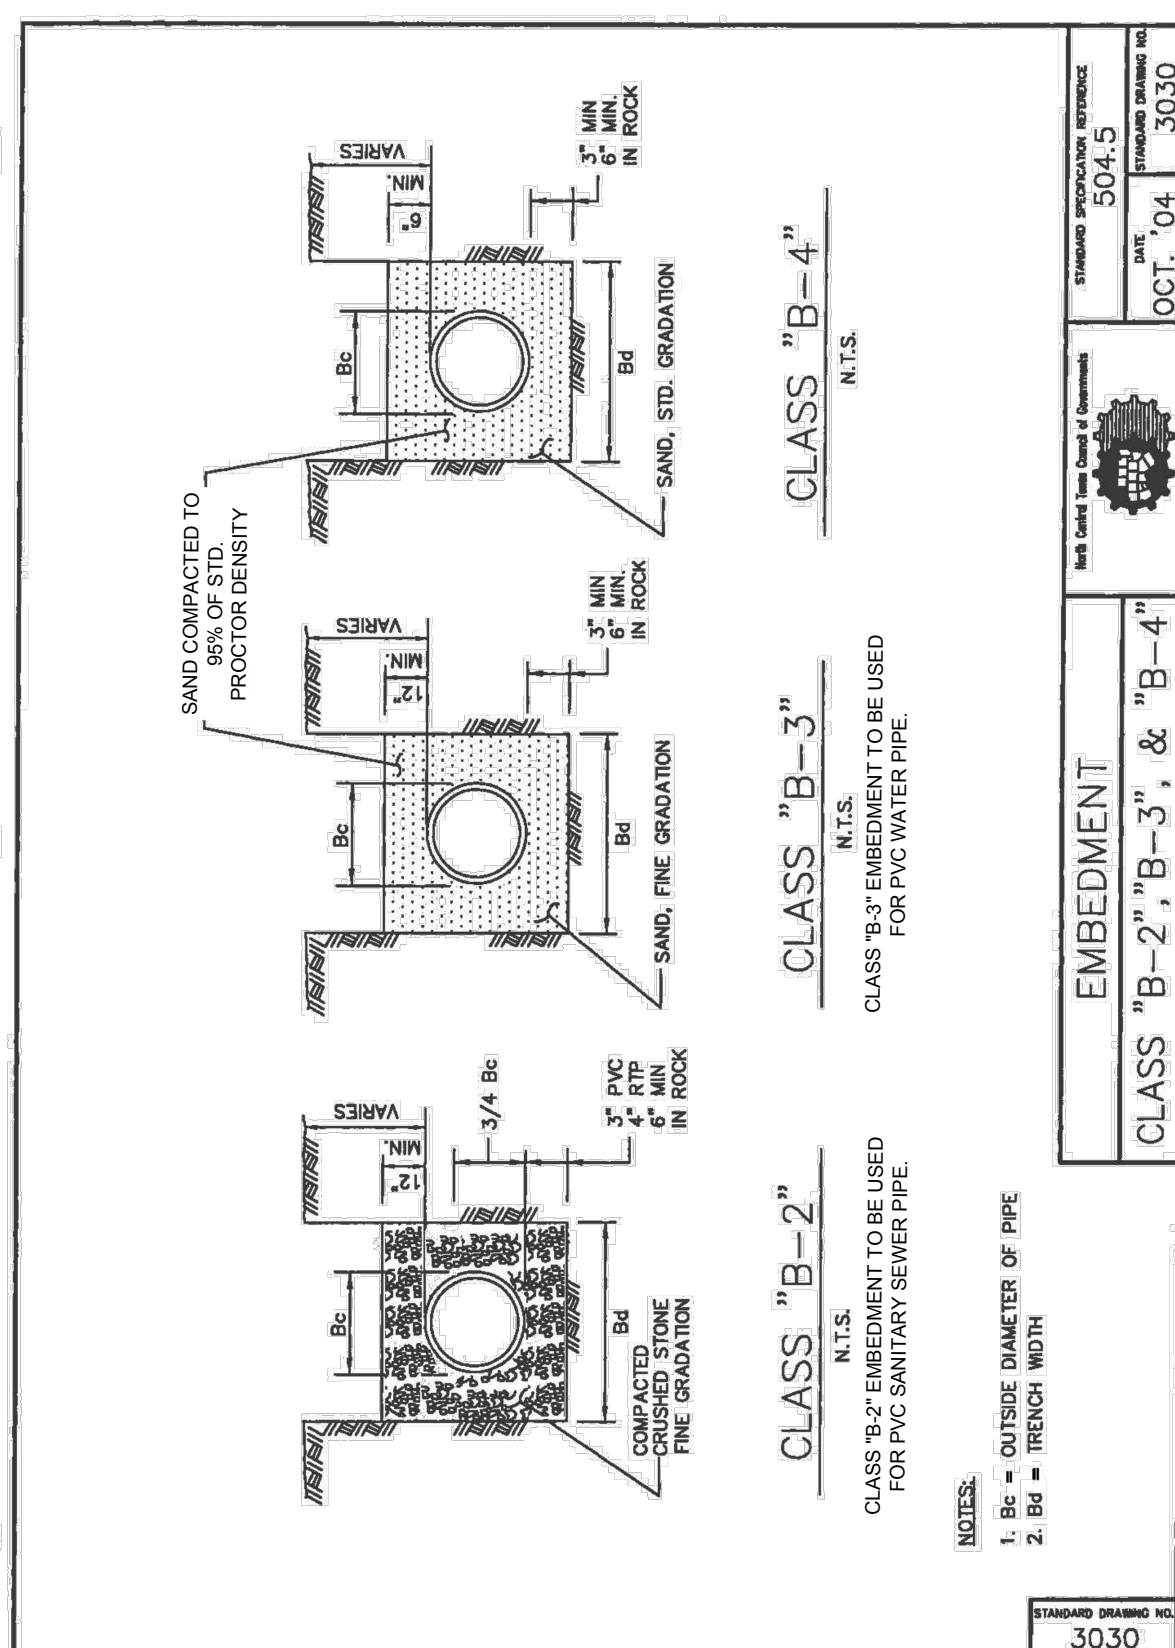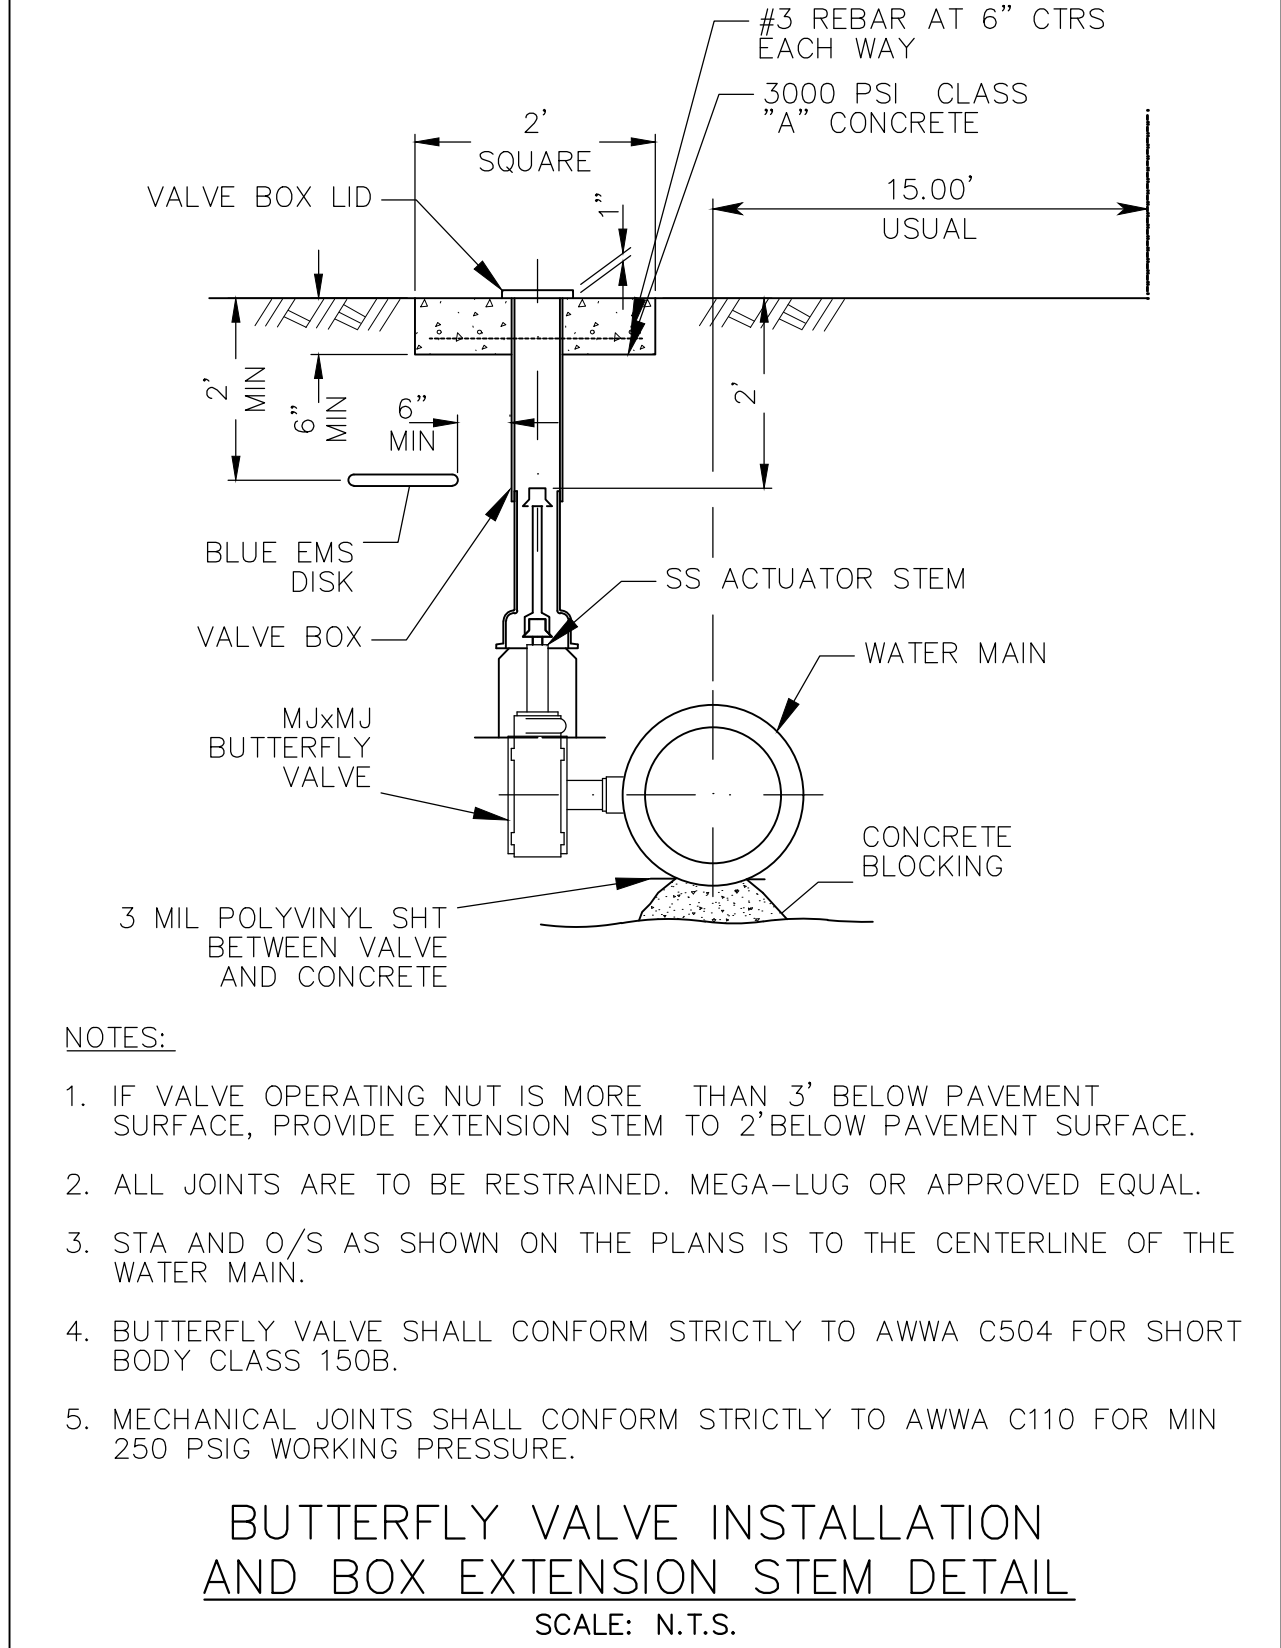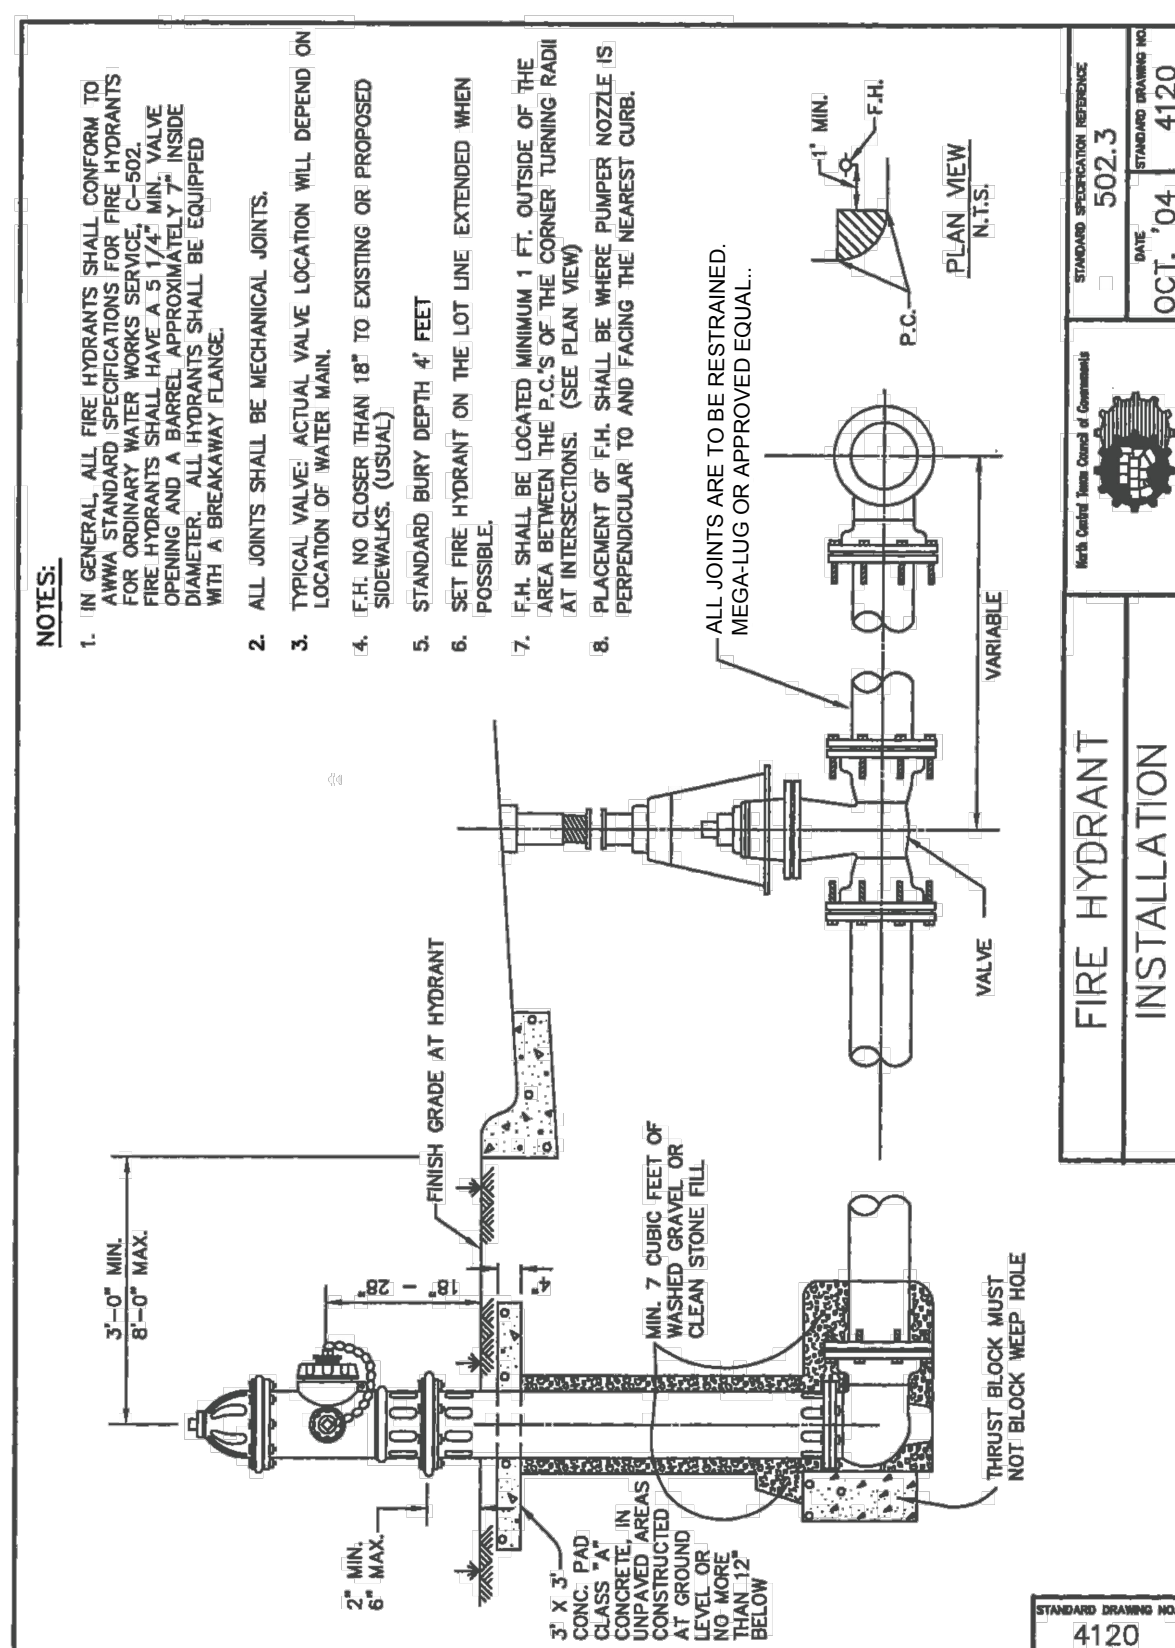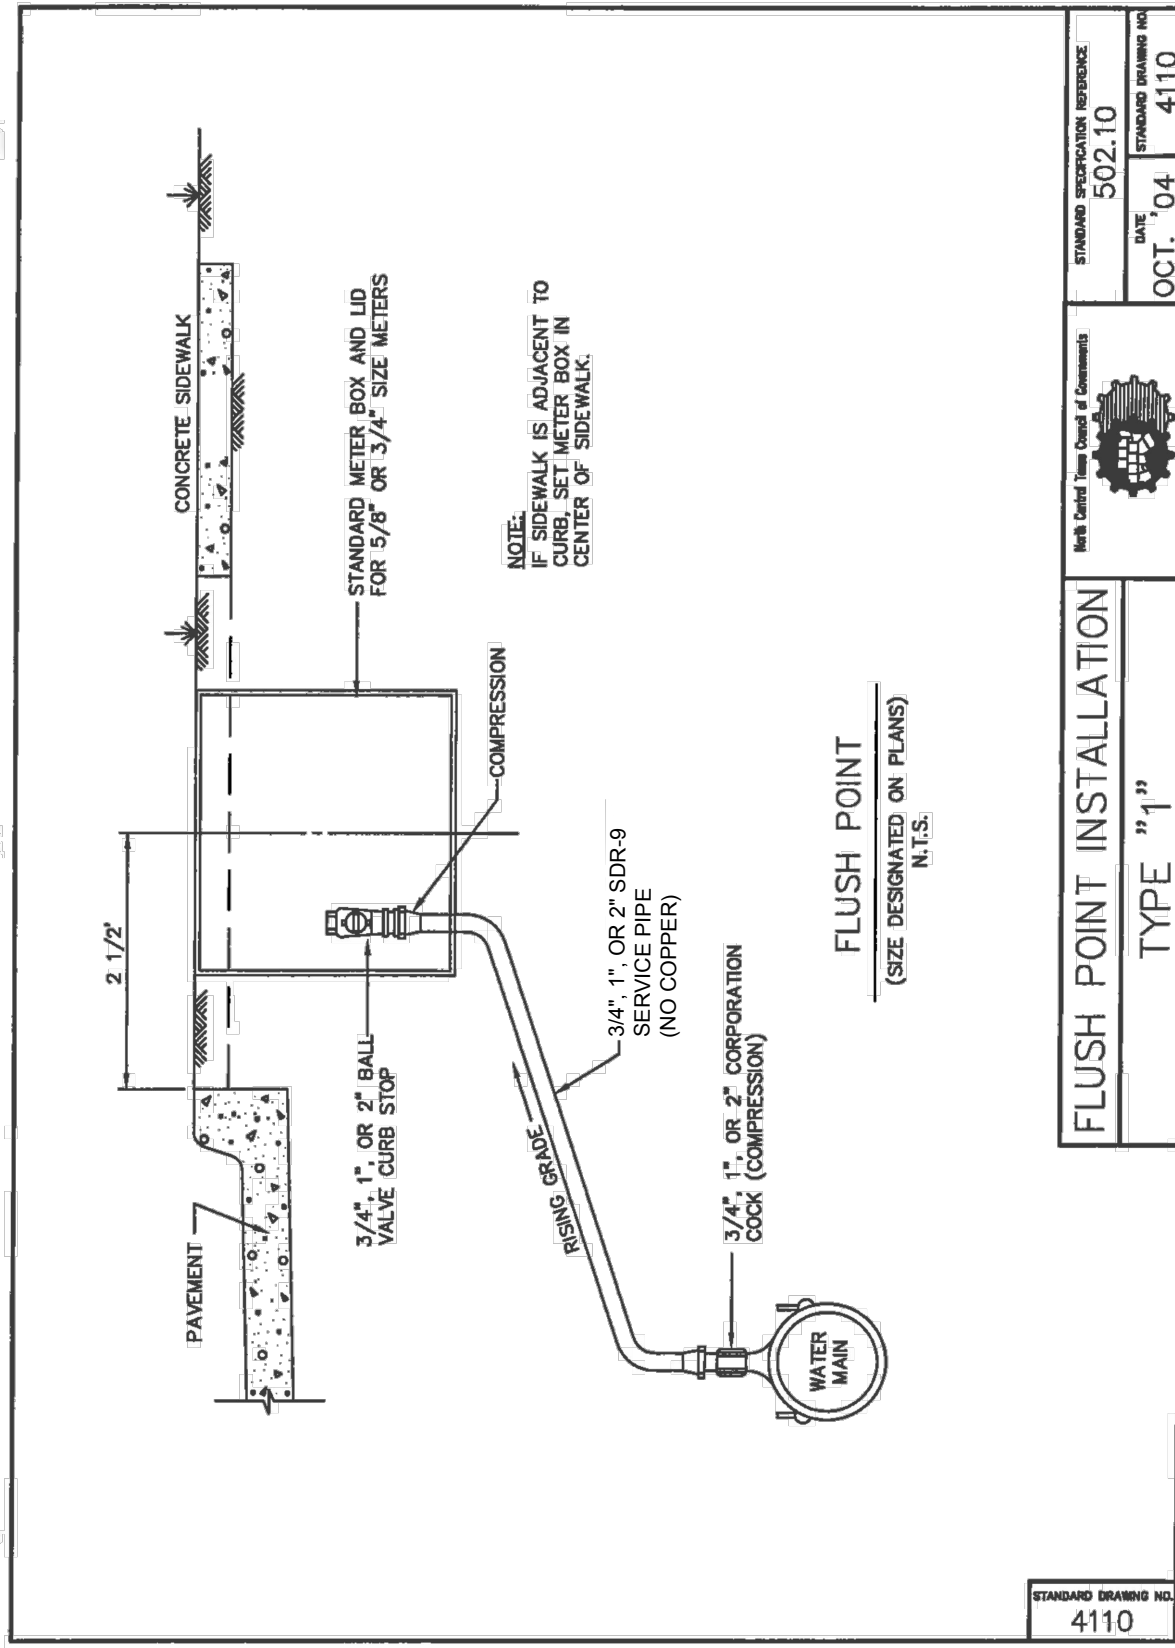

F.M. 3549 16" WATERLINE  
RELOCATION PROJECT  
WATER LINE DETAILS 2

