


DEVELOPMENT APPLICATION

City of Rockwall
Planning and Zoning Department
385 S. Goliad Street

PLANNING & ZONING CASE NO.
NOTE: THE APPLICATION IS NOT CONSIDERED ACCEPTED BY THE CITY UNTIL THE PLANNING DIRECTOR AND CITY ENGINEER HAVE SIGNED BELOW.
DIRECTOR OF PLANNING:

	Rockwall, Texas 75087	L	CITY ENGIN	EER:	
PLEASE CHECK THE A	PPROPRIATE BOX BELOW TO INDICATE THE TYPE	OF DEVELOPMEN	T REQUEST	[SELECT ONLY ONE BOX	7 :
PLATTING APPLICA MASTER PLAT (\$ PRELIMINARY PLAT (\$30 REPLAT (\$300.00 AMENDING OR MATERIAL PLAT REINSTATION SITE PLAN APPLICATION SITE PLAN (\$250	ATION FEES: \$100.00 + \$15.00 ACRE) 1 LAT (\$200.00 + \$15.00 ACRE) 1 0.00 + \$20.00 ACRE) 1 0 + \$20.00 ACRE) 1 MINOR PLAT (\$150.00) EMENT REQUEST (\$100.00)	ZONING A ZONING SPECIF PD DEV OTHER AI TREE F VARIAN NOTES: IN DETERM PER ACRE AI 2: A \$1,00,00	PPLICATION CHANGE (C	N FEES: (\$200.00 + \$15.00 ACRE) 1 RMIT (\$200.00 + \$15.00 ACI F PLANS (\$200.00 + \$15.00 I FEES:	RE) 182 ACRE) 1 6 (\$100.00) 2 E WHEN MULTIPLYING BY THE ROUND UP TO ONE (1) ACRE. EE FOR ANY REQUEST THAT
PROPERTY INFO	RMATION [PLEASE PRINT]				
ADDRESS	3600 S Goliad St, Rockwall, TX 750)32			
SUBDIVISION	A0128 J R JOHNSON			LOT	BLOCK
GENERAL LOCATION	Across the street from Springer E	lementary S	chool		
ZONING, SITE PL	AN AND PLATTING INFORMATION [PLEA	SE PRINT]			
CURRENT ZONING	Agriculture & Commercial	CURRENT	USE \	/acant	
PROPOSED ZONING	Planned Development	PROPOSED	USE Mix	ed USe	
ACREAGE	15.601 LOTS [CURRENT	ŋ 1		LOTS [PROPOSED]	5-6
REGARD TO ITS A	<u>PLATS</u> : BY CHECKING THIS BOX YOU ACKNOWLEDGE TO PPROVAL PROCESS, AND FAILURE TO ADDRESS ANY OF ENIAL OF YOUR CASE.				
OWNER/APPLICA	NT/AGENT INFORMATION [PLEASE PRINT/CI	HECK THE PRIMAR	Y CONTACT/	ORIGINAL SIGNATURES ARE	REQUIRED]
☑ OWNER	Gardner Land Holdings LLC	☐ APPLICA	_	dner Land Holdings L	
CONTACT PERSON	Bart Gardner	CONTACT PERS	SON Ja	mes Martin	
ADDRESS	15950 SH 205	ADDRI	ESS 1595	0 SH 205	
CITY, STATE & ZIP	Terrell, Texas 75160	CITY, STATE &		ell, Texas 75160	
PHONE		PHO			
E-MAIL		E-N	IAIL I		188
STATED THE INFORMATIO	SIGNED AUTHORITY, ON THIS DAY PERSONALLY APPEARED ON ON THIS APPLICATION TO BE TRUE AND CERTIFIED THE AM THE OWNER FOR THE PURPOSE OF THIS APPLICATION; A TO COVER THE COST OF THIS APPLICATION, A	E FOLLOWING: ALL INFORMATION S IAS BEEN PAID TO TH	IE CITY OF RO	REIN IS TRUE AND CORRECT;	17+0 DAY OF
	20 <u>25</u> . BY SIGNING THIS APPLICATION, I AGR WITHIN THIS APPLICATION TO THE PUBLIC. THE CITY II ON WITH THIS APPLICATION, IF SUCH REPRODUCTION IS ASS	S ALSO AUTHORIZE	D AND PERM	MITTED TO REPRODUCE ANY REQUEST FOR PUBLIC INFORM	COPYRIGHTED INFORMATION
GIVEN UNDER MY HAND A	AND SEAL OF OFFICE ON THIS THE 11 DAY OF 16	ober	20 <u>25</u> .	Notary Notary	HEATHER HALE Public, State of Texas
	OWNER'S SIGNATURE X			2.2	n. Expires 10-05-2027
NOTARY PUBLIC IN AND I	FOR THE STATE OF TEXAS The Grant of TEXAS	lele		MY COMMISSION EXPIRE	10-05-202

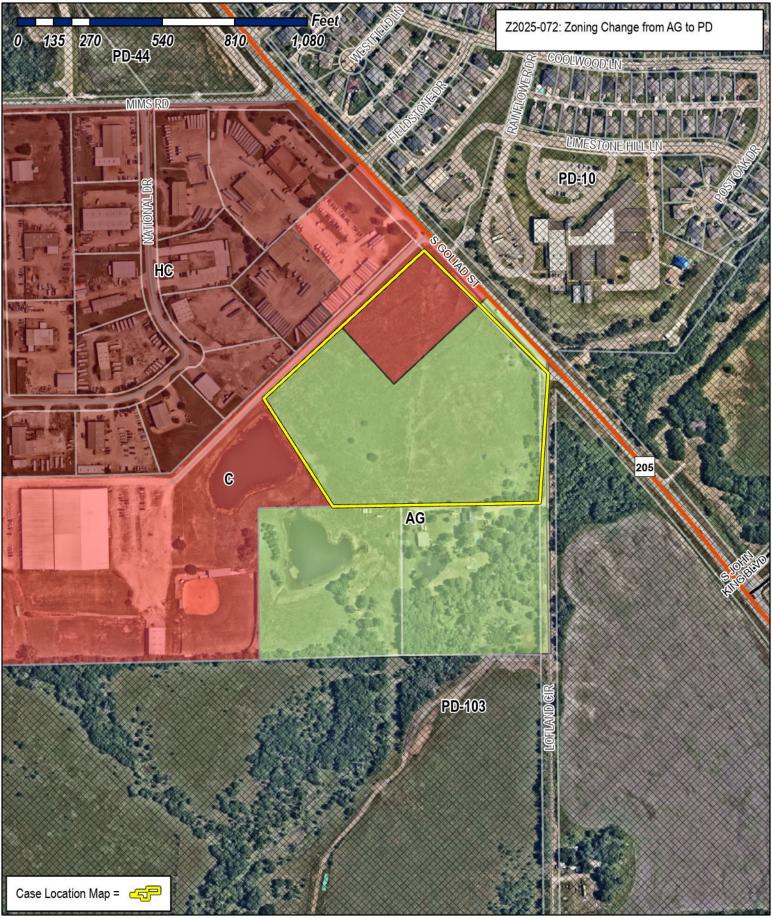



City of Rockwall Planning & Zoning Department 385 S. Goliad Street Rockwall, Texas 75087

(P): (972) 771-7745 (W): www.rockwall.com


The City of Rockwall GIS maps are continually under development and therefore subject to change without notice. While we endeavor to provide timely and accurate information, we make no guarantees. The City of Rockwall makes no warranty, express or implied, including warranties of merchantability and fitness for a particular purpose. Use of the information is the sole responsibility of the user.





The City of Rockwall GIS maps are continually under development and therefore subject to change without notice. While we endeavor to provide timely and accurate information, we make no guarantees. The City of Rockwall makes no warranty, express or implied, including warranties of merchantability and fitness for a particular purpose. Use of the information is the sole responsibility of the user.



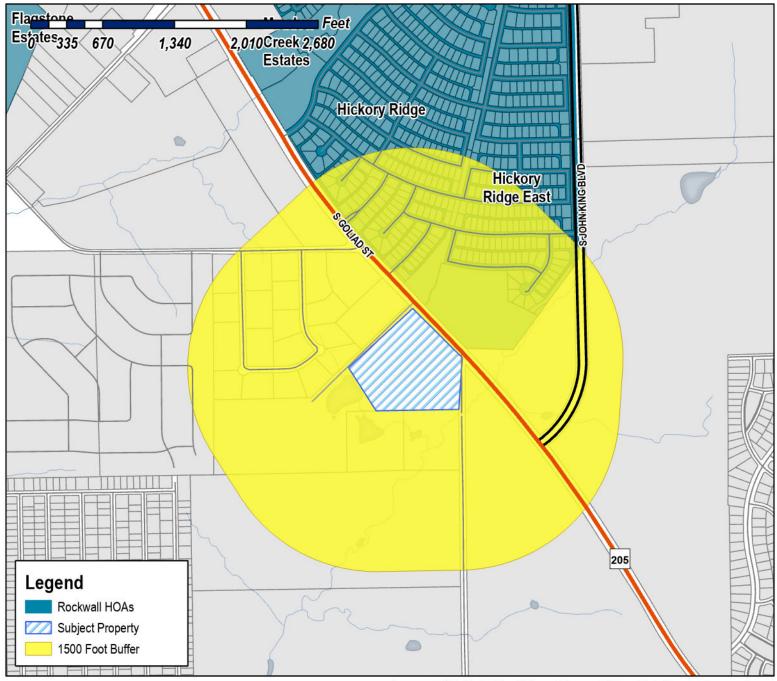

Case Number: Z2025-072

Case Name: Zoning Change from AG to PD

Case Type: Zoning

Zoning: Agricultural (AG) District **Case Address:** 3600 S. Goliad Street

Date Saved: 10/18/2025


For Questions on this Case Call (972) 771-7745





The City of Rockwall GIS maps are continually under development and therefore subject to change without notice. While we endeavor to provide timely and accurate information, we make no guarantees. The City of Rockwall makes no warranty, express or implied, including warranties of merchantability and fitness for a particular purpose. Use of the information is the sole responsibility of the user.



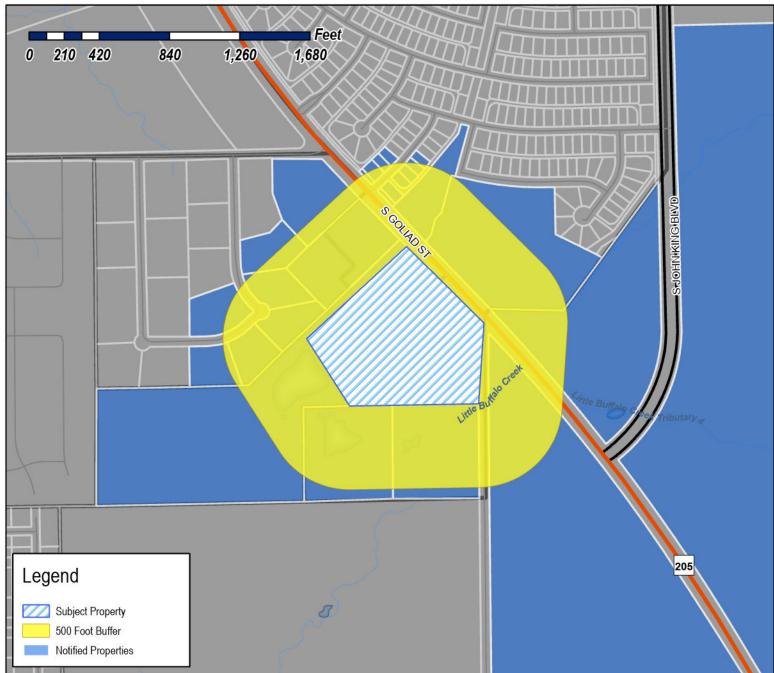

Case Number: Z2025-072


Case Name: Zoning Change from AG to PD

Case Type: Zoning

Zoning: Agricultural (AG) District
Case Address: 3600 S. Goliad Street

Date Saved: 10/18/2025

For Questions on this Case Call: (972) 771-7745

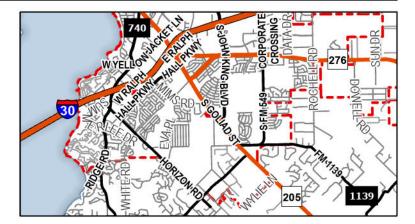

RESIDENT	JONES MICHAEL	ZIYADEH MUNEER R ABU
HWY205/FIELDSTONE	125 Deverson Dr	1490 FIELDSTONE DR
ROCKWALL, TX 75032	Rockwall, TX 75087	ROCKWALL, TX 75032
REYES JULIO CESAR & URANIA S	CONFIDENTIAL	NICKERSON TELISA A
1491 FIELDSTONE DR	1500 FIELDSTONE DR	1501 FIELDSTONE DR
ROCKWALL, TX 75032	ROCKWALL, TX 75032	ROCKWALL, TX 75032
KROLL MONTY R	RESIDENT	CRUZET MARIE FLOR
1506 FIELDSTONE DR	1507 FIELDSTONE DR	1512 FIELDSTONE DR
ROCKWALL, TX 75032	ROCKWALL, TX 75032	ROCKWALL, TX 75032
AUTENCIO ROSELYN P & PHILIP	NXG SERVICES LLC	MILLER FAMILY INVESTMENT LP
1518 FIELDSTONE DR	1520 Bell Haven Ct	17430 Campbell Rd Ste 230
ROCKWALL, TX 75032	Rockwall, TX 75032	Dallas, TX 75252
HICKORY RIDGE EAST HOMEOWNERS ASSOC	HICKORY RIDGE EAST HOMEOWNERS ASSOC	RESIDENT
1800 Preston Park Blvd Ste 101	1800 Preston Park Blvd Ste 101	227 NATIONAL DR
Plano, TX 75093	Plano, TX 75093	ROCKWALL, TX 75032
RESIDENT	RESIDENT	RESIDENT
2890 S GOLIAD	2890 S GOLIAD	291 NATIONAL DR
ROCKWALL, TX 75032	ROCKWALL, TX 75032	ROCKWALL, TX 75032
RESIDENT	LAYZA & LUNA REAL ESTATE LLC	RESIDENT
2915 S GOLIAD	2922 S GOLIAD ST	3025 LIMESTONE HILL LN
ROCKWALL, TX 75032	ROCKWALL, TX 75032	ROCKWALL, TX 75032
RESIDENT	EPES TRANSPORT SYSTEM LLC	RESIDENT
311 NATIONAL DR	3400 EDGEFIELD CT	355 NATIONAL DR
ROCKWALL, TX 75032	GREENSBORO, NC 27408	ROCKWALL, TX 75032
RESIDENT	FORREST FRANK & KELLI LAFON	FORREST FRANK & KELLI LAFON
368 NATIONAL DR	3808 LOFLAND CIR	3808 LOFLAND CIR
ROCKWALL, TX 75032	ROCKWALL, TX 75032	ROCKWALL, TX 75032
RESIDENT	HPLI LLC	CITY OF ROCKWALL
381 NATIONAL DR	3820 AZURE LN	385 S GOLIAD ST
ROCKWALL, TX 75032	ADDISON, TX 75001	ROCKWALL, TX 75087

GADDIS ROY F FAMILY TRUST ROY F GADDIS TRUSTEE 6 BRIGHT MEADOWS ROAD HEATH, TX 75032 QUALICO DEVELOPMENTS US INC 6950 Tpc Dr Ste 150 2 GREENSIDE AT CRAIG RANCH McKinney, TX 75070

GROUP 1 REALTY INC 730 Town and Country Blvd Ste 500 Houston, TX 77024

D & A REAL ESTATE PARTNERS LTD PO BOX 850 ROCKWALL, TX 75087 TJT INVESTMENT TRUST
JAMES DWAINE POWERS & PATRICIA ANNETTE
POWERS - CO-TRUSTEES
PO BOX 850
ROCKWALL, TX 75087



PLANNED DEVELOPMENT (PD) NARRATIVE

Project Name: The Exchange at Rockwall

Location: 3600 S. Goliad St., Rockwall, Texas 75032

Applicant/Developer: Gardner Construction / ConTex Development Partners

Architect: Level 5 Architecture

Date: October 17, 2025

1. Purpose and Intent

This Planned Development (PD) District establishes a unified regulatory framework for a mixed-use project incorporating **General Retail (GR)** and **Commercial (C)** uses across approximately **15.6 acres**.

The PD is designed to accommodate a complementary mix of neighborhood-oriented retail and commercial uses consistent with the vision for the S. Goliad / SH-205 corridor. The development provides flexibility for phased implementation while maintaining cohesive design and operational standards.

PD Objectives:

- Create a neighborhood-friendly environment with retail and service uses that complement adjacent development.
- Establish a smooth land-use transition from retail frontage to commercial uses to the rear of the site.
- Allow flexibility for individual lot development, marketing, or sale under unified design controls.
- Promote high-quality architecture, landscaping, and coordinated site circulation.

2. Purpose and Compatibility Statement

The proposed PD is consistent with the City of Rockwall Comprehensive Plan and supports the City's long-term vision for balanced commercial growth along the SH-205 corridor.

Key Compatibility Elements:

• Land Use Integration: Creates a logical transition between retail, neighborhood commercial, and employment uses.



- Economic Diversity: Expands the City's tax base through a mix of general retail, office, and flexible commercial space.
- Enhanced Design Standards: Incorporates architectural and landscape features that exceed base zoning requirements to enhance corridor aesthetics.
- Coordinated Access: Reduces vehicular conflicts through shared drives, internal circulation, and integrated parking.
- Adaptable Framework: Supports evolving market demand while maintaining a cohesive architectural identity.

Collectively, this PD establishes a high-quality and compatible development pattern that complements existing and planned uses within the corridor.

3. Development Summary

<u>Lot</u>	Acreage / SF	Building SF	<u>Primary Use</u>	<u>District</u>	Ownership Strategy
1	0.85 ac / 37,090 SF	TBD	Retail Pad Site	GR	Sell as pad site
2	2.30 ac / 100,082 SF	13,250 SF	Multi-Tenant Retail Center	GR	Build and lease
3	0.74 ac / 32,332 SF	TBD	Retail Pad Site	GR	Sell as pad site
4	1.61 ac / 70,230 SF	16,437 SF	Various Commercial Uses	С	Build and lease
5	2.88 ac / 125,236 SF	26,486 SF	Office / Professional	С	Build and lease or sell
6	6.77 ac / 294,694 SF	60,977 SF	Various Commercial Uses	С	Build and lease

Total 15.6 ac / 679,000 SF ~117,000 SF



4. PD Summary and Permitted Use Matrix

The PD consists of two sub-districts to promote clarity and compatibility:

- 1. Sub-District 1: General Retail (Lots 1-3)
 - a. Uses shall conform to the City of Rockwall UDC with the following additional "Permitted by Right" uses to enhance neighborhood accessibility and support local demand:
 - i. Restaurant (less than 2,000 SF) with Drive-Through or Drive-In
 - ii. Restaurant (2,000 SF or more) with Drive-Through or Drive-In
 - b. These additions provide convenient dining options for nearby residents without increasing traffic along the I-30 corridor.
- 2. Sub-District 2: Commercial (Lots 4-6)
 - a. Uses shall conform to the City of Rockwall UDC with the following additional "Permitted by Right" uses to align with modern commercial demand for small and mid-sized business tenants:
 - i. Animal Clinic (Small Animals, no outdoor pens)
 - ii. Daycare (7 or more children)
 - iii. Indoor Commercial Amusement / Recreation
 - iv. Alcoholic Beverage Package Sales
 - v. General Personal Services
 - vi. Building & Landscape Material Sales (Limited Outdoor Storage)
 - vii. Wholesale Showroom Facility
 - viii. Light Assembly & Fabrication (from Light Industrial District)
 - ix. Light Manufacturing (from Light Industrial District)
 - x. Machine Shop (from Light Industrial District)
 - b. These uses support a balanced employment base and flexible commercial environment responsive to market needs.



5. Development Standards

Final PD standards, including setbacks, height, parking, access, landscaping, lighting, and signage, will be defined in coordination with City staff and documented within the PD ordinance. The intent is to maintain consistency with the City's design framework while providing flexibility for site-specific solutions.

6. PD Exhibits

- 1. Zoning and Site Plan Schematic
- 2. Legal Description
- 3. Elevations and Floor Plans
- 4. Landscape and Treescape Plans
- 5. Lighting Plan

7. Summary Statement

The Exchange at Rockwall establishes a high-quality, flexible development framework that enhances the S. Goliad / SH-205 corridor through compatible retail, office, and light commercial uses unified by cohesive design standards. The PD provides a predictable outcome for the City while offering developers the flexibility to respond to evolving tenant and market demand.

LAND DESCRIPTION

BEING a 15.601 acre tract of land situated in the J.R. Johnson Survey, Abstract Number 128, the City of Rockwall, Rockwall County, Texas, being all of Miller Family Investments, LP, record in Instrument Number 2008-00408220, Deed Records Rockwall County, Texas, and being more particularly described by metes and bounds as follows:

BEGINNING at a 1/2 inch iron rod found for corner in the most northerly corner of said Miller tract, same an interior corner of Layza and Luna Real Estate, LLC, recorded in Instrument Number 20220000001115, Deed Records Rockwall County, Texas, also being a point in the most westerly Right-of-Way line of Goliad Street (variable width Right-of-Way), from which a 1/2 inch iron rod found bears, North 43 degrees 32 minutes 03 seconds West, 40.00 feet;

THENCE South 43 degrees 32 minutes 03 seconds East, along the most northeasterly line of said Miller tract, a distance of 679.48 feet to a "60D" Nail found for corner in the most northeasterly corner of said Miller tract, same being the most northerly corner of Qualico Developments (U.S.), Inc., recorded in Instrument Number 20250000002120, Deed Records Rockwall County, Texas;

THENCE South 00 degrees 01 minutes 38 seconds East, departing from said Goliad Street in a southerly direction, a distance of 451.70 feet to a "Mag" Nail found for corner in the most southeasterly corner of said Miller tract, same being a point in the most westerly line of said Qualico tract, also being the most northeasterly corner of Frank Forrest and Kelli Lafon Forest, recorded in Volume 2664, Page 159, Deed Records Rockwall County, Texas;


THENCE over, across, and upon said Miller tract the following three (3) courses and distances:

South 87 degrees 56 minutes 04 seconds West, a distance of 537.08 feet to a capped 1/2 inch iron rod stamped "RPLS 5034" found for corner;

South 88 degrees 47 minutes 43 seconds West, a distance of 260.79 feet to a 1/2 inch iron rod found for corner;

North 31 degrees 48 minutes 51 seconds West, a distance of 482.00 feet to a 1/2 inch iron rod found for corner in the most westerly corner of said Miller tract, also being an interior corner of said Layza and Luna tract;

THENCE North 46 degrees 11 minutes 30 seconds East, along the most northwesterly line of said Miller tract, a distance of 808.31 feet to the POINT OF BEGINNING and containing 15.601 acres (679,586 sq. ft.) of land, more or less.

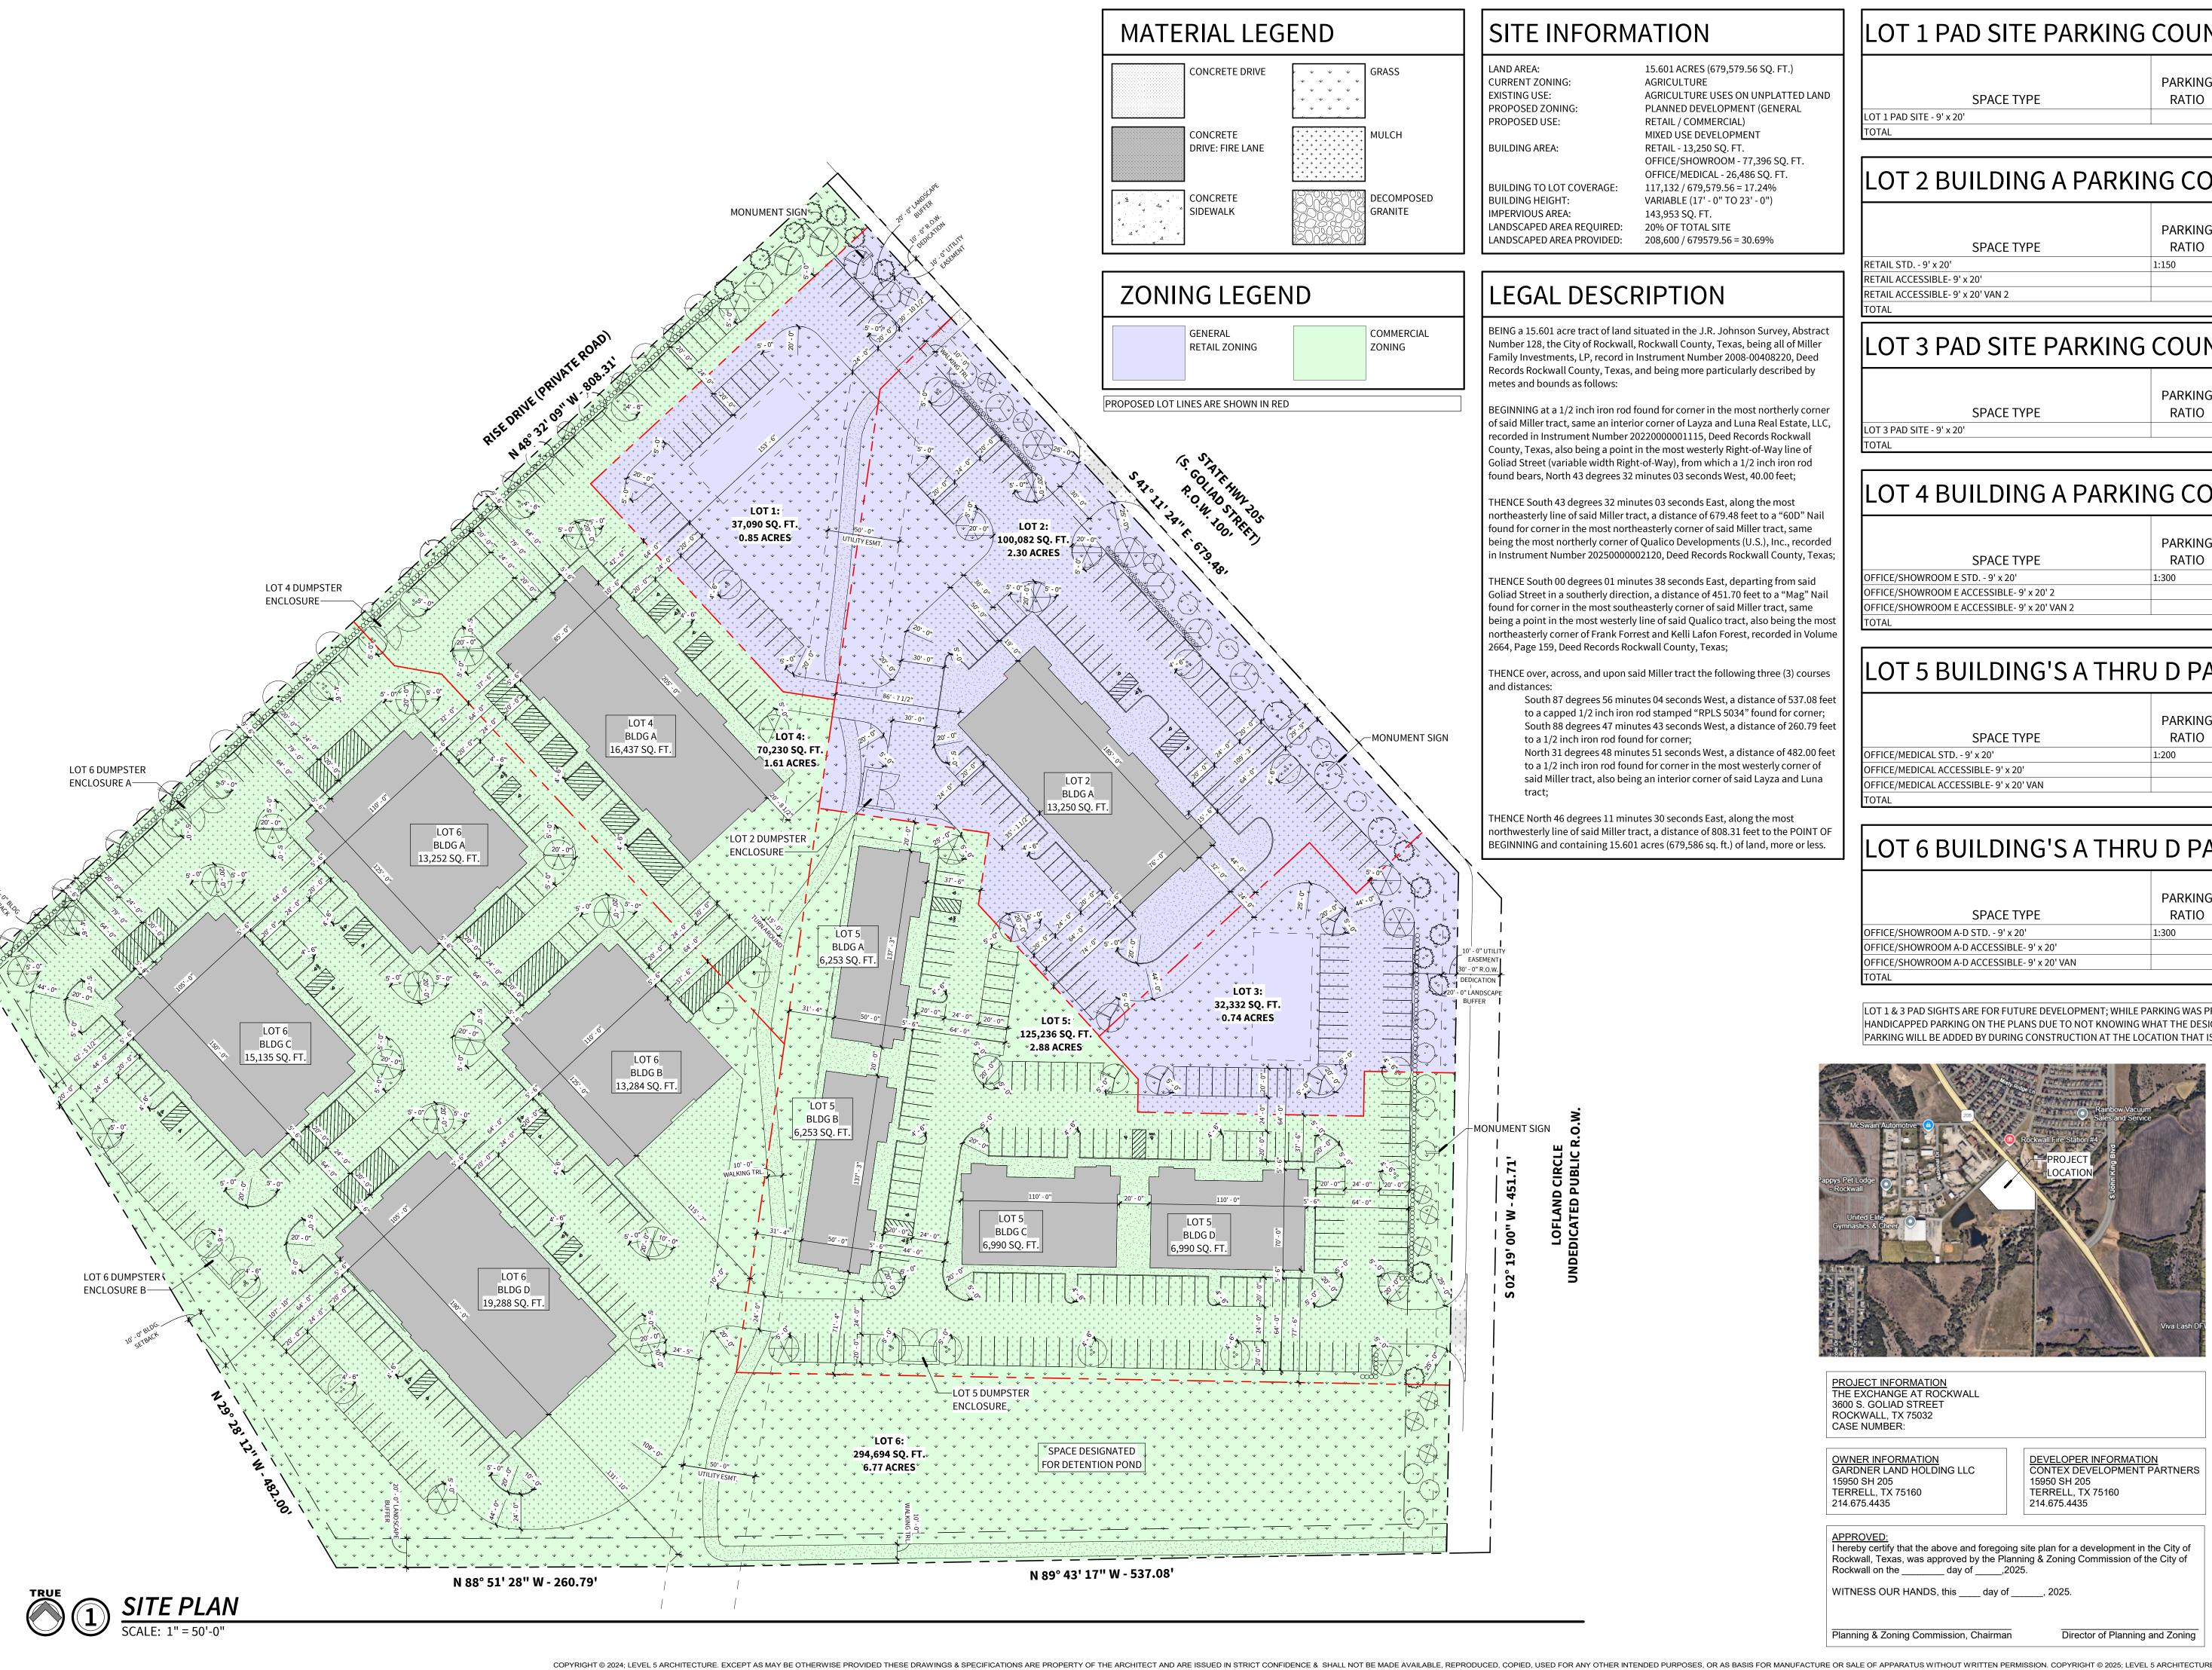

15.601 ACRES (679,579.56 SQ. FT.) AGRICULTURE AGRICULTURE USES ON UNPLATTED LAND PLANNED DEVELOPMENT (GENERAL RETAIL / COMMERCIAL) MIXED USE DEVELOPMENT RETAIL - 13,250 SQ. FT.

OFFICE/SHOWROOM - 77,396 SQ. FT. OFFICE/MEDICAL - 26,486 SQ. FT. 117,132 / 679,579.56 = 17.24% VARIABLE (17' - 0" TO 23' - 0") 143,953 SQ. FT. 20% OF TOTAL SITE

BEING a 15.601 acre tract of land situated in the J.R. Johnson Survey, Abstract Number 128, the City of Rockwall, Rockwall County, Texas, being all of Miller Family Investments, LP, record in Instrument Number 2008-00408220, Deed Records Rockwall County, Texas, and being more particularly described by

BEGINNING at a 1/2 inch iron rod found for corner in the most northerly corner of said Miller tract, same an interior corner of Layza and Luna Real Estate, LLC, recorded in Instrument Number 2022000001115, Deed Records Rockwall County, Texas, also being a point in the most westerly Right-of-Way line of Goliad Street (variable width Right-of-Way), from which a 1/2 inch iron rod found bears, North 43 degrees 32 minutes 03 seconds West, 40.00 feet;

THENCE South 43 degrees 32 minutes 03 seconds East, along the most northeasterly line of said Miller tract, a distance of 679.48 feet to a "60D" Nail found for corner in the most northeasterly corner of said Miller tract, same being the most northerly corner of Qualico Developments (U.S.), Inc., recorded n Instrument Number 20250000002120, Deed Records Rockwall County, Texas;

THENCE South 00 degrees 01 minutes 38 seconds East, departing from said Goliad Street in a southerly direction, a distance of 451.70 feet to a "Mag" Nail found for corner in the most southeasterly corner of said Miller tract, same being a point in the most westerly line of said Qualico tract, also being the most northeasterly corner of Frank Forrest and Kelli Lafon Forest, recorded in Volume

THENCE over, across, and upon said Miller tract the following three (3) courses

South 87 degrees 56 minutes 04 seconds West, a distance of 537.08 feet to a capped 1/2 inch iron rod stamped "RPLS 5034" found for corner; South 88 degrees 47 minutes 43 seconds West, a distance of 260.79 feet

North 31 degrees 48 minutes 51 seconds West, a distance of 482.00 feet to a 1/2 inch iron rod found for corner in the most westerly corner of said Miller tract, also being an interior corner of said Layza and Luna

THENCE North 46 degrees 11 minutes 30 seconds East, along the most northwesterly line of said Miller tract, a distance of 808.31 feet to the POINT OF BEGINNING and containing 15.601 acres (679,586 sq. ft.) of land, more or less.

LOT 1 PAD SITE PARKING COUNT

				REQUIRED	
		PARKING	SQUARE	PARKING	PROVIDE
	SPACE TYPE	RATIO	FOOTAGE	COUNT	PARKING
LOT	1 PAD SITE - 9' x 20'				

LOT 2 BUILDING A PARKING COUNT

			REQUIRED		
	PARKING	SQUARE	PARKING	PROVIDED	
SPACE TYPE	RATIO	FOOTAGE	COUNT	PARKING	
ETAIL STD 9' x 20'	1:150	13250	89	90	
ETAIL ACCESSIBLE- 9' x 20'			3	3	
ETAIL ACCESSIBLE- 9' x 20' VAN 2			1	1	
OTAL				94	

OT 2 DAD CITE DADKING COLINIT

.UI 3 PAD SITE PARKING	COUN	l		
			REQUIRED	
	PARKING	SQUARE	PARKING	PROVIDED
SPACE TYPE	RATIO	FOOTAGE	COUNT	PARKING
T 3 PAD SITE - 9' x 20'				30

LOT 4 BUILDING A PARKING COUNT

			REQUIRED	
	PARKING	SQUARE	PARKING	PROVIDED
SPACE TYPE	RATIO	FOOTAGE	COUNT	PARKING
OFFICE/SHOWROOM E STD 9' x 20'	1:300	16437	55	67
OFFICE/SHOWROOM E ACCESSIBLE- 9' x 20' 2			2	2
OFFICE/SHOWROOM E ACCESSIBLE- 9' x 20' VAN 2			1	1
TOTAL				70

LOT 5 BUILDING'S A THRU D PARKING COUNT

			REQUIRED	
	PARKING	SQUARE	PARKING	PROVIDED
SPACE TYPE	RATIO	FOOTAGE	COUNT	PARKING
OFFICE/MEDICAL STD 9' x 20'	1:200	26486	133	143
OFFICE/MEDICAL ACCESSIBLE- 9' x 20'			4	3
OFFICE/MEDICAL ACCESSIBLE- 9' x 20' VAN			1	3
ΤΩΤΔΙ				149

LOT 6 BUILDING'S A THRU D PARKING COUNT

			REQUIRED	
	PARKING	SQUARE	PARKING	PROVIDED
SPACE TYPE	RATIO	FOOTAGE	COUNT	PARKING
OFFICE/SHOWROOM A-D STD 9' x 20'	1:300	60959	204	190
OFFICE/SHOWROOM A-D ACCESSIBLE- 9' x 20'			6	7
OFFICE/SHOWROOM A-D ACCESSIBLE- 9' x 20' VAN			1	7
TOTAL				204

LOT 1 & 3 PAD SIGHTS ARE FOR FUTURE DEVELOPMENT; WHILE PARKING WAS PROVIDED WE HAVE NOT PROVIDED ANY HANDICAPPED PARKING ON THE PLANS DUE TO NOT KNOWING WHAT THE DESIGN OF THESE BUILDING WOULD ENTAIL. HC PARKING WILL BE ADDED BY DURING CONSTRUCTION AT THE LOCATION THAT IS BEST SUITED FOR THE STRUCTURE DESIGNED

<u>DEVELOPER INFORMATION</u> CONTEX DEVELOPMENT PARTNERS

15950 SH 205

214.675.4435

TERRELL, TX 75160



PROJECT INFORMATION
THE EXCHANGE AT ROCKWALL
3600 S. GOLIAD STREET ROCKWALL, TX 75032 CASE NUMBER:

WITNESS OUR HANDS, this ____ day of _____, 2025.

OWNER INFORMATION GARDNER LAND HOLDING LLC 15950 SH 205 TERRELL, TX 75160 214.675.4435

I hereby certify that the above and foregoing site plan for a development in the City of Rockwall, Texas, was approved by the Planning & Zoning Commission of the City of Rockwall on the _____ day of _____,2025.

Director of Planning and Zoning Planning & Zoning Commission, Chairman



Level 5 Architecture Mansfield, TX | Springdale, AR level5architecture.com

THESE DOCUMENTS ARE FOR REVIEW ONLY AND ARE NOT INTENDED FOR BIDDING, PERMITTING OR **CONSTRUCTION PURPOSES**






NORTHWEST ELEVATION - LOT 2 BUILDING A


SCALE: 1/8" = 1'-0"

EL: 116' - 0"	 	
LEVEL 2	SECONDARY NAME	
EL: 114' - 0" TOP OF WALL		
		Tris -
EL: 100' - 0"		
♥ LEVEL 1		

SCALE: 1/8" = 1'-0"

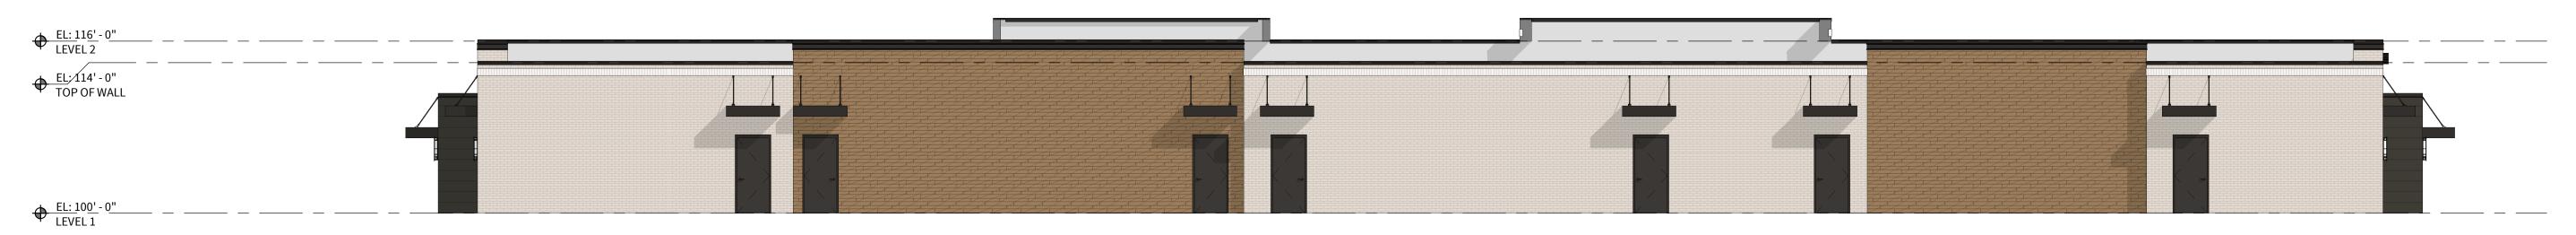

SCALE: 1/8" = 1'-0"

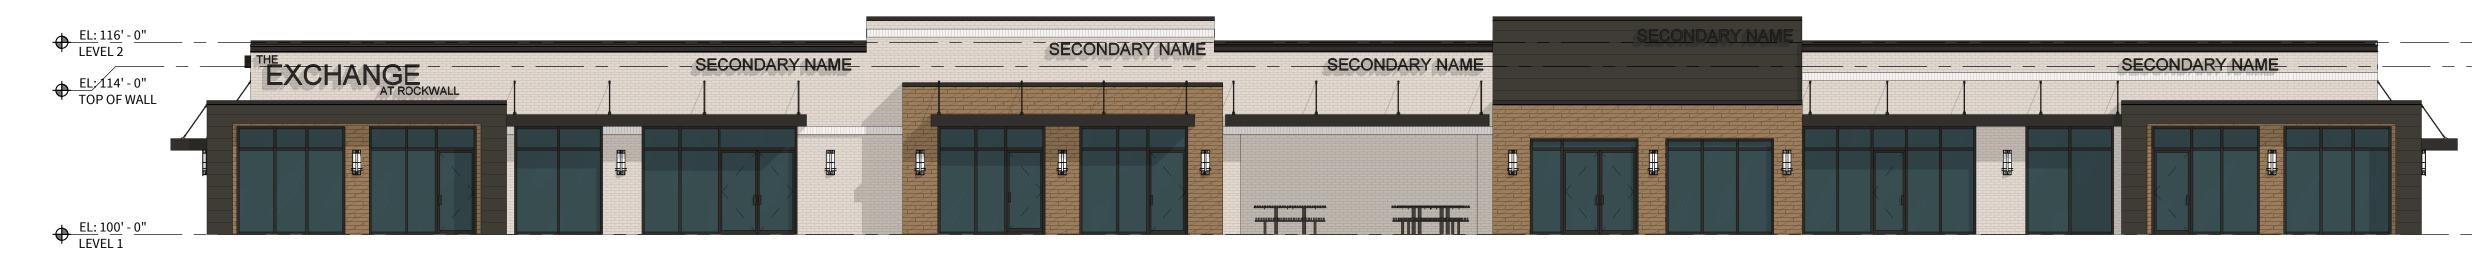

NORTHEAST ELEVATION - LOT 2 BUILDING A

SCALE: 1/8" = 1'-0"

PROJECT INFORMATION
THE EXCHANGE AT ROCKWALL
3600 S. GOLIAD STREET ROCKWALL, TX 75032 CASE NUMBER: DEVELOPER INFORMATION CONTEX DEVELOPMENT PARTNERS OWNER INFORMATION GARDNER LAND HOLDING LLC 15950 SH 205 15950 SH 205 TERRELL, TX 75160 TERRELL, TX 75160 214.675.4435 214.675.4435 APPROVED:
I hereby certify that the above and foregoing site plan for a development in the City of Rockwall, Texas, was approved by the Planning & Zoning Commission of the City of Rockwall on the _____ day of _____,2025.

WITNESS OUR HANDS, this ____ day of _____, 2025.

THESE DOCUMENTS ARE FOR REVIEW ONLY AND ARE NOT INTENDED FOR BIDDING, PERMITTING OR CONSTRUCTION PURPOSES

Level 5 Architecture

Mansfield, TX | Springdale, AR level5architecture.com

MATERIALS CALCULATIONS

MATERIAL

METAL PANEL 329

METAL PANEL 256

METAL PANEL 256

METAL PANEL 79

1109

1008

2783

1107

979 2577

BRICK

SIDING

GLAZING

SIDING

BRICK GLAZING

SIDING

BRICK

DOORS

SIDING

GLAZING

ORIENTATION

NORTHEAST (FRONT) NORTHEAST (FRONT)

NORTHEAST (FRONT) NORTHEAST (FRONT)

NORTHEAST (FRONT)

NORTHWEST (RIGHT) NORTHWEST (RIGHT)

NORTHWEST (RIGHT)

NORTHWEST (RIGHT)

NORTHWEST (RIGHT)

SOUTHEAST (LEFT)

SOUTHEAST (LEFT)

SOUTHEAST (LEFT)

SOUTHEAST (LEFT)

SOUTHEAST (LEFT)

SOUTHWEST (REAR) SOUTHWEST (REAR)

SOUTHWEST (REAR)

SOUTHWEST (REAR)

SOUTHWEST (REAR)

MATERIAL LEGEND

ACM PANEL CAST STONE RAL PAINT


ACCENT BRICK LEUDER STONE WOOD LOOK

FIBER CEMENT

SIDING

ARCHITECT: JUSTIN S. GILMORE LEVEL 5 ARCHITECTURE


Planning & Zoning Commission, Chairman Director of Planning and Zoning COPYRIGHT © 2024; LEVEL 5 ARCHITECTURE. EXCEPT AS MAY BE OTHERWISE PROVIDED THESE DRAWINGS & SPECIFICATIONS ARE PROPERTY OF THE ARCHITECT AND ARE ISSUED IN STRICT CONFIDENCE & SHALL NOT BE MADE AVAILABLE, REPRODUCED, COPIED, USED FOR ANY OTHER INTENDED PURPOSES, OR AS BASIS FOR MANUFACTURE OR SALE OF APPARATUS WITHOUT WRITTEN PERMISSION. COPYRIGHT © 2025; LEVEL 5 ARCHITECTURE

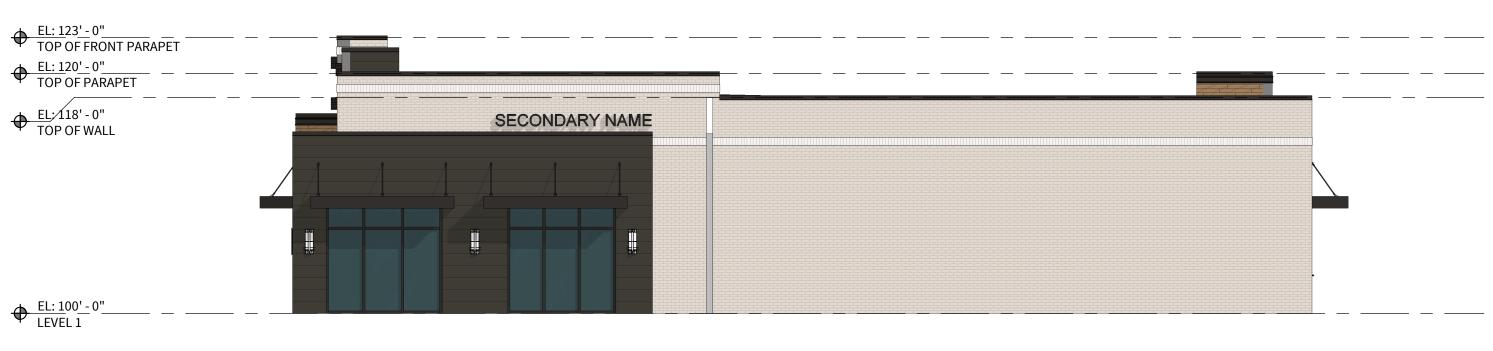


NORTHWEST ELEVATION - LOT 4 BUILDING A SCALE: 1/8" = 1'-0"

DNT PARAPET L RAPET			 	 	 							 	
 ; LL							S	ECONDAF	RY NAME				
LL													
								1	/	1 1			
								4			 		
										ND III	N.D.		
								Tis		(1.0	dis		

SCALE: 1/8" = 1'-0"

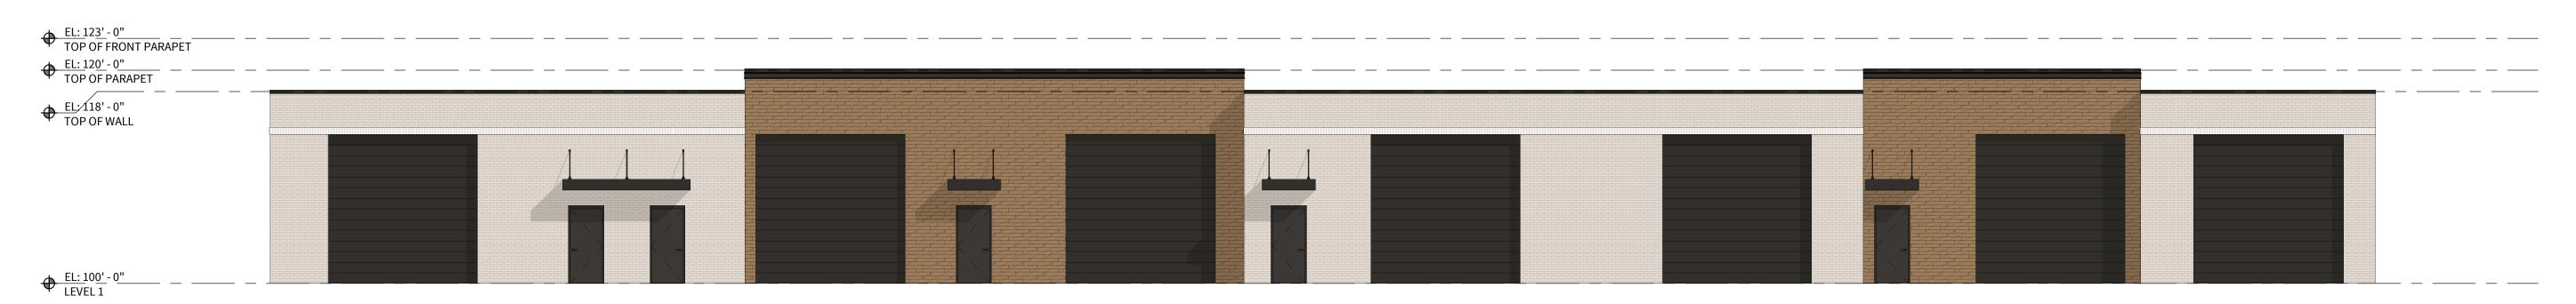

SCALE: 1/8" = 1'-0"

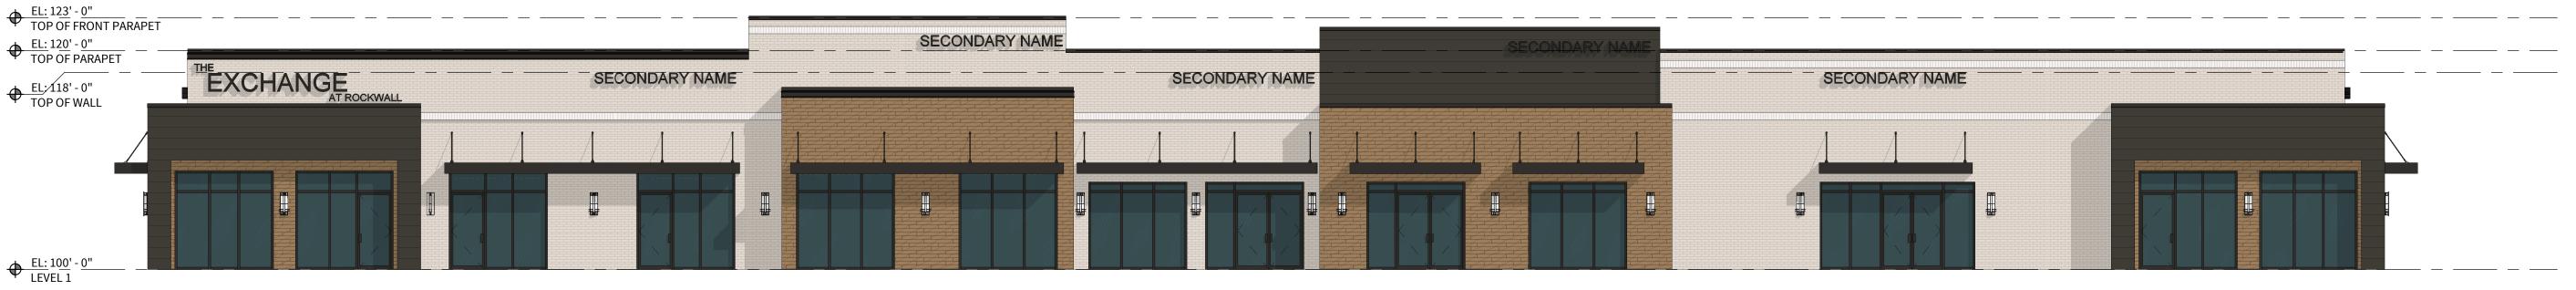

NORTHEAST ELEVATION - LOT 4 BUILDING A

SCALE: 1/8" = 1'-0"

PROJECT INFORMATION
THE EXCHANGE AT ROCKWALL
3600 S. GOLIAD STREET ROCKWALL, TX 75032 CASE NUMBER: DEVELOPER INFORMATION CONTEX DEVELOPMENT PARTNERS OWNER INFORMATION GARDNER LAND HOLDING LLC 15950 SH 205 15950 SH 205

TERRELL, TX 75160 214.675.4435

THESE DOCUMENTS ARE FOR REVIEW ONLY AND ARE NOT INTENDED FOR BIDDING, PERMITTING OR CONSTRUCTION PURPOSES

Level 5 Architecture

Mansfield, TX | Springdale, AR level5architecture.com

MATERIALS CALCULATIONS

MATERIAL

METAL PANEL 534

METAL PANEL 256

METAL PANEL 256

1776

1049

3995

1543

164

1543

1495

3597

755

10

BRICK

SIDING

GLAZING

BRICK GLAZING

DOORS

SIDING

GLAZING

ORIENTATION

NORTHEAST (FRONT)

NORTHEAST (FRONT)

NORTHEAST (FRONT)

NORTHEAST (FRONT)

NORTHEAST (FRONT)

NORTHWEST (RIGHT) NORTHWEST (RIGHT)

NORTHWEST (RIGHT)

NORTHWEST (RIGHT)

SOUTHEAST (LEFT) SOUTHEAST (LEFT)

SOUTHEAST (LEFT)

SOUTHEAST (LEFT)

SOUTHWEST (REAR) SOUTHWEST (REAR)

SOUTHWEST (REAR)

SOUTHWEST (REAR)

MATERIAL LEGEND


ACM PANEL CAST STONE RAL PAINT

ACCENT BRICK LEUDER STONE WOOD LOOK

FIBER CEMENT


ARCHITECT: JUSTIN S. GILMORE LEVEL 5 ARCHITECTURE


TERRELL, TX 75160 214.675.4435 APPROVED:
I hereby certify that the above and foregoing site plan for a development in the City of Rockwall, Texas, was approved by the Planning & Zoning Commission of the City of Rockwall on the _____ day of _____,2025. WITNESS OUR HANDS, this ____ day of _____, 2025. Planning & Zoning Commission, Chairman Director of Planning and Zoning COPYRIGHT © 2024; LEVEL 5 ARCHITECTURE. EXCEPT AS MAY BE OTHERWISE PROVIDED THESE DRAWINGS & SPECIFICATIONS ARE PROPERTY OF THE ARCHITECT AND ARE ISSUED IN STRICT CONFIDENCE & SHALL NOT BE MADE AVAILABLE, REPRODUCED, COPIED, USED FOR ANY OTHER INTENDED PURPOSES, OR AS BASIS FOR MANUFACTURE OR SALE OF APPARATUS WITHOUT WRITTEN PERMISSION. COPYRIGHT © 2025; LEVEL 5 ARCHITECT AND ARE ISSUED IN STRICT CONFIDENCE & SHALL NOT BE MADE AVAILABLE, REPRODUCED, COPIED, USED FOR ANY OTHER INTENDED PURPOSES, OR AS BASIS FOR MANUFACTURE OR SALE OF APPARATUS WITHOUT WRITTEN PERMISSION.

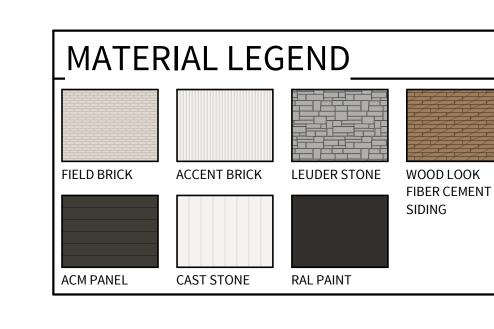


%	AREA	MATERIAL	ORIENTATION
			NORTHEAST (LEFT)
60	461	BRICK	NORTHEAST (LEFT)
38	286	GLAZING	NORTHEAST (LEFT)
2	16	SIDING	NORTHEAST (LEFT)
	763		NORTHWEST (REAR)
83	1626	BRICK	NORTHWEST (REAR)
2	72	DOORS	NORTHWEST (REAR)
12	240	GLAZING	NORTHWEST (REAR)
3	56	STONE	NORTHWEST (REAR)
	1994		SOUTHEAST (FRONT)
27	541	BRICK	SOUTHEAST (FRONT)
31	601	GLAZING	SOUTHEAST (FRONT)
22	434	METAL PANEL	SOUTHEAST (FRONT)
20	392	SIDING	SOUTHEAST (FRONT)
	1968		SOUTHWEST (RIGHT)
91	696	BRICK	SOUTHWEST (RIGHT)
7	52	GLAZING	SOUTHWEST (RIGHT)
2	16	SIDING	SOUTHWEST (RIGHT)

CALCULATION ARE SHOWN FOR BUILDING A. BUILDING B WOULD HAVE THE SAME CALCUATIONS WITH THE EXCEPTION OF THE GLAZING AND BRICK TOTALS BEING INTERCHANGAGBLE ON THE NORTHEAST AND SOUTHWEST ELEVATIONS.

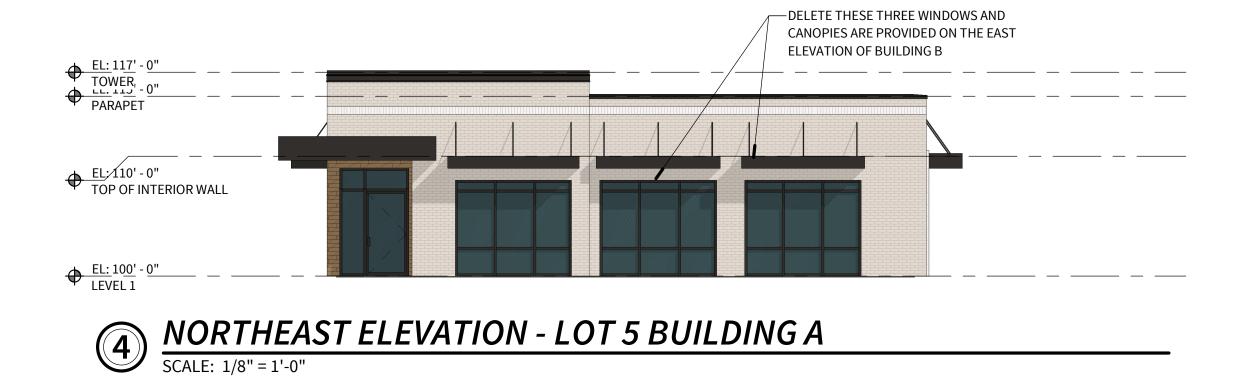

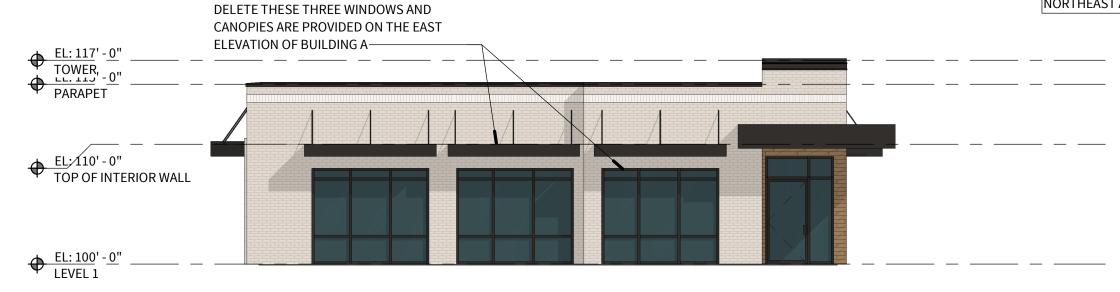


SCALE: 1/8" = 1'-0"

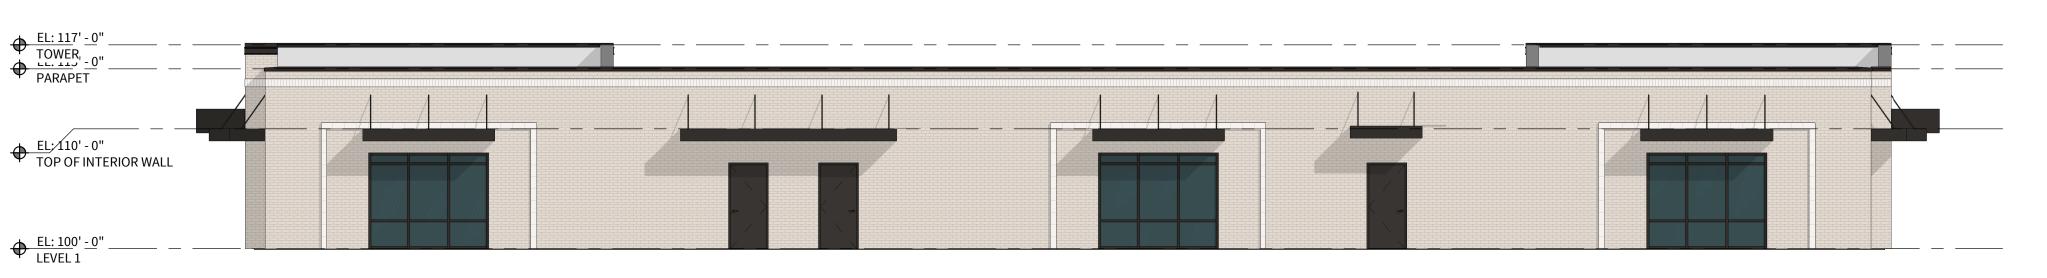

NORTHWEST ELEVATION - LOT 5 BUILDING A & B

SCALE: 1/8" = 1'-0"

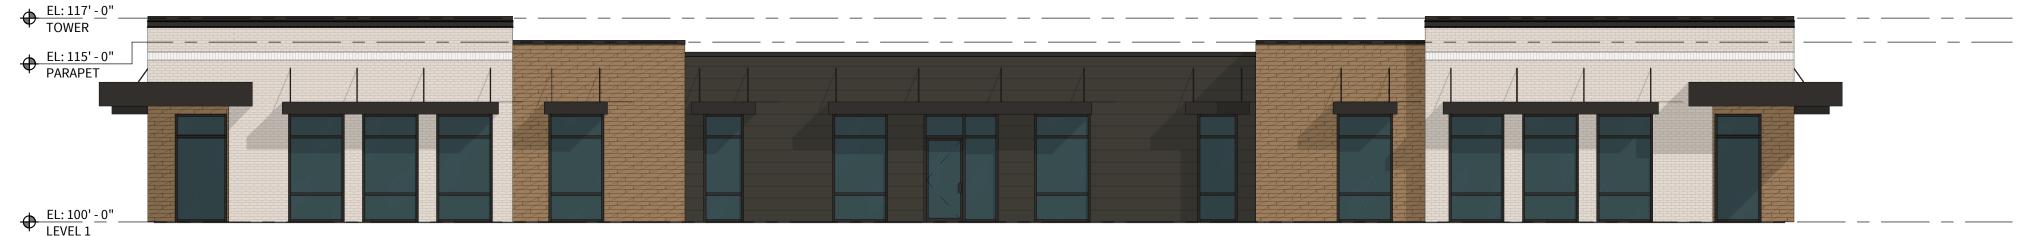

COPYRIGHT © 2024; LEVEL 5 ARCHITECTURE. EXCEPT AS MAY BE OTHERWISE PROVIDED THESE DRAWINGS & SPECIFICATIONS ARE PROPERTY OF THE ARCHITECT AND ARE ISSUED IN STRICT CONFIDENCE & SHALL NOT BE MADE AVAILABLE, REPRODUCED, COPIED, USED FOR ANY OTHER INTENDED PURPOSES, OR AS BASIS FOR MANUFACTURE OR SALE OF APPARATUS WITHOUT WRITTEN PERMISSION. COPYRIGHT © 2025; LEVEL 5 ARCHITECT AND ARE ISSUED IN STRICT CONFIDENCE & SHALL NOT BE MADE AVAILABLE, REPRODUCED, COPIED, USED FOR ANY OTHER INTENDED PURPOSES, OR AS BASIS FOR MANUFACTURE OR SALE OF APPARATUS WITHOUT WRITTEN PERMISSION.

SCALE: 1/8" = 1'-0"

PROJECT INFORMATION
THE EXCHANGE AT ROCKWALL
3600 S. GOLIAD STREET ROCKWALL, TX 75032 CASE NUMBER: DEVELOPER INFORMATION CONTEX DEVELOPMENT PARTNERS OWNER INFORMATION GARDNER LAND HOLDING LLC 15950 SH 205 15950 SH 205 TERRELL, TX 75160 TERRELL, TX 75160 214.675.4435 214.675.4435

APPROVED:
I hereby certify that the above and foregoing site plan for a development in the City of Rockwall, Texas, was approved by the Planning & Zoning Commission of the City of Rockwall on the _____ day of ____,2025. WITNESS OUR HANDS, this ____ day of _____, 2025.


Planning & Zoning Commission, Chairman Director of Planning and Zoning

THESE DOCUMENTS ARE FOR REVIEW ONLY AND ARE NOT INTENDED FOR BIDDING, PERMITTING OR CONSTRUCTION PURPOSES ARCHITECT: JUSTIN S. GILMORE

LEVEL 5 ARCHITECTURE


Level 5 Architecture


Mansfield, TX | Springdale, AR level5architecture.com

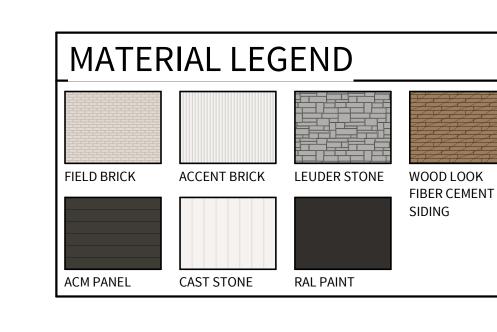

ORIENTATION	MATERIAL	AREA	%
EAST (RIGHT)	'		
EAST (RIGHT)	BRICK	945	93
EAST (RIGHT)	GLAZING	52	5
EAST (RIGHT)	SIDING	16	2
NORTH (FRONT)		1013	1
NORTH (FRONT)	BRICK	285	19
NORTH (FRONT)	GLAZING	446	29
NORTH (FRONT)	METAL PANEL	416	27
NORTH (FRONT)	SIDING	392	25
SOUTH (REAR)		1539	
SOUTH (REAR)	BRICK	1216	77
SOUTH (REAR)	DOORS	72	5
SOUTH (REAR)	GLAZING	240	15
SOUTH (REAR)	STONE	56	3
WEST (LEFT)		1584	
WEST (LEFT)	BRICK	706	70
WEST (LEFT)	GLAZING	290	28
WEST (LEFT)	SIDING	16	2
		1012	

CALCULATION ARE SHOWN FOR BUILDING C. BUILDING D WOULD HAVE THE SAME CALCUATIONS WITH THE EXCEPTION OF THE GLAZING AND BRICK TOTALS BEING INTERCHANGAGBLE ON THE EAST AND WEST ELEVATIONS.

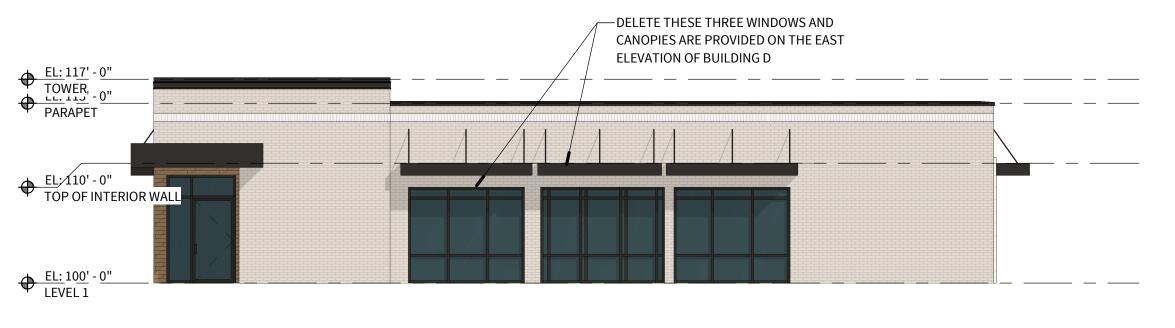

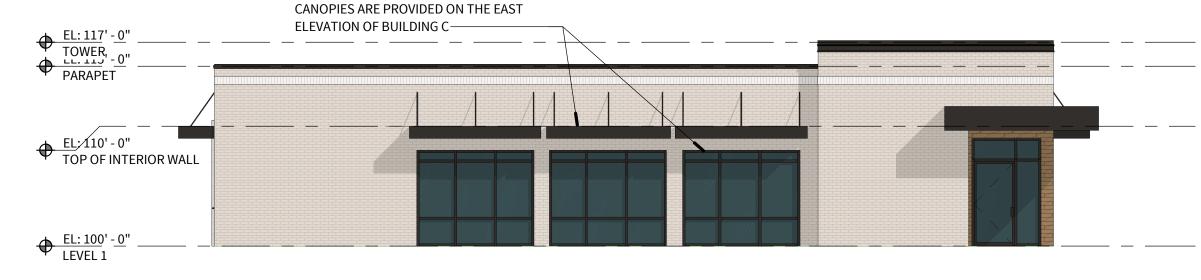


WEST ELEVATION - LOT 5 BUILDING C

SCALE: 1/8" = 1'-0"

(3) EAST ELEVATION - LOT 5 BUILDING D

SCALE: 1/8" = 1'-0"

DELETE THESE THREE WINDOWS AND

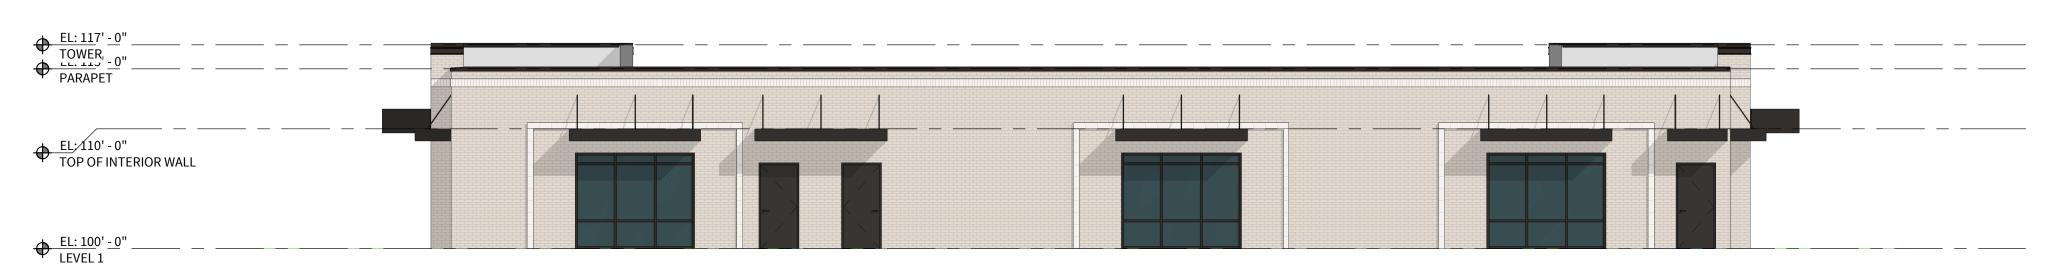

SCALE: 1/8" = 1'-0"

SCALE: 1/8" = 1'-0"



COPYRIGHT © 2024; LEVEL 5 ARCHITECTURE. EXCEPT AS MAY BE OTHERWISE PROVIDED THESE DRAWINGS & SPECIFICATIONS ARE PROPERTY OF THE ARCHITECT AND ARE ISSUED IN STRICT CONFIDENCE & SHALL NOT BE MADE AVAILABLE, REPRODUCED, COPIED, USED FOR ANY OTHER INTENDED PURPOSES, OR AS BASIS FOR MANUFACTURE OR SALE OF APPARATUS WITHOUT WRITTEN PERMISSION. COPYRIGHT © 2025; LEVEL 5 ARCHITECT AND ARE ISSUED IN STRICT CONFIDENCE & SHALL NOT BE MADE AVAILABLE, REPRODUCED, COPIED, USED FOR ANY OTHER INTENDED PURPOSES, OR AS BASIS FOR MANUFACTURE OR SALE OF APPARATUS WITHOUT WRITTEN PERMISSION.

NORTH ELEVATION - LOT 5 BUILDING C & D

SCALE: 1/8" = 1'-0"

PROJECT INFORMATION
THE EXCHANGE AT ROCKWALL
3600 S. GOLIAD STREET

DEVELOPER INFORMATION CONTEX DEVELOPMENT PARTNERS

15950 SH 205

214.675.4435

TERRELL, TX 75160

Level 5 Architecture Mansfield, TX | Springdale, AR level5architecture.com

ROCKWALL, TX 75032

OWNER INFORMATION GARDNER LAND HOLDING LLC

CASE NUMBER:

15950 SH 205

214.675.4435


TERRELL, TX 75160

ARCHITECT: JUSTIN S. GILMORE LEVEL 5 ARCHITECTURE


THESE DOCUMENTS ARE

FOR REVIEW ONLY AND ARE NOT INTENDED FOR BIDDING, PERMITTING OR CONSTRUCTION PURPOSES

APPROVED:
I hereby certify that the above and foregoing site plan for a development in the City of Rockwall, Texas, was approved by the Planning & Zoning Commission of the City of Rockwall on the _____ day of _____,2025. WITNESS OUR HANDS, this ____ day of _____, 2025. Planning & Zoning Commission, Chairman Director of Planning and Zoning

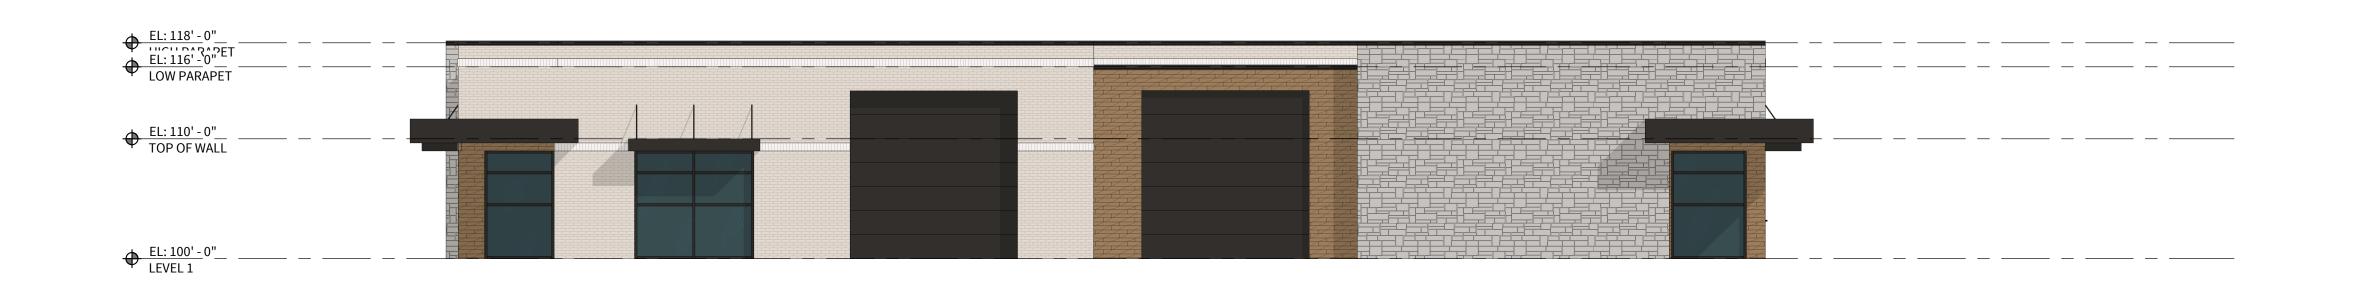


SOUTHEAST ELEVATION - LOT 6 BUILDING A SCALE: 1/8" = 1'-0"

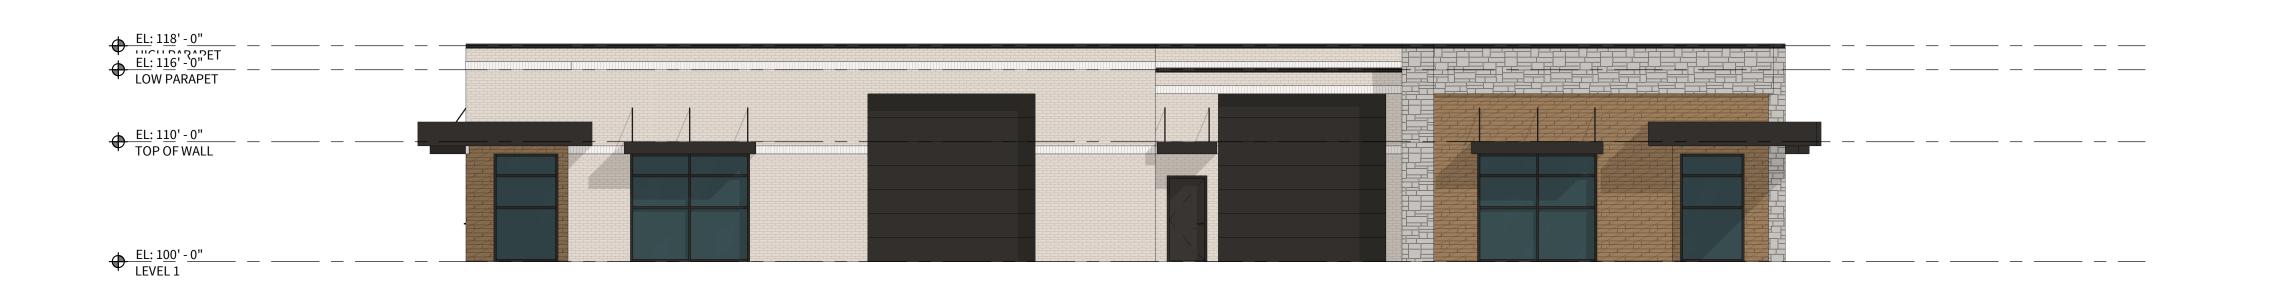

NORTHWEST ELEVATION - LOT 6 BUILDING A SCALE: 1/8" = 1'-0"



SCALE: 1/8" = 1'-0"

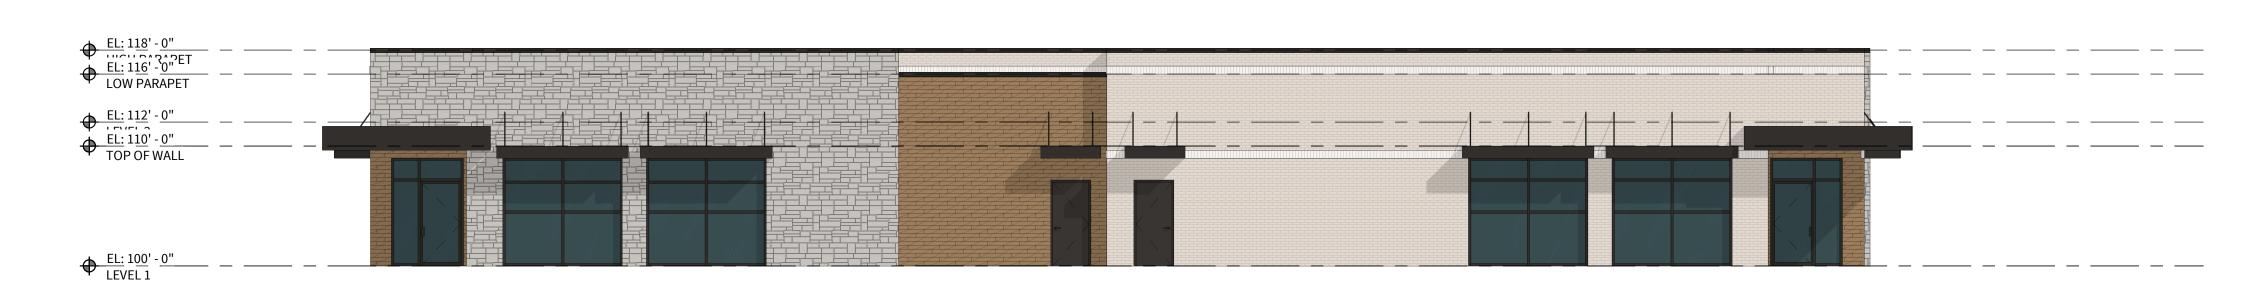

COPYRIGHT © 2024; LEVEL 5 ARCHITECTURE. EXCEPT AS MAY BE OTHERWISE PROVIDED THESE DRAWINGS & SPECIFICATIONS ARE PROPERTY OF THE ARCHITECT AND ARE ISSUED IN STRICT CONFIDENCE & SHALL NOT BE MADE AVAILABLE, REPRODUCED, COPIED, USED FOR ANY OTHER INTENDED PURPOSES, OR AS BASIS FOR MANUFACTURE OR SALE OF APPARATUS WITHOUT WRITTEN PERMISSION. COPYRIGHT © 2025; LEVEL 5 ARCHITECT AND ARE ISSUED IN STRICT CONFIDENCE & SHALL NOT BE MADE AVAILABLE, REPRODUCED, COPIED, USED FOR ANY OTHER INTENDED PURPOSES, OR AS BASIS FOR MANUFACTURE OR SALE OF APPARATUS WITHOUT WRITTEN PERMISSION.

NORTHEAST ELEVATION - LOT 6 BUILDING A

SCALE: 1/8" = 1'-0"

214.675.4435

APPROVED:
I hereby certify that the above and foregoing site plan for a development in the City of Rockwall, Texas, was approved by the Planning & Zoning Commission of the City of Rockwall on the ______ day of ______, 2025.

WITNESS OUR HANDS, this ____ day of ______, 2025.

Planning & Zoning Commission, Chairman

Director of Planning and Zoning

15950 SH 205

TERRELL, TX 75160

DEVELOPER INFORMATION CONTEX DEVELOPMENT PARTNERS

PROJECT INFORMATION
THE EXCHANGE AT ROCKWALL
3600 S. GOLIAD STREET

OWNER INFORMATION GARDNER LAND HOLDING LLC

ROCKWALL, TX 75032

CASE NUMBER:

15950 SH 205

TERRELL, TX 75160

MATERIALS CALCULATIONS MATERIAL AREA ORIENTATION NORTHEAST (FRONT) NORTHEAST (FRONT) BRICK 823 DOORS NORTHEAST (FRONT) GLAZING NORTHEAST (FRONT) SIDING NORTHEAST (FRONT) STONE 493 NORTHEAST (FRONT) 2125 NORTHWEST (LEFT) NORTHWEST (LEFT) BRICK DOORS NORTHWEST (LEFT) GLAZING NORTHWEST (LEFT) SIDING NORTHWEST (LEFT) STONE NORTHWEST (LEFT) 1892 SOUTHEAST (RIGHT) SOUTHEAST (RIGHT) DOORS SOUTHEAST (RIGHT) 392 GLAZING SOUTHEAST (RIGHT) SIDING SOUTHEAST (RIGHT) STONE 524 SOUTHEAST (RIGHT) 1897 SOUTHWEST (REAR) SOUTHWEST (REAR) BRICK 821 SOUTHWEST (REAR) DOORS SOUTHWEST (REAR) GLAZING 13 SOUTHWEST (REAR) SIDING 422 SOUTHWEST (REAR) STONE 542 2121

MATERIAL LEGEND					
FIELD BRICK	ACCENT BRICK	LEUDER STONE	WOOD LOOK FIBER CEMENT SIDING		
ACM PANEL	CAST STONE	RAL PAINT			

LEVEL 5


Level 5 Architecture

Mansfield, TX | Springdale, AR
level5architecture.com


THESE DOCUMENTS ARE FOR REVIEW ONLY AND ARE NOT INTENDED FOR BIDDING, PERMITTING OR CONSTRUCTION PURPOSES




SCALE: 1/8" = 1'-0"

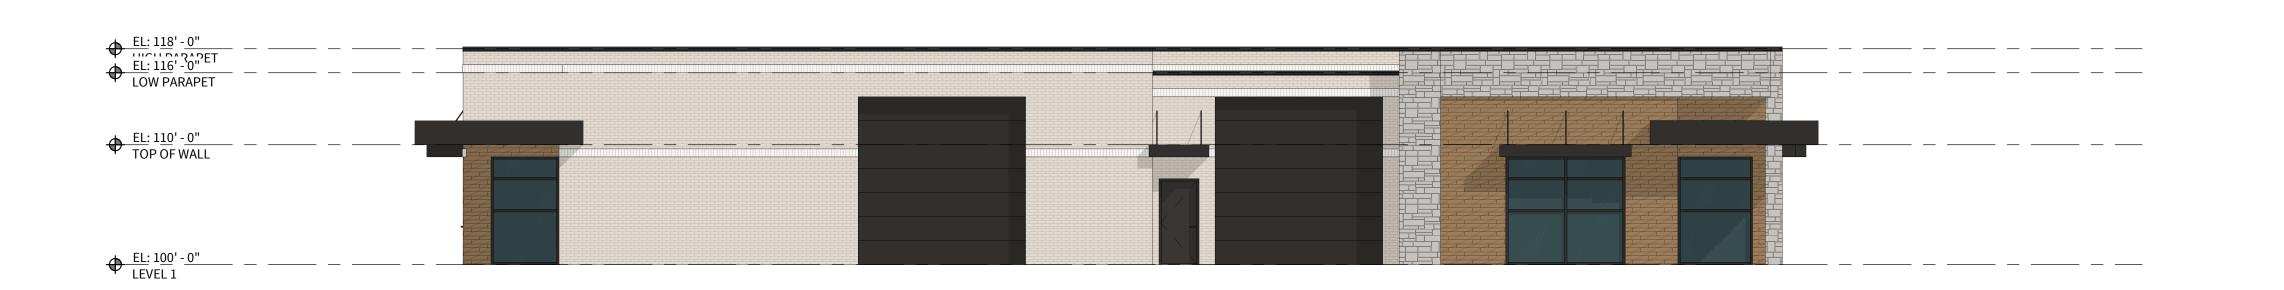

NORTHWEST ELEVATION - LOT 6 BUILDING B SCALE: 1/8" = 1'-0"

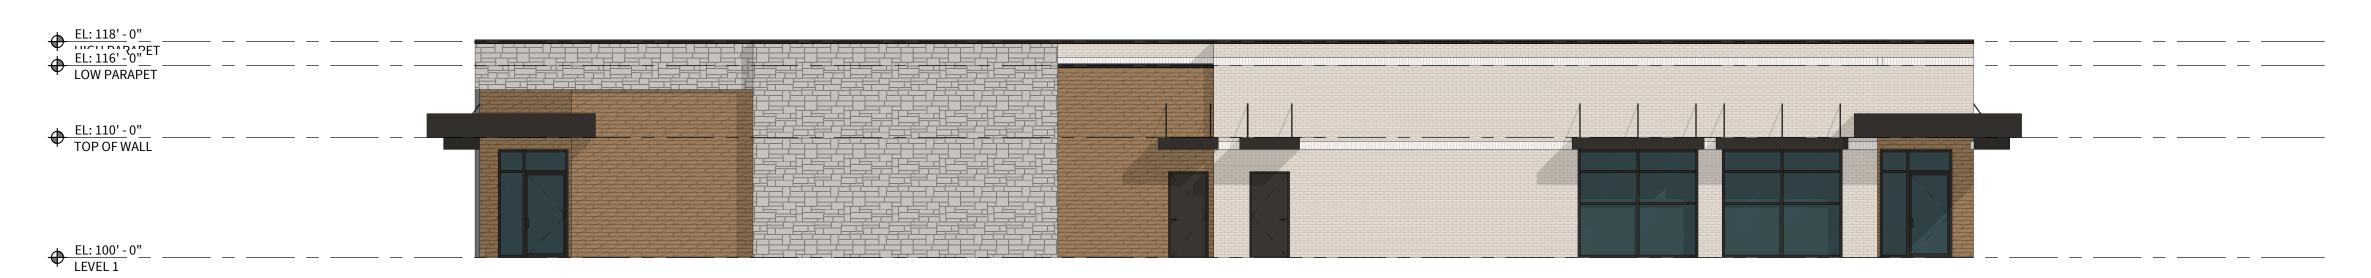

SCALE: 1/8" = 1'-0"

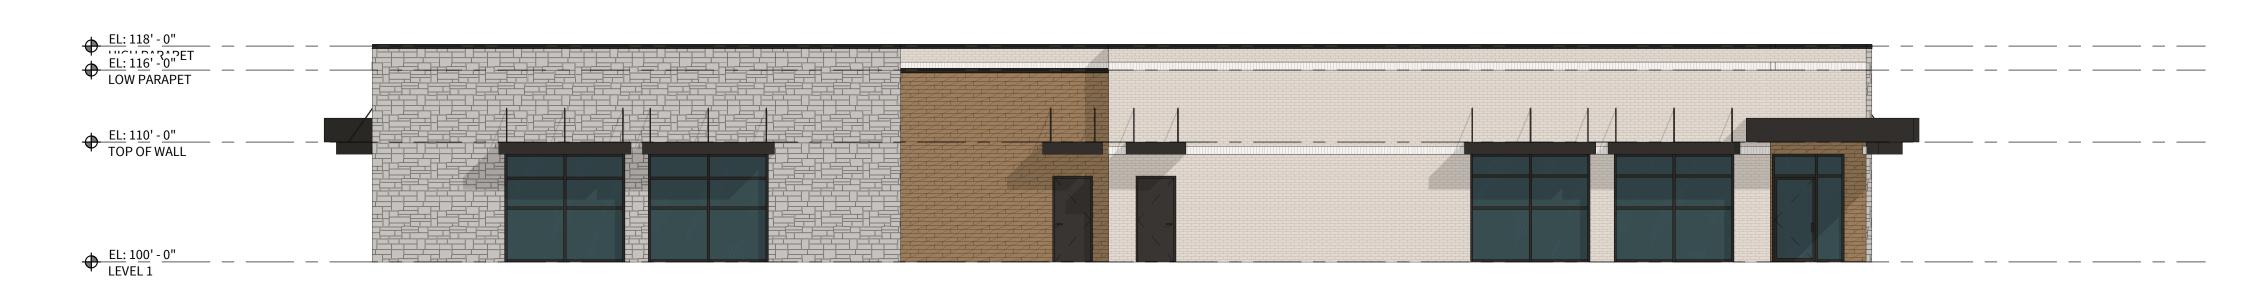

NORTHEAST ELEVATION - LOT 6 BUILDING B

SCALE: 1/8" = 1'-0"

214.675.4435

APPROVED:
I hereby certify that the above and foregoing site plan for a development in the City of Rockwall, Texas, was approved by the Planning & Zoning Commission of the City of Rockwall on the _____day of _____, 2025.

WITNESS OUR HANDS, this ____day of _____, 2025.

Planning & Zoning Commission, Chairman _____Director of Planning and Zoning

COPYRIGHT © 2024; LEVEL 5 ARCHITECTURE EXCEPT AS MAY BE OTHERWISE PROVIDED THESE DRAWINGS & SPECIFICATIONS ARE PROPERTY OF THE ARCHITECTURE EXCEPT AS MAY BE OTHERWISE PROVIDED THESE DRAWINGS & SPECIFICATIONS ARE PROPERTY OF THE ARCHITECTURE EXCEPT AS MAY BE OTHERWISE PROVIDED THESE DRAWINGS & SPECIFICATIONS ARE PROPERTY OF THE ARCHITECTURE OF SALE OF APPARATUS WITHOUT WRITTEN PERMISSION. COPYRIGHT © 2025; LEVEL 5 ARCHITECTURE

DEVELOPER INFORMATION CONTEX DEVELOPMENT PARTNERS

15950 SH 205

TERRELL, TX 75160

PROJECT INFORMATION
THE EXCHANGE AT ROCKWALL
3600 S. GOLIAD STREET

OWNER INFORMATION GARDNER LAND HOLDING LLC


ROCKWALL, TX 75032

CASE NUMBER:

15950 SH 205

TERRELL, TX 75160

MATERIALS CALCULATIONS MATERIAL AREA ORIENTATION NORTHEAST (FRONT) NORTHEAST (FRONT) BRICK 820 DOORS NORTHEAST (FRONT) NORTHEAST (FRONT) GLAZING 414 SIDING NORTHEAST (FRONT) 272 STONE NORTHEAST (FRONT) 589 2143 NORTHWEST (LEFT) NORTHWEST (LEFT) DOORS NORTHWEST (LEFT) GLAZING NORTHWEST (LEFT) SIDING NORTHWEST (LEFT) STONE NORTHWEST (LEFT) 1933 SOUTHEAST (RIGHT) SOUTHEAST (RIGHT) DOORS SOUTHEAST (RIGHT) 392 GLAZING SOUTHEAST (RIGHT) SIDING SOUTHEAST (RIGHT) STONE SOUTHEAST (RIGHT) 621 1916 SOUTHWEST (REAR) SOUTHWEST (REAR) BRICK 818 SOUTHWEST (REAR) DOORS SOUTHWEST (REAR) GLAZING SOUTHWEST (REAR) SIDING SOUTHWEST (REAR) STONE 542 2144

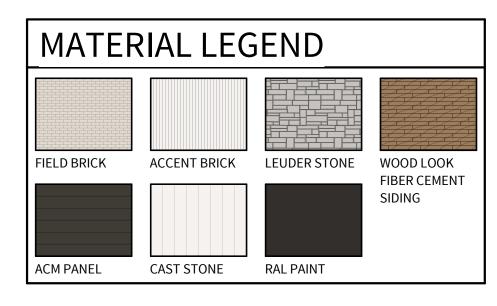




Level 5 Architecture

Mansfield, TX | Springdale, AR
level5architecture.com


THESE DOCUMENTS ARE FOR REVIEW ONLY AND ARE NOT INTENDED FOR BIDDING, PERMITTING OR CONSTRUCTION PURPOSES




SCALE: 1/8" = 1'-0"

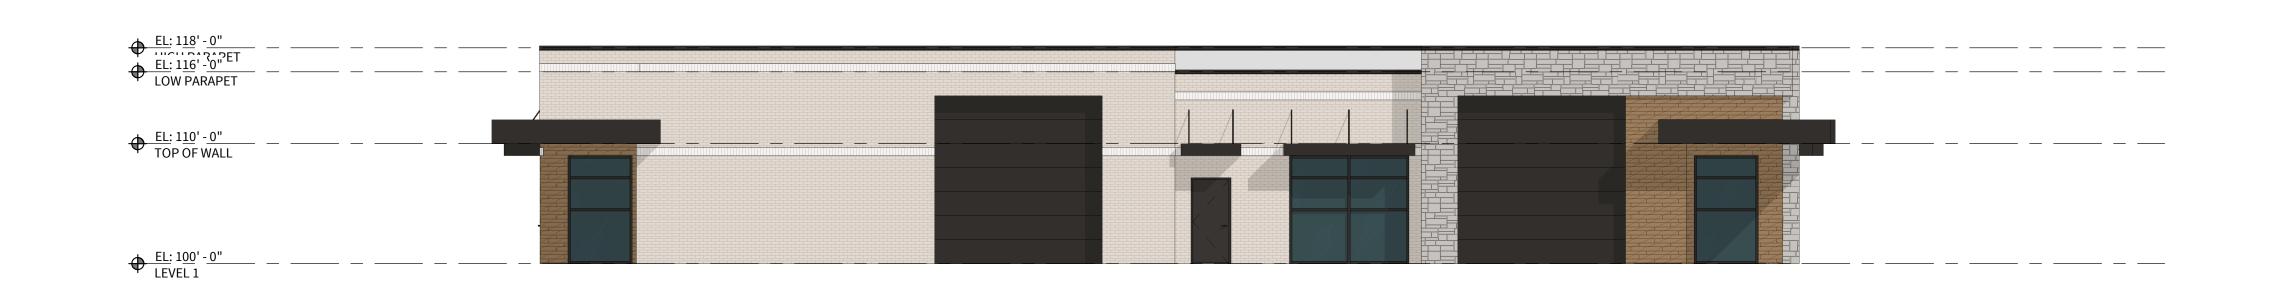

NORTHWEST ELEVATION - LOT 6 BUILDING C

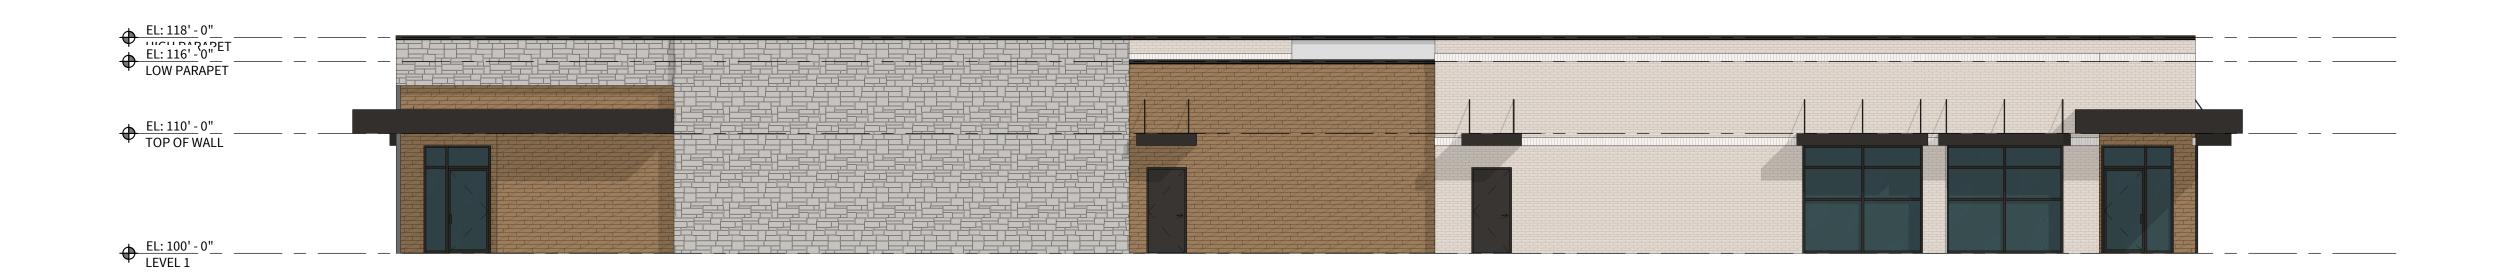

SCALE: 1/8" = 1'-0"

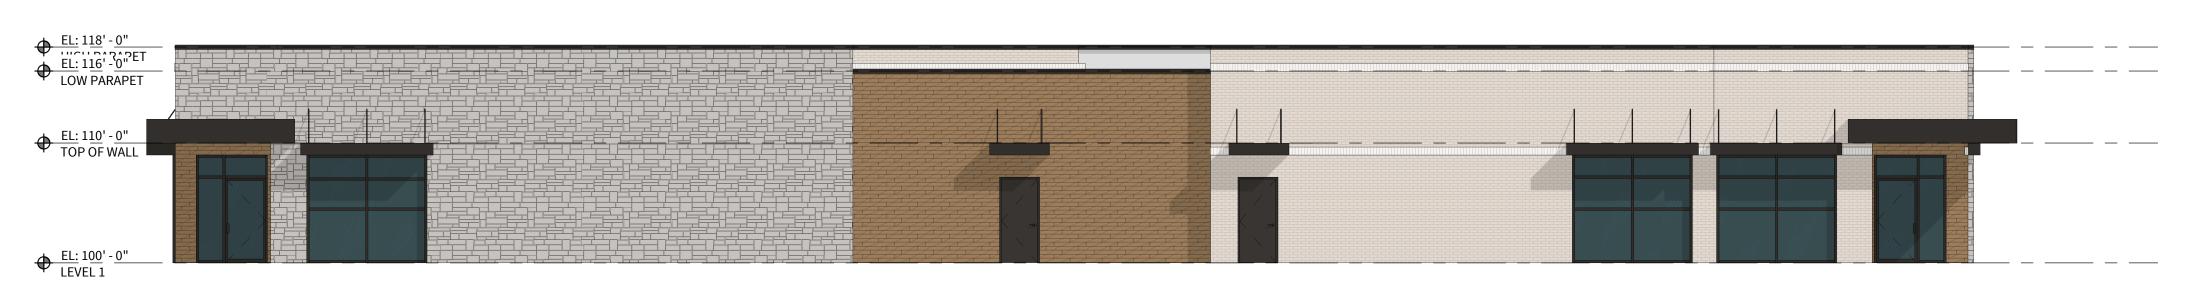

COPYRIGHT © 2024; LEVEL 5 ARCHITECTURE. EXCEPT AS MAY BE OTHERWISE PROVIDED THESE DRAWINGS & SPECIFICATIONS ARE PROPERTY OF THE ARCHITECT AND ARE ISSUED IN STRICT CONFIDENCE & SHALL NOT BE MADE AVAILABLE, REPRODUCED, COPIED, USED FOR ANY OTHER INTENDED PURPOSES, OR AS BASIS FOR MANUFACTURE OR SALE OF APPARATUS WITHOUT WRITTEN PERMISSION. COPYRIGHT © 2025; LEVEL 5 ARCHITECT AND ARE ISSUED IN STRICT CONFIDENCE & SHALL NOT BE MADE AVAILABLE, REPRODUCED, COPIED, USED FOR ANY OTHER INTENDED PURPOSES, OR AS BASIS FOR MANUFACTURE OR SALE OF APPARATUS WITHOUT WRITTEN PERMISSION.

NORTHEAST ELEVATION - LOT 6 BUILDING C

SCALE: 1/8" = 1'-0"

OWNER INFORMATION
GARDNER LAND HOLDING LLC
15950 SH 205
TERRELL, TX 75160
214.675.4435

APPROVED:
I hereby certify that the above and foregoing site plan for a development in the City of Rockwall, Texas, was approved by the Planning & Zoning Commission of the City of Rockwall on the ______ day of _____, 2025.

WITNESS OUR HANDS, this ____ day of _____, 2025.

Planning & Zoning Commission, Chairman

Director of Planning and Zoning

PROJECT INFORMATION
THE EXCHANGE AT ROCKWALL
3600 S. GOLIAD STREET

ROCKWALL, TX 75032

CASE NUMBER:

MATERIALS CALCULATIONS MATERIAL ORIENTATION NORTHEAST (FRONT) NORTHEAST (FRONT) BRICK DOORS NORTHEAST (FRONT) NORTHEAST (FRONT) GLAZING 378 15 SIDING NORTHEAST (FRONT) STONE 814 NORTHEAST (FRONT) 2575 NORTHWEST (LEFT) NORTHWEST (LEFT) BRICK DOORS NORTHWEST (LEFT) GLAZING NORTHWEST (LEFT) SIDING NORTHWEST (LEFT) STONE NORTHWEST (LEFT) 1811 SOUTHWEAT (RIGHT) SOUTHWEAT (RIGHT) DOORS SOUTHWEAT (RIGHT) GLAZING SOUTHWEAT (RIGHT) SIDING SOUTHWEAT (RIGHT) STONE 423 SOUTHWEAT (RIGHT) 1775 SOUTHWEST (REAR) SOUTHWEST (REAR) BRICK 843 SOUTHWEST (REAR) DOORS SOUTHWEST (REAR) GLAZING SOUTHWEST (REAR) SIDING 623 SOUTHWEST (REAR) STONE 765 30% 2559


	RIAL LEG		
FIELD BRICK	ACCENT BRICK	LEUDER STONE	WOOD LOO FIBER CEME SIDING
ACM PANEL	CAST STONE	RAL PAINT	



Level 5 Architecture

Mansfield, TX | Springdale, AR
level5architecture.com


THESE DOCUMENTS ARE FOR REVIEW ONLY AND ARE NOT INTENDED FOR BIDDING, PERMITTING OR CONSTRUCTION PURPOSES

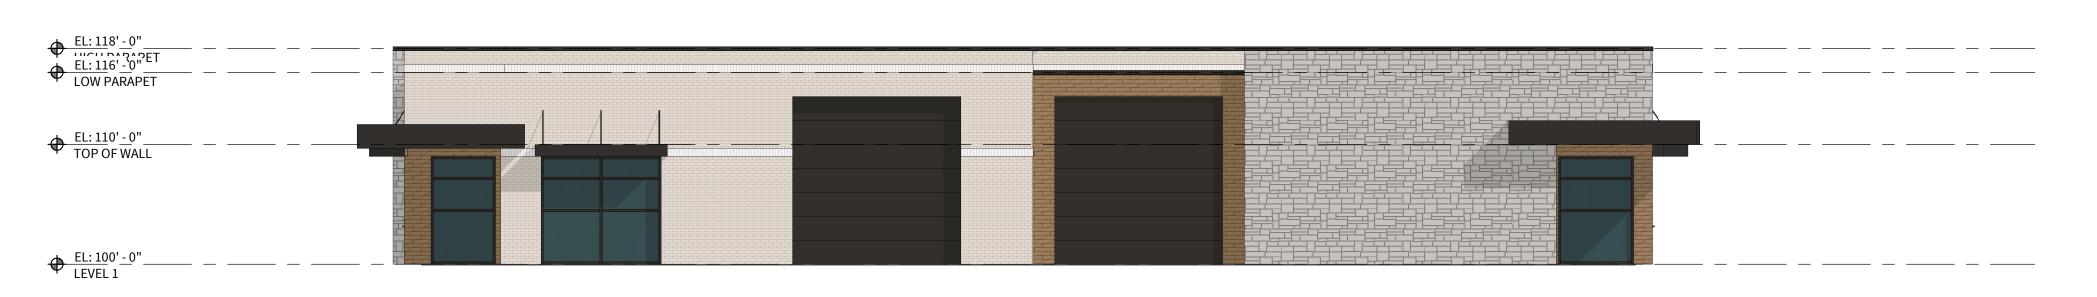


SCALE: 1/8" = 1'-0"



NORTHWEST ELEVATION - LOT 6 BUILDING D SCALE: 1/8" = 1'-0"

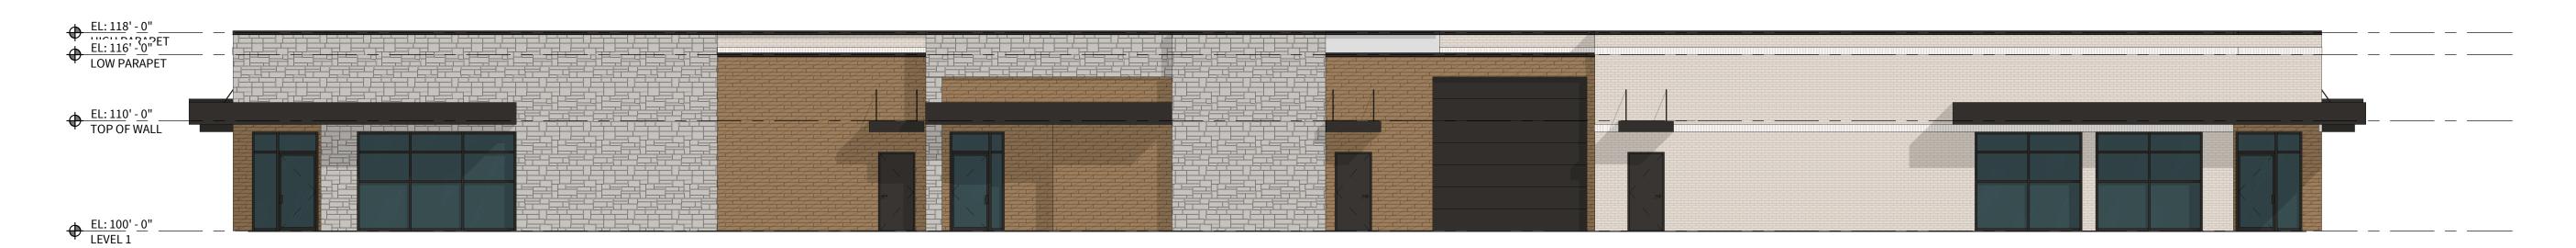

SCALE: 1/8" = 1'-0"

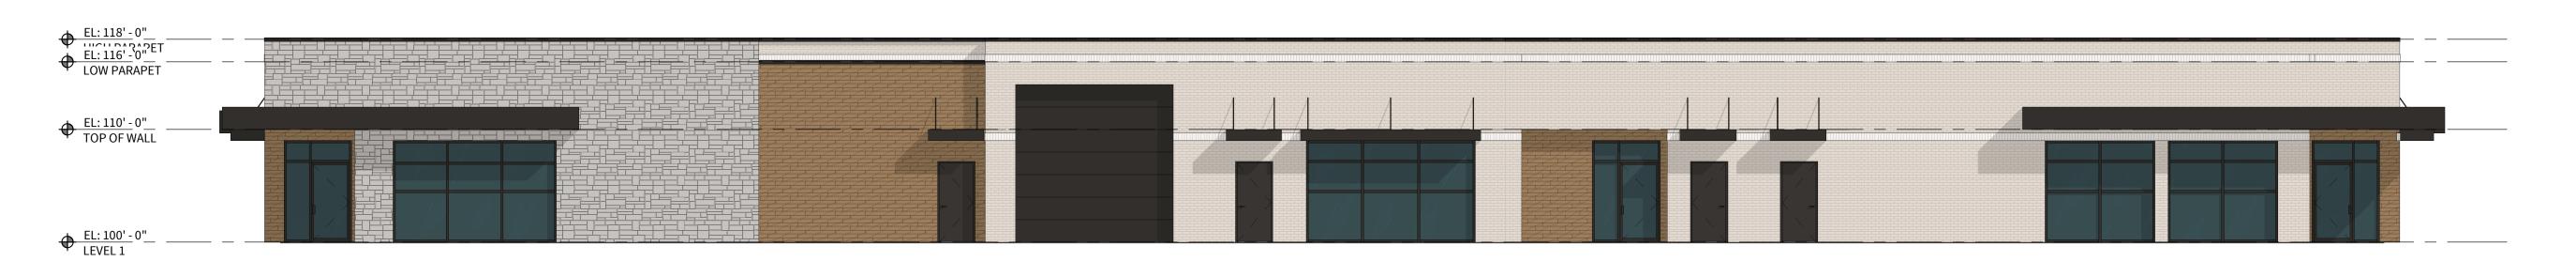

COPYRIGHT © 2024; LEVEL 5 ARCHITECTURE. EXCEPT AS MAY BE OTHERWISE PROVIDED THESE DRAWINGS & SPECIFICATIONS ARE PROPERTY OF THE ARCHITECT AND ARE ISSUED IN STRICT CONFIDENCE & SHALL NOT BE MADE AVAILABLE, REPRODUCED, COPIED, USED FOR ANY OTHER INTENDED PURPOSES, OR AS BASIS FOR MANUFACTURE OR SALE OF APPARATUS WITHOUT WRITTEN PERMISSION. COPYRIGHT © 2025; LEVEL 5 ARCHITECT AND ARE ISSUED IN STRICT CONFIDENCE & SHALL NOT BE MADE AVAILABLE, REPRODUCED, COPIED, USED FOR ANY OTHER INTENDED PURPOSES, OR AS BASIS FOR MANUFACTURE OR SALE OF APPARATUS WITHOUT WRITTEN PERMISSION.

NORTHEAST ELEVATION - LOT 6 BUILDING D

SCALE: 1/8" = 1'-0"

OWNER INFORMATION
GARDNER LAND HOLDING LLC
15950 SH 205
TERRELL, TX 75160
214.675.4435

APPROVED:
I hereby certify that the above and foregoing site plan for a development in the City of Rockwall, Texas, was approved by the Planning & Zoning Commission of the City of Rockwall on the ______ day of _____, 2025.

WITNESS OUR HANDS, this ____ day of _____, 2025.

Planning & Zoning Commission, Chairman


Director of Planning and Zoning

PROJECT INFORMATION
THE EXCHANGE AT ROCKWALL
3600 S. GOLIAD STREET

ROCKWALL, TX 75032

CASE NUMBER:

MATERIALS CALCULATIONS MATERIAL ORIENTATION NORTHEAST (FRONT) NORTHEAST (FRONT) BRICK 1387 DOORS NORTHEAST (FRONT) NORTHEAST (FRONT) GLAZING 602 19 SIDING NORTHEAST (FRONT) 13 STONE 518 NORTHEAST (FRONT) 3216 NORTHWEST (LEFT) NORTHWEST (LEFT) BRICK DOORS NORTHWEST (LEFT) GLAZING NORTHWEST (LEFT) SIDING NORTHWEST (LEFT) STONE NORTHWEST (LEFT) 1798 SOUTHEAST (RIGHT) SOUTHEAST (RIGHT) DOORS SOUTHEAST (RIGHT) GLAZING SOUTHEAST (RIGHT) SIDING SOUTHEAST (RIGHT) STONE 502 SOUTHEAST (RIGHT) 1791 SOUTHWEST (REAR) SOUTHWEST (REAR) BRICK 850 SOUTHWEST (REAR) DOORS SOUTHWEST (REAR) GLAZING SOUTHWEST (REAR) SIDING 698 SOUTHWEST (REAR) STONE 878 3152

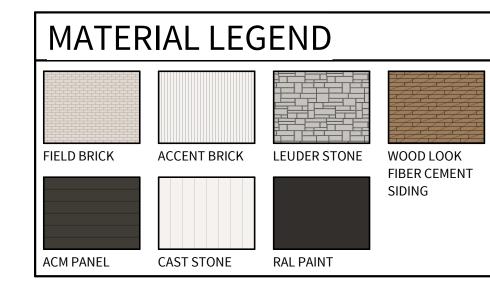




Level 5 Architecture

Mansfield, TX | Springdale, AR
level5architecture.com

THESE DOCUMENTS ARE
FOR REVIEW ONLY AND
ARE NOT INTENDED FOR
BIDDING, PERMITTING OR
CONSTRUCTION PURPOSES

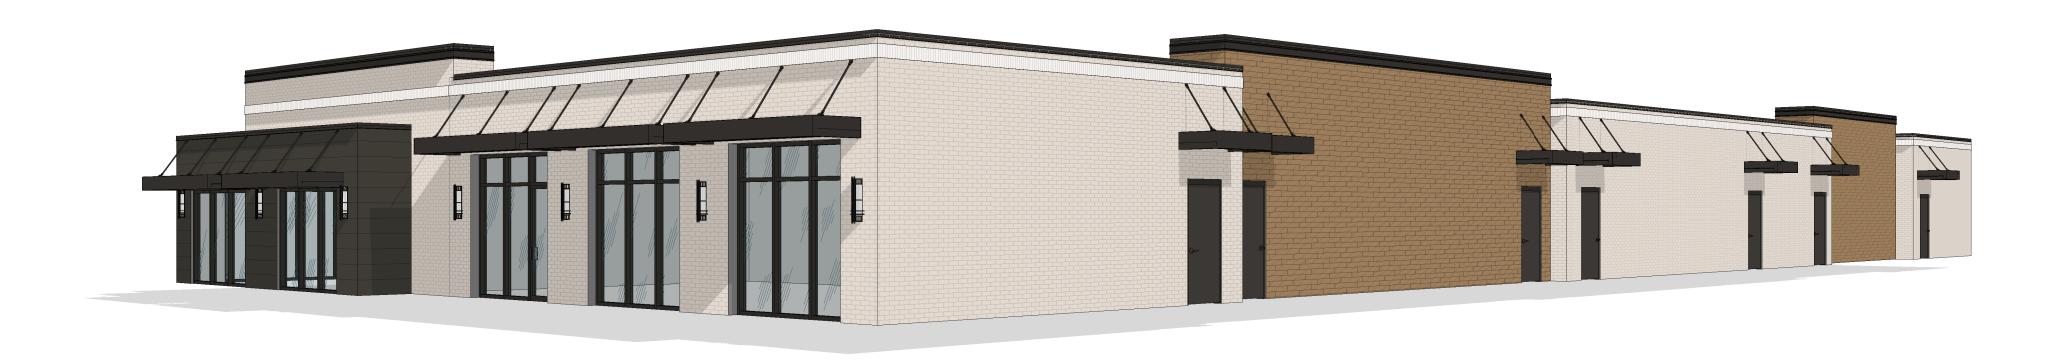

PERSPETIVE VIEW - LOT 2 BUILDING A

SCALE:



PERSPETIVE VIEW - LOT 2 BUILDING A

SCALE:

PROJECT INFORMATION
THE EXCHANGE AT ROCKWALL
3600 S. GOLIAD STREET
ROCKWALL, TX 75032
CASE NUMBER:

OWNER INFORMATION GARDNER LAND HOLDING LLC 15950 SH 205 TERRELL, TX 75160

214.675.4435

DEVELOPER INFORMATION CONTEX DEVELOPMENT PARTNERS 15950 SH 205 TERRELL, TX 75160 214.675.4435

APPROVED:
I hereby certify that the above and foregoing site plan for a development in the City of Rockwall, Texas, was approved by the Planning & Zoning Commission of the City of Rockwall on the _____ day of _____,2025.

WITNESS OUR HANDS, this ____ day of _____, 2025.

Planning & Zoning Commission, Chairman Director of Planning and Zoning

ARCHITECT: JUSTIN S. GILMORE LEVEL 5 ARCHITECTURE

Level 5 Architecture


Mansfield, TX | Springdale, AR level5architecture.com

THESE DOCUMENTS ARE

FOR REVIEW ONLY AND

ARE NOT INTENDED FOR BIDDING, PERMITTING OR

CONSTRUCTION PURPOSES

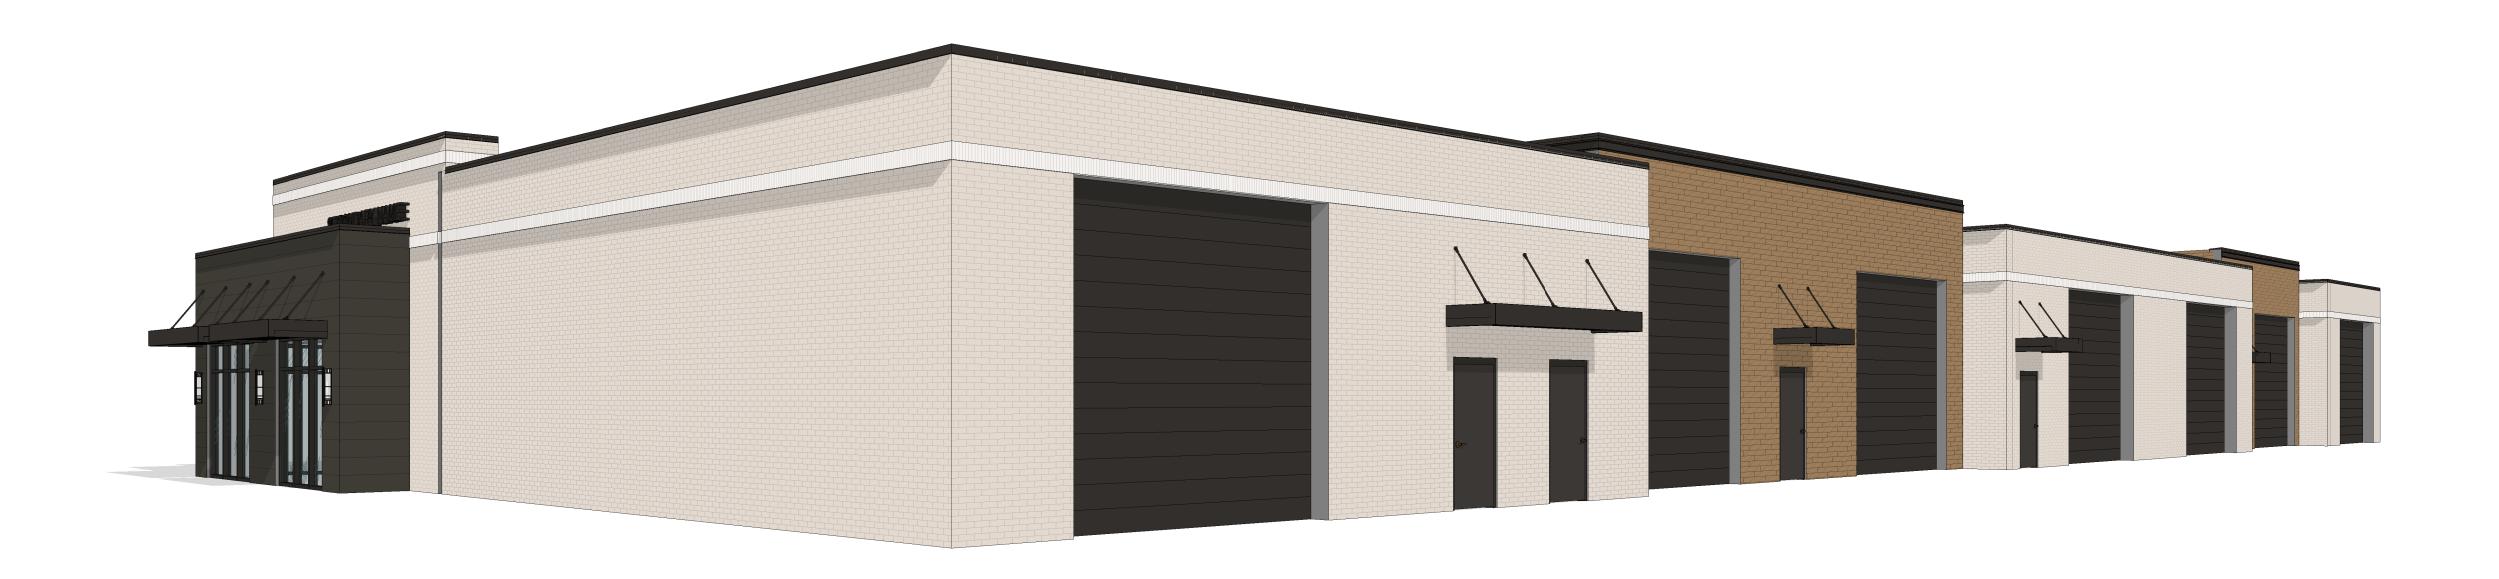

PERSPECTIVE - LOT 4 BUILDING A

SCALE:



PERSPECTIVE - LOT 4 BUILDING A

SCALE:

PROJECT INFORMATION		
THE EXCHANGE AT ROCKV	/ALL	
3600 S. GOLIAD STREET		
ROCKWALL, TX 75032		
CASE NUMBER:		

OWNER INFORMATION GARDNER LAND HOLDING LLC 15950 SH 205 TERRELL, TX 75160

214.675.4435

DEVELOPER INFORMATION CONTEX DEVELOPMENT PARTNERS 15950 SH 205 TERRELL, TX 75160 214.675.4435

APPROVED:
I hereby certify that the above and foregoing site plan for a development in the City of Rockwall, Texas, was approved by the Planning & Zoning Commission of the City of Rockwall on the _____ day of _____,2025.

WITNESS OUR HANDS, this ____ day of _____, 2025.

Planning & Zoning Commission, Chairman

ARCHITECT:

JUSTIN S. GILMORE

LEVEL 5 ARCHITECTURE

Level 5 Architecture

Mansfield, TX | Springdale, AR level5architecture.com

THESE DOCUMENTS ARE

FOR REVIEW ONLY AND

ARE NOT INTENDED FOR BIDDING, PERMITTING OR


CONSTRUCTION PURPOSES

11/1/2023 10:36:46 AIM

COPYRIGHT © 2024; LEVEL 5 ARCHITECTURE. EXCEPT AS MAY BE OTHERWISE PROVIDED THESE DRAWINGS & SPECIFICATIONS ARE PROPERTY OF THE ARCHITECTURE ON TH



PERSPECTIVE - LOT 5 BUILDING A & B
SCALE:

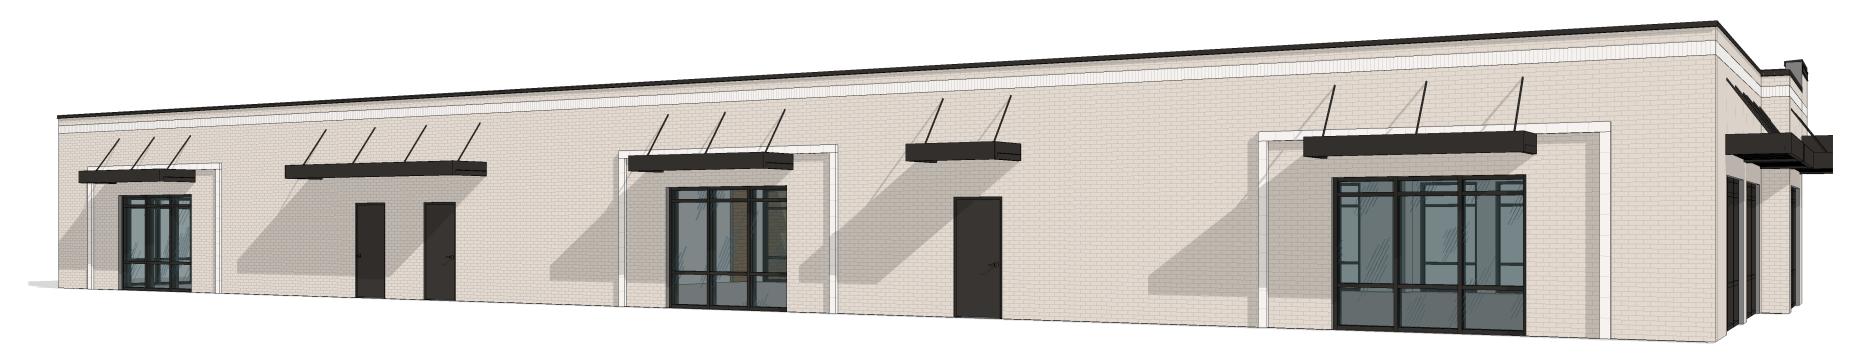

PERSPECTIVE - LOT 5 BUILDING A & B

SCALE:



PERSPECTIVE - LOT 5 BUILDING A & B

SCALE:



PERSPECTIVE - LOT 5 BUILDING A & B

SCALE:

PROJECT INFORMATION
THE EXCHANGE AT ROCKWALL
3600 S. GOLIAD STREET
ROCKWALL, TX 75032
CASE NI IMBED.

OWNER INFORMATION GARDNER LAND HOLDING LLC 15950 SH 205 TERRELL, TX 75160 214.675.4435

DEVELOPER INFORMATION CONTEX DEVELOPMENT PARTNERS 15950 SH 205 TERRELL, TX 75160 214.675.4435

APPROVED:
I hereby certify that the above and foregoing site plan for a development in the City of Rockwall, Texas, was approved by the Planning & Zoning Commission of the City of Rockwall on the _____ day of _____,2025.

Planning & Zoning Commission, Chairman

ARCHITECT: JUSTIN S. GILMORE LEVEL 5 ARCHITECTURE Director of Planning and Zoning

Level 5 Architecture

Mansfield, TX | Springdale, AR level5architecture.com

THESE DOCUMENTS ARE

FOR REVIEW ONLY AND


ARE NOT INTENDED FOR BIDDING, PERMITTING OR CONSTRUCTION PURPOSES

WITNESS OUR HANDS, this ____ day of _____, 2025.



PERSPECTIVE - LOT 5 BUILDING C & D

SCALE:

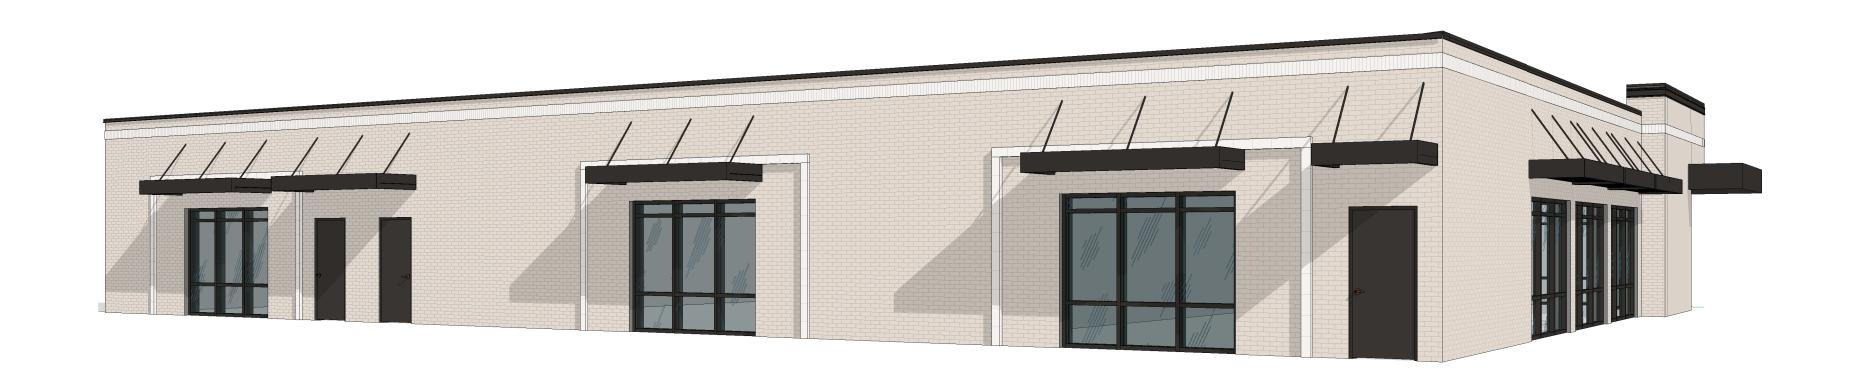

3 PERSPECTIVE - LOT 5 BUILDING C & D

SCALE:



PERSPECTIVE - LOT 5 BUILDING C & D

SCALE:



PROJECT INFORMATION
THE EXCHANGE AT ROCKWALL
3600 S. GOLIAD STREET
ROCKWALL, TX 75032
CASE NUMBER:

TERRELL, TX 75160 214.675.4435

OWNER INFORMATION GARDNER LAND HOLDING LLC 15950 SH 205

DEVELOPER INFORMATION CONTEX DEVELOPMENT PARTNERS 15950 SH 205 TERRELL, TX 75160 214.675.4435

Director of Planning and Zoning

APPROVED:
I hereby certify that the above and foregoing site plan for a development in the City of Rockwall, Texas, was approved by the Planning & Zoning Commission of the City of Rockwall on the _____ day of _____,2025.

Planning & Zoning Commission, Chairman

WITNESS OUR HANDS, this _____ day of _____, 2025.

ARCHITECT: JUSTIN S. GILMORE LEVEL 5 ARCHITECTURE

Level 5 Architecture

Mansfield, TX | Springdale, AR level5architecture.com

THESE DOCUMENTS ARE

FOR REVIEW ONLY AND

ARE NOT INTENDED FOR BIDDING, PERMITTING OR CONSTRUCTION PURPOSES


PERSPECTIVE - LOT 5 BUILDING C & D

SCALE:

COPYRIGHT © 2024; LEVEL 5 ARCHITECTURE. EXCEPT AS MAY BE OTHERWISE PROVIDED THESE DRAWINGS & SPECIFICATIONS ARE PROPERTY OF THE ARCHITECT AND ARE ISSUED IN STRICT CONFIDENCE & SHALL NOT BE MADE AVAILABLE, REPRODUCED, COPIED, USED FOR ANY OTHER INTENDED PURPOSES, OR AS BASIS FOR MANUFACTURE OR SALE OF APPARATUS WITHOUT WRITTEN PERMISSION. COPYRIGHT © 2025; LEVEL 5 ARCHITECTURE



3 PERSPECTIVE - LOT 6 BUILDING A
SCALE:

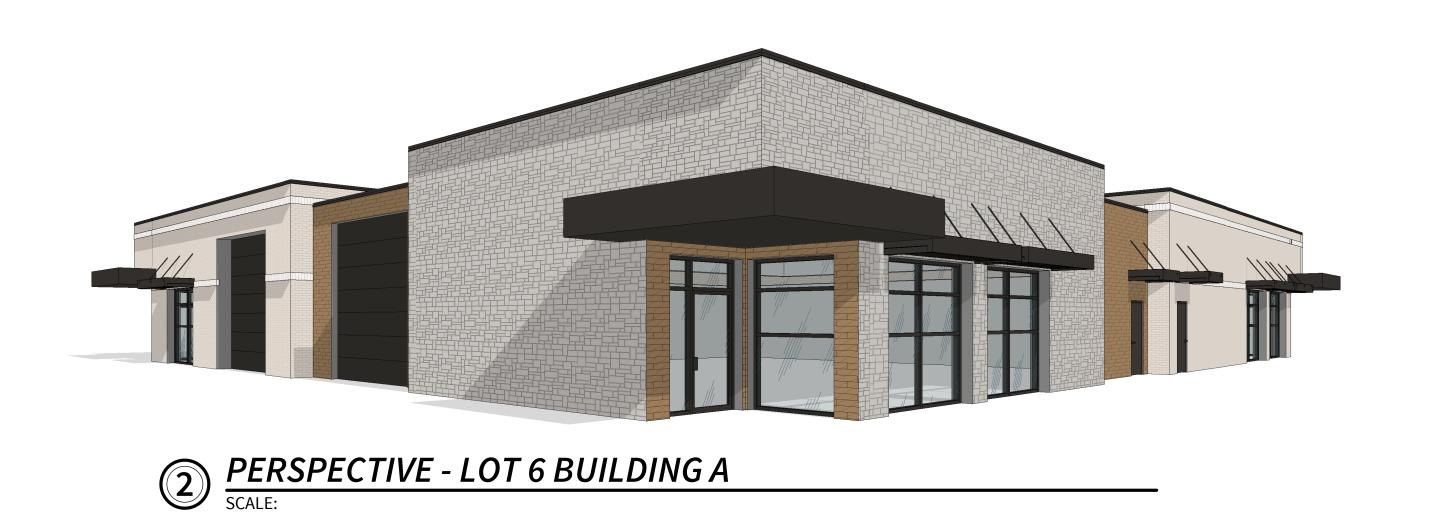



PERSPECTIVE - LOT 6 BUILDING A

SCALE:

PROJECT INFORMATION
THE EXCHANGE AT ROCKWALL
3600 S. GOLIAD STREET
ROCKWALL, TX 75032
CASE NUMBER:

OWNER INFORMATION
GARDNER LAND HOLDING LLC
15950 SH 205
TERRELL, TX 75160
214.675.4435

DEVELOPER INFORMATION CONTEX DEVELOPMENT PARTNERS 15950 SH 205 TERRELL, TX 75160 214.675.4435

APPROVED:
I hereby certify that the above and foregoing site plan for a development in the City of Rockwall, Texas, was approved by the Planning & Zoning Commission of the City of Rockwall on the day of 2025

WITNESS OUI BUILDING A 3D VIEWS

Planning & Zoning Commission, Chairman Director of Planning and Zoning

ARCHITECT: JUSTIN S. GILMORE LEVEL 5 ARCHITECTURE

Level 5 Architecture

Mansfield, TX | Springdale, AR level5architecture.com

THESE DOCUMENTS ARE

FOR REVIEW ONLY AND

ARE NOT INTENDED FOR BIDDING, PERMITTING OR CONSTRUCTION PURPOSES


17/2023 10:03:23 AIVI

COPYRIGHT © 2024; LEVEL 5 ARCHITECTURE. EXCEPT AS MAY BE OTHERWISE PROVIDED THESE DRAWINGS & SPECIFICATIONS ARE PROPERTY OF THE ARCHITECTURE OR SALE OF APPARATUS WITHOUT WRITTEN PERMISSION. COPYRIGHT © 2025; LEVEL 5 ARCHITECTURE



PERSPECTIVE - LOT 6 BUILDING B

SCALE:

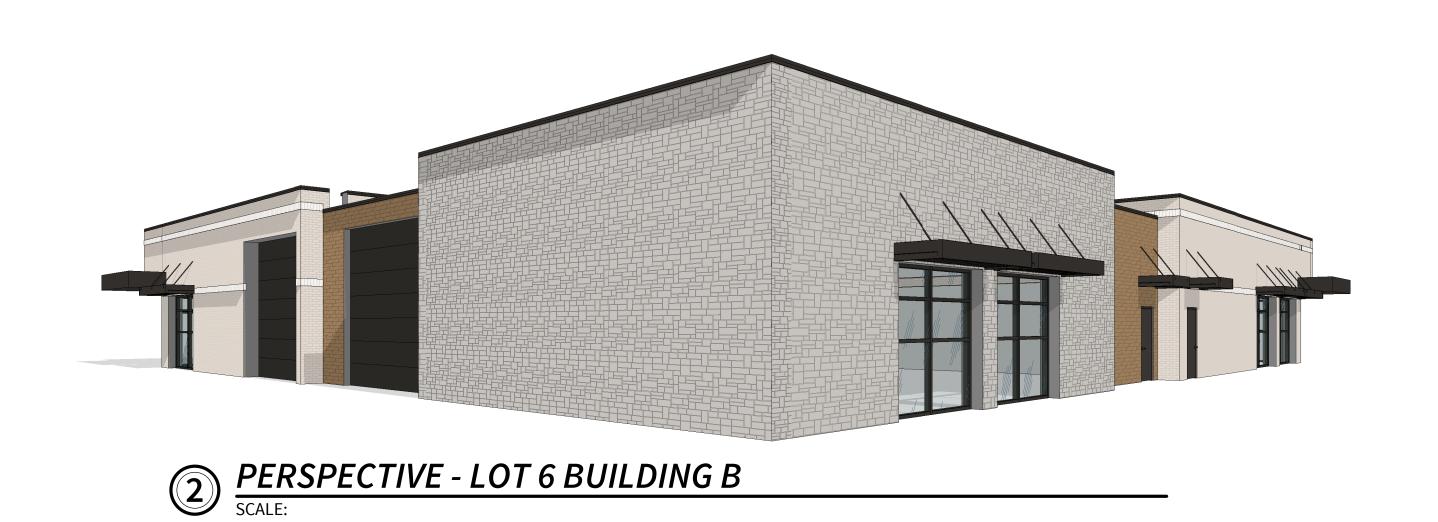



PERSPECTIVE - LOT 6 BUILDING B

SCALE:

COPYRIGHT © 2024; LEVEL 5 ARCHITECTURE. EXCEPT AS MAY BE OTHERWISE PROVIDED THESE DRAWINGS & SPECIFICATIONS ARE PROPERTY OF THE ARCHITECT AND ARE ISSUED IN STRICT CONFIDENCE & SHALL NOT BE MADE AVAILABLE, REPRODUCED, COPIED, USED FOR ANY OTHER INTENDED PURPOSES, OR AS BASIS FOR MANUFACTURE OR SALE OF APPARATUS WITHOUT WRITTEN PERMISSION. COPYRIGHT © 2025; LEVEL 5 ARCHITECTURE

PROJECT INFORMATION
THE EXCHANGE AT ROCKWALL
3600 S. GOLIAD STREET
ROCKWALL, TX 75032
CASE NUMBER:

OWNER INFORMATION GARDNER LAND HOLDING LLC 15950 SH 205 TERRELL, TX 75160 214.675.4435 DEVELOPER INFORMATION CONTEX DEVELOPMENT PARTNERS 15950 SH 205 TERRELL, TX 75160 214.675.4435

APPROVED:
I hereby certify that the above and foregoing site plan for a development in the City of Rockwall, Texas, was approved by the Planning & Zoning Commission of the City of Rockwall on the day of 2025

WITNESS OUI BUILDING A 3D VIEWS

Planning & Zoning Commission, Chairman

Director of Planning and Zoning

LEVEL 5

Level 5 Architecture

Mansfield, TX | Springdale, AR
level5architecture.com

THESE DOCUMENTS ARE
FOR REVIEW ONLY AND
ARE NOT INTENDED FOR
BIDDING, PERMITTING OR
CONSTRUCTION PURPOSES



PERSPECTIVE - LOT 6 BUILDING C

SCALE:



PERSPECTIVE - LOT 6 BUILDING C
SCALE:



PERSPECTIVE - LOT 6 BUILDING C

SCALE:

PROJECT INFORMATION
THE EXCHANGE AT ROCKWALL
3600 S. GOLIAD STREET
ROCKWALL, TX 75032
CASE NUMBER:

OWNER INFORMATION GARDNER LAND HOLDING LLC 15950 SH 205 TERRELL, TX 75160 214.675.4435 DEVELOPER INFORMATION CONTEX DEVELOPMENT PARTNERS 15950 SH 205 TERRELL, TX 75160 214.675.4435

APPROVED:
I hereby certify that the above and foregoing site plan for a development in the City of Rockwall, Texas, was approved by the Planning & Zoning Commission of the City of Rockwall on the day of 2025

WITNESS OUI BUILDING C 3D VIEWS

Planning & Zoning Commission, Chairman

Director of Planning and Zoning

LEVEL 5 Level 5 Architecture

THESE DOCUMENTS ARE
FOR REVIEW ONLY AND
ARE NOT INTENDED FOR
BIDDING, PERMITTING OR
CONSTRUCTION PURPOSES

Mansfield, TX | Springdale, AR level5architecture.com



PERSPECTIVE - LOT 6 BUILDING D

SCALE:



PERSPECTIVE - LOT 6 BUILDING D

SCALE:



PERSPECTIVE - LOT 6 BUILDING D

SCALE:



OWNER INFORMATION GARDNER LAND HOLDING LLC 15950 SH 205 TERRELL, TX 75160 214.675.4435

DEVELOPER INFORMATION CONTEX DEVELOPMENT PARTNERS 15950 SH 205 TERRELL, TX 75160 214.675.4435

APPROVED:
I hereby certify that the above and foregoing site plan for a development in the City of Rockwall, Texas, was approved by the Planning & Zoning Commission of the City of Rockwall on the _____ day of _____,2025.

Planning & Zoning Commission, Chairman

WITNESS OUR HANDS, this ____ day of _____, 2025.

Director of Planning and Zoning

ARCHITECT:

JUSTIN S. GILMORE

LEVEL 5 ARCHITECTURE


THESE DOCUMENTS ARE

FOR REVIEW ONLY AND

ARE NOT INTENDED FOR BIDDING, PERMITTING OR CONSTRUCTION PURPOSES

17/2023 10:22:27 AIVI

COPYRIGHT © 2024; LEVEL 5 ARCHITECTURE. EXCEPT AS MAY BE OTHERWISE PROVIDED THESE DRAWINGS & SPECIFICATIONS ARE PROPERTY OF THE ARCHITECT AND ARE ISSUED IN STRICT CONFIDENCE & SHALL NOT BE MADE AVAILABLE, REPRODUCED, COPIED, USED FOR ANY OTHER INTENDED PURPOSES, OR AS BASIS FOR MANUFACTURE OR SALE OF APPARATUS WITHOUT WRITTEN PERMISSION. COPYRIGHT © 2025; LEVEL 5 ARCHITECTURE

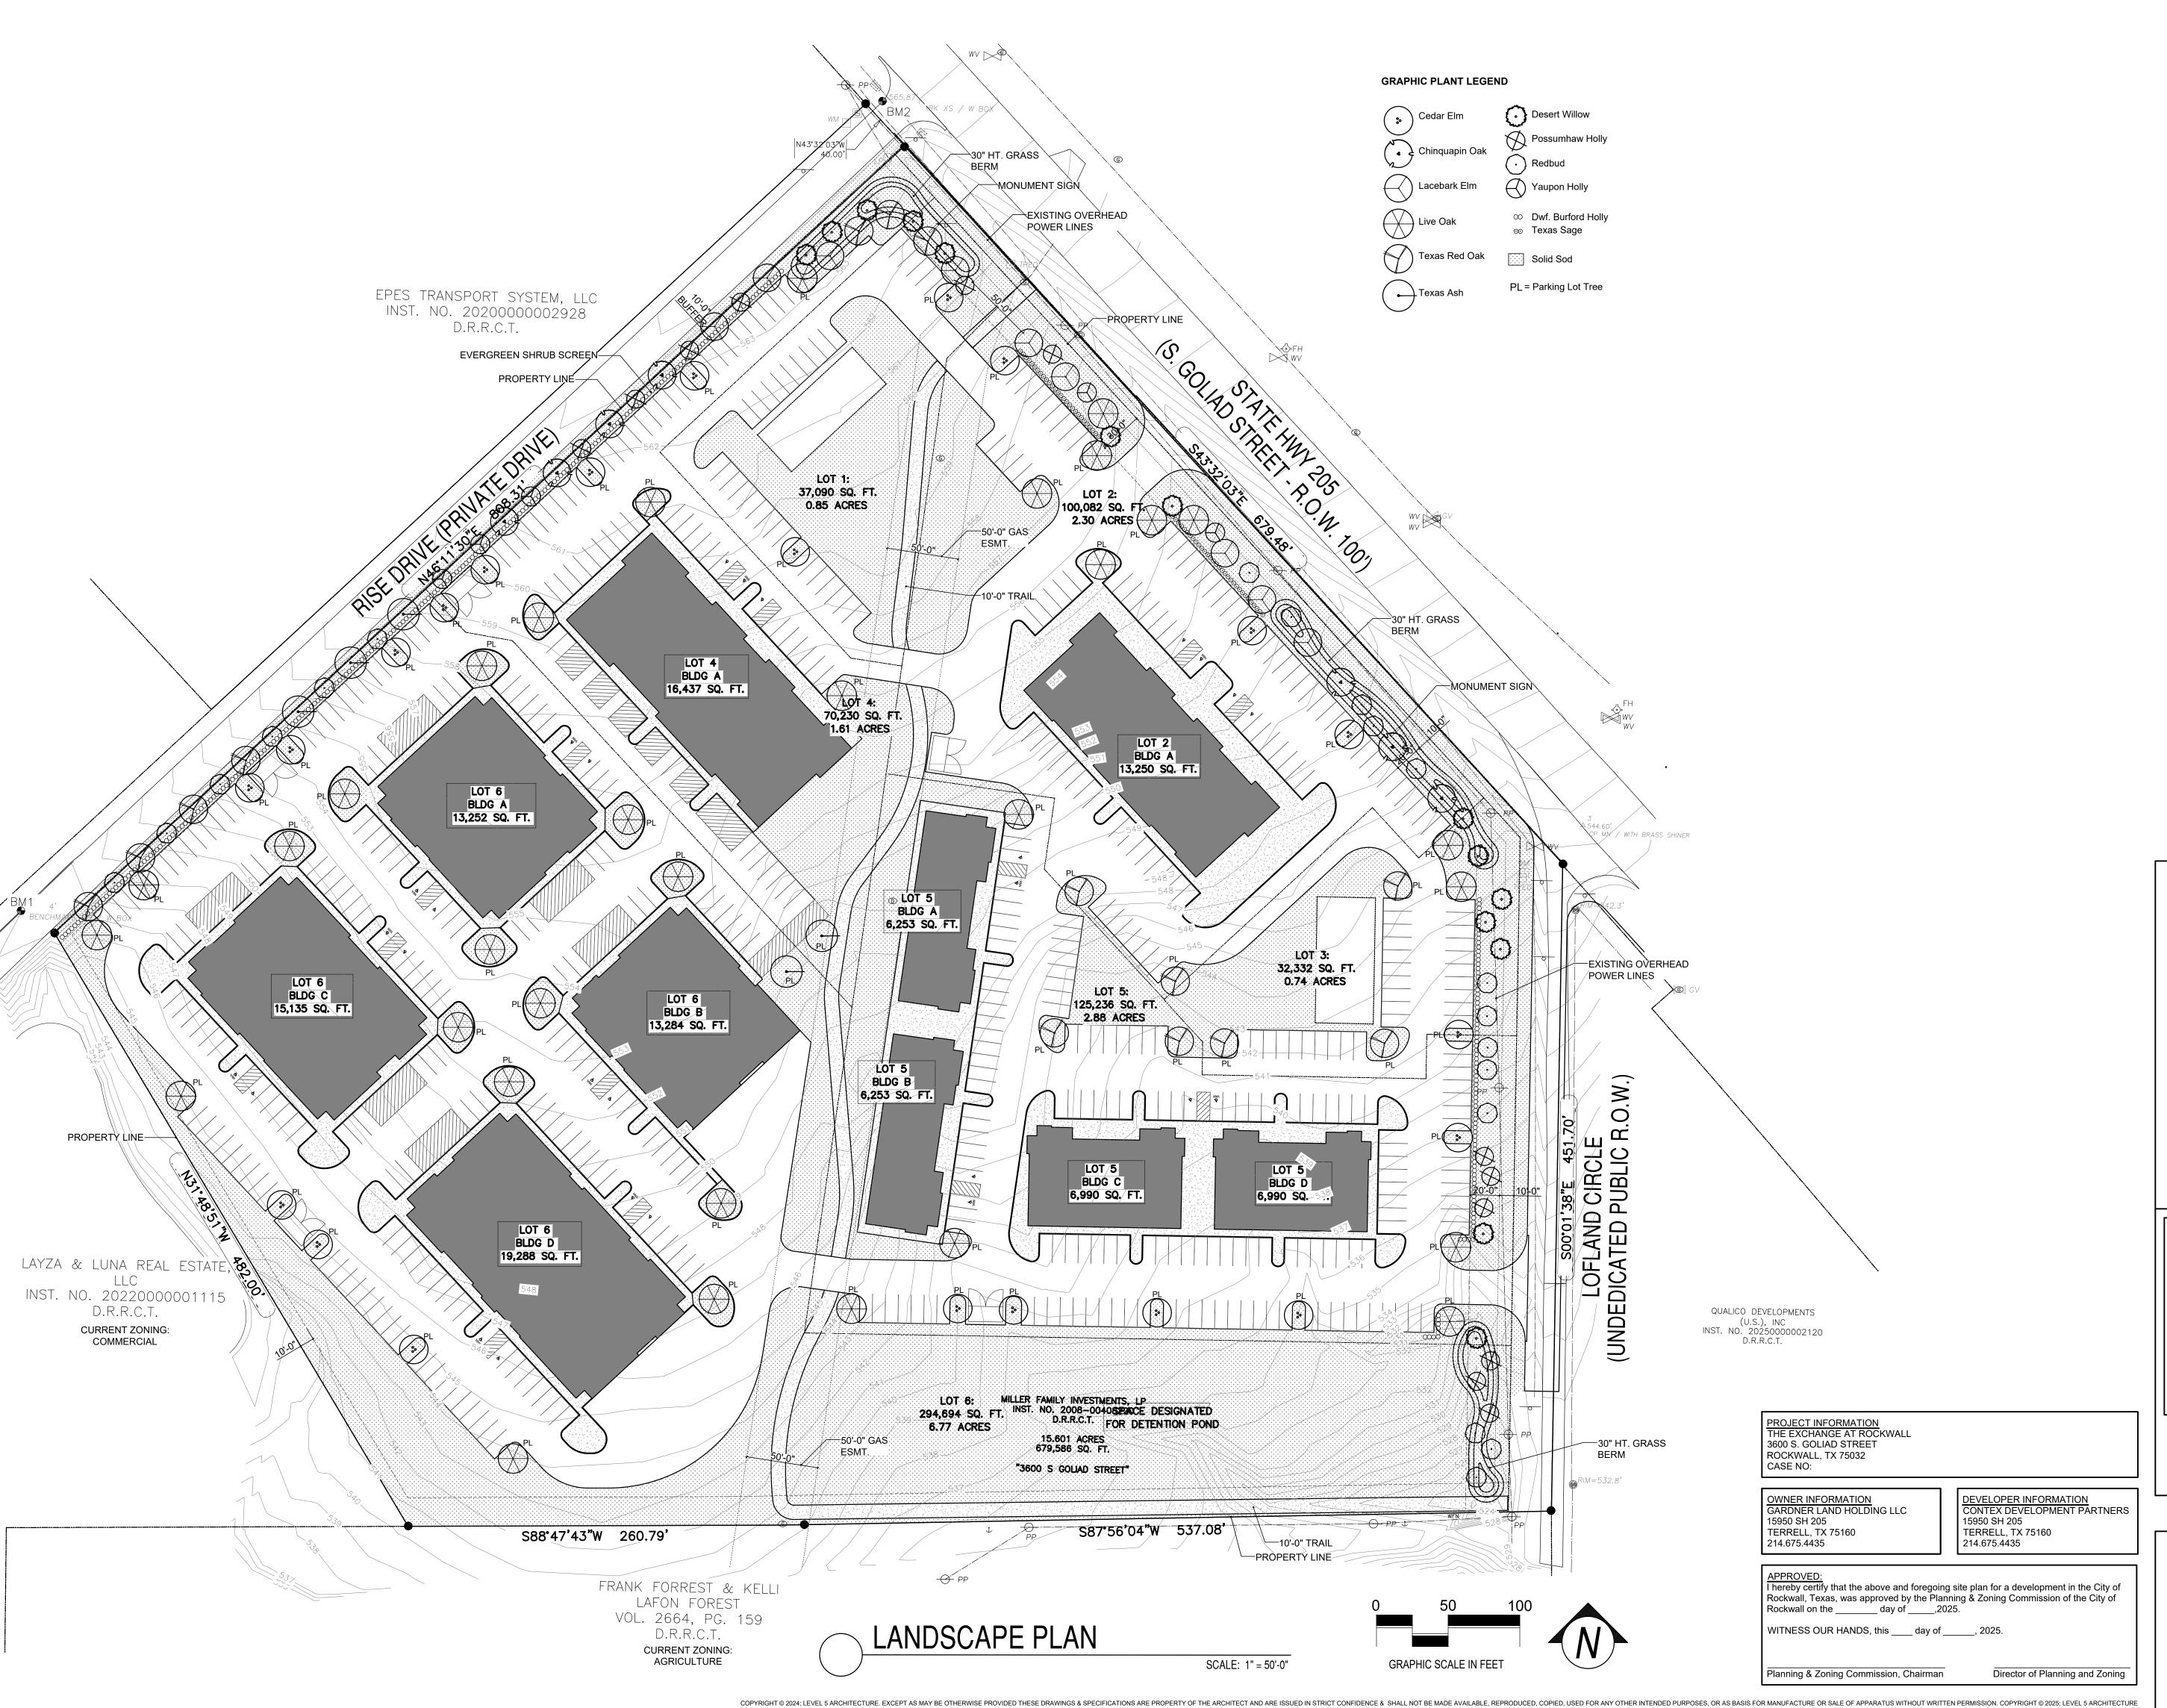



MEEKS DESIGN GROUP, INC. 1755 N. COLLINS BLVD., SUITE 300 RICHARDSON, TX 75080 PH (972) 690-7474 F (972) 690-7878






Level 5 Architecture


Mansfield, TX | Springdale, AR
level5architecture.com

Teveloarchitecture.com

THESE DOCUMENTS ARE FOR REVIEW ONLY AND ARE NOT INTENDED FOR BIDDING, PERMITTING OR CONSTRUCTION PURPOSES

	ANT LEGEND	10011101111111	101141	0.75	DE114 DV0
SYN	BOTANICAL NAME	COMMON NAME	QUAN	SIZE	REMARKS
	SHADE TREES				
CE	Ulmus crassifolia	Cedar Elm	21	4" Cal.	12'-14' Ht.
co	Quercus muehlenbergii	Chinquapin Oak	7	4" Cal.	12'-14' Ht.
LE	Ulmus Parvifolia	Lacebark Elm	9	4" Cal.	12'-14' Ht.
LO	Quercus virginiana	Live Oak	32	4" Cal.	12-14' Ht.
RO	Quercus buckleyi	Texas Red Oak	14	4" Cal.	12-14' Ht.
TA	Fraxenis texensis	Texas Ash	5	4" Cal.	12-14' Ht.
,					
DW	ACCENT TREES	Desert Willow	14	6' to 8' Ht.	Multi tourile 2 5 aanaa 41 aal
	Chilopsis linearis	Desert willow	14	0 ю п.	Multi trunk, 3 - 5 canes, 1" cal., cane min.
PH	llex decidua	Possumhaw Holly	12	6' to 8' Ht.	Multi trunk, 3 - 5 canes, 1" cal., cane min.
RB	Cercis canadensis	Eastern Redbud	19	6' to 8' Ht.	Single trunk
ΥH	llex vomitoria	Yaupon Holly	5	6' to 8' Ht.	Multi trunk, 3 - 5 canes, 1" cal., cane min.
					I
	LARGE SHRUBS				
DB	llex cornuta 'Burfordii'	Dwarf Burford Holly	321	3 Gal.	24" min. ht, 18" min. spread, Plant 36" O.C.
	Leucophyllum frutescens	Texas Sage	60	3 Gal.	24" min. ht, 18" min. spread, Plant 36" O.C.
TS		I			30 0.0.
	GROUNDCOVERS				
SS	GROUNDCOVERS Cynodon spp.	Common Bermuda	216,9	015 S.F.	Solid sod and/or hydromulch

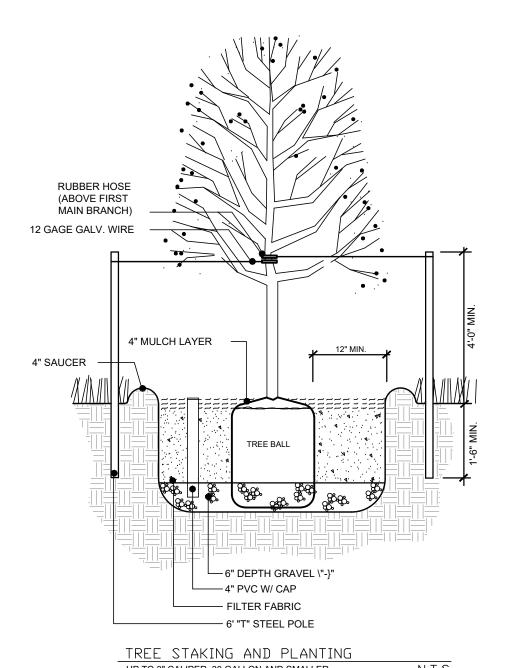

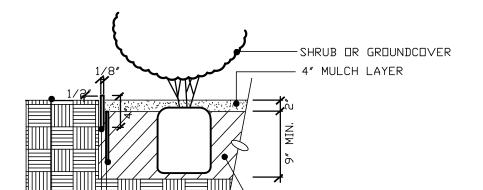

— STEEL STAKE /
— STEEL EDGE (SEE PLANS FOR LOCATION)
— GRASS

BED-PREP W/STEEL EDGE

GENERAL MAINTENANCE:

REQUIRED PLANTS MUST BE MAINTAINED IN A HEALTHY CONDITION AT ALL TIMES. THE PROPERTY OWNER IS RESPONSIBLE FOR REGULAR WEEDING, MOWING OF GRASS, IRRIGATING, FERTILIZING, PRUNING, AND OTHER MAINTENANCE OF ALL PLANTINGS AS NEEDED. ANY PLANT THAT DIES MUST BE REPLACED WITH ANOTHER LIVING PLANT THAT IS COMPATIBLE WITH THE APPROVED LANDSCAPE PLAN WITHIN (90) NINETY DAYS AFTER NOTIFICATION FROM THE CITY. THE BUILDING OFFICIAL MAY EXTEND THE TIME PERIOD UP TO AN ADDITIONAL (90) DAYS DUE TO WEATHER CONSIDERATIONS. IF THE PLANTS HAVE NOT BEEN REPLACED AFTER APPROPRIATE NOTIFICATION AND/OR EXTENSION, THE PROPERTY OWNER SHALL BE IN VIOLATION OF THIS ORDINANCE.

ANY DAMAGE TO UTILITY LINES RESULTING FROM THE NEGLIGENCE OF THE PROPERTY OWNER OR HIS AGENTS OR EMPLOYEES IN THE INSTALLATION AND MAINTENANCE OF REQUIRED LANDSCAPING IN A UTILITY EASEMENT IS THE RESPONSIBILITY OF THE PROPERTY OWNER. IF A PUBLIC UTILITY DISTURBS PLANTS WITHIN AN EASEMENT, IT SHALL MAKE EVERY REASONABLE EFFORT TO PRESERVE THE PLANTS AND RETURN THEM TO THEIR PRIOR LOCATIONS AFTER THE UTILITY WORK. IF NONETHELESS, SOME PLANTS DIE, IT IS THE OBLIGATION OF THE PROPERTY OWNER TO REPLACE THEM.

LANDSCAPE PLAN NOTES:

- All turf areas are to be hydromulched with common bermuda grass or solid sod.
 Hydromulch may not be applied during Stage 3 drought conditions.
 Annual color plantings are to be determined at the time of planting.
- 3. All lawn and landscape areas are to be seperated by Ryerson Steel Edging or
- 4. All trees and planting beds are to be laid out in the field by the landscape contractor for review by the owner's representative prior to excavation or preparation of planting areas. Contractor assumes full responsibility for failure to obtain owner's review of the layout including modifications required.
- 5. Landscape contractor is responsible for location all underground utilities and structures wether or not shown on the plans. And shall be responsible for damage to said utilities or structures caused by his forces.

 Ref. Civil plans for proposed utility line locations.
- 6. Planting area preparation to include minimum 1.5" to 3" approved organic matter (Back to earth or living earth) tilled into the top 8" of planting area soil unless otherwise specified. Remove all rocks, clods and debris. Leave planting areas smooth and assure positive drainage away from building as shown.

PLANTING NOTES

- 1. ALL PLANT MATERIAL LOCATIONS SHALL BE STAKED IN THE FIELD BY THE CONTRACTOR AND APPROVED BY THE OWNER/LANDSCAPE ARCHITECT PRIOR TO INSTALLATION.
- 2. FINE GRADING SHALL BE PERFORMED IN ALL AREAS TO BE SEEDED/ SODDED. FINE GRADING SHALL INCLUDE THE REMOVAL OF DEBRIS, ROCKS, ETC. FROM THE SITES AND INSURE POSITIVE DRAINAGE IN ALL AREAS SEEDED/SODDED.
- 3. THE CONTRACTOR SHALL VERIFY ALL BUILDING SETBACK LINES, EASEMENT LINES, AND VISIBILITY LINES IN THE FIELD PRIOR TO CONSTRUCTION.
- 4. THE CONTRACTOR SHALL VERIFY LOCATIONS OF ALL UTILITIES, SHOWN ON THIS PLAN AND NOT SHOWN ON THESE PLANS, IN THE FIELD PRIOR TO COMMENCEMENT OF WORK.
- 5. PROVIDE POSITIVE DRAINAGE AWAY FROM ALL SITE FEATURES.
- 6. STEEL EDGING OR A NATURAL BEVELLED EDGE SHALL BE INSTALLED AT ALL LOCATIONS WHERE PLANT MATERIALS MEET TURF AREAS.

NOTE:

ALL REQUIRED LANDSCAPE AREAS SHALL BE PROVIDED WITH AN AUTOMATIC UNDERGROUND IRRIGATION SYSTEM WITH RAIN AND FREEZE SENSORS AND EVAPOTRANSPIRATION (ET) WEATHER BASED CONTROLLERS AND SAID IRRIGATION SYSTEM SHALL BE DESIGNED BY A QUALIFIED PROFESSIONAL AND INSTALLED BY A LICENSED IRRIGATOR.

NOTE:

ALL PLANT MATERIAL SHALL BE COVERED UNDER A ONE YEAR WARRANTY.
WARRANTY PERIOD BEGINS ON DATE OF FINAL ACCEPTANCE.

CITY LANDSCAPE REQUIREMENTS

TOTAL SITE AREA 659,111 S.F. (15.13 ACRES)

TOTAL SITE LANDSCAPE

REQUIRED: 20% OF TOTAL SITE = 131,822 S.F.

PROVIDED: 31% (208,600 S.F.)

LANDSCAPE BUFFERS

RISE DRIVE:

REQUIRED: MINIMUM 10 FOOT WIDE LANDSCAPE BUFFER.

PARKING LOT SCREENING - MINIMUM 30" HEIGHT BERM OR

SHRUBS OR COMBINATION OF BOTH

(1) CANOPY TREE & (1) ACCENT TREE PER 50 L.F. OF FRONTAGE. 800 L.F. / 50 = (16) CANOPY TREES AND (16) ACCENT TREES

PROVIDED: 10 FOOT WIDE LANDSCAPE BUFFER

EVERGREEN SHRUB SCREEN - MINIMUM 30" HT. (16) CANOPY TREES & (16) ACCENT TREES

(...)

S. GOLIAD STREET:

REQUIRED: MINIMUM 10 FOOT WIDE LANDSCAPE BUFFER.

PARKING LOT SCREENING - MINIMUM 30" HEIGHT BERM OR

SHRUBS OR COMBINATION OF BOTH.

(1) CANOPY TREE & (1) ACCENT TREE PER 50 L.F. OF FRONTAGE.

582 L.F. / 50 = (12) CANOPY TREES & (12) ACCENT TREES

PROVIDED: 30 FOOT WIDE LANDSCAPE BUFFER

EVERGREEN SHRUB SCREEN AND BUILT-UP BERM

- MINIMUM 30" HT.

(12) CANOPY TREES & (12) ACCENT TREES

LOFLAND CIRCLE:

REQUIRED: MINIMUM 10 FOOT WIDE LANDSCAPE BUFFER.

PARKING LOT SCREENING - MINIMUM 30" HEIGHT BERM OR

SHRUBS OR COMBINATION OF BOTH.

(1) CANOPY TREE & (1) ACCENT TREE PER 50 L.F. OF FRONTAGE.

436 L.F. / 50 = (9) CANOPY TREES & (9) ACCENT TREES

PROVIDED: 30 FOOT WIDE LANDSCAPE BUFFER

EVERGREEN SHRUB SCREEN - MINIMUM 30" HT.

(19) ACCENT TREES (DUE TO PRESENCE OF OVERHEAD POWER LINES)

COPYRIGHT © 2024; LEVEL 5 ARCHITECTURE. EXCEPT AS MAY BE OTHERWISE PROVIDED THESE DRAWINGS & SPECIFICATIONS ARE PROPERTY OF THE ARCHITECTURE OR SALE OF APPARATUS WITHOUT WRITTEN PERMISSION. COPYRIGHT © 2025; LEVEL 5 ARCHITECTURE

PARKING LOT TREES

REQUIRED: 1 CANOPY TREE PER 10 PARKING SPACES.


NO PARKING SPACE MAY BE LOCATED MORE THAN

80 FEET FROM TRUNK OF A CANOPY TREE

579 PARKING SPACES / 10 = 58 TREES

PROVIDED: 60 CANOPY TREES

ALL PARKING SPACES WITHIN 80 FEET OF A PARKING LOT TREE

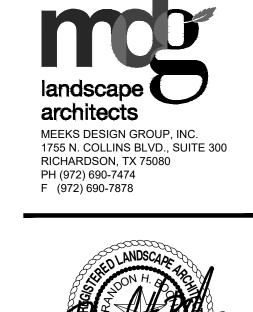



Level 5 Architecture

Mansfield, TX | Springdale, AR

level5architecture.com

THESE DOCUMENTS ARE

FOR REVIEW ONLY AND

ARE NOT INTENDED FOR

BIDDING. PERMITTING OR

CONSTRUCTION PURPOSES

OWNER INFORMATION GARDNER LAND HOLDING LLC 15950 SH 205 TERRELL, TX 75160 214.675.4435

WITNESS OUR HANDS, this ____ day of ____, 2025

Planning & Zoning Commission, Chairman

PROJECT INFORMATION
THE EXCHANGE AT ROCKWALL
3600 S. GOLIAD STREET

ROCKWALL, TX 75032


DEVELOPER INFORMATION CONTEX DEVELOPMENT PARTNERS 15950 SH 205 TERRELL, TX 75160 214.675.4435

Director of Planning and Zoning

APPROVED:
I hereby certify that the above and foregoing site plan for a development in the City of Rockwall, Texas, was approved by the Planning & Zoning Commission of the City of Rockwall on the _____ day of _____,2025.

ARCHITECT:
JUSTIN S. GILMORE
LEVEL 5 ARCHITECTURE

LANDSCAPE NOTES & CALCULATIONS

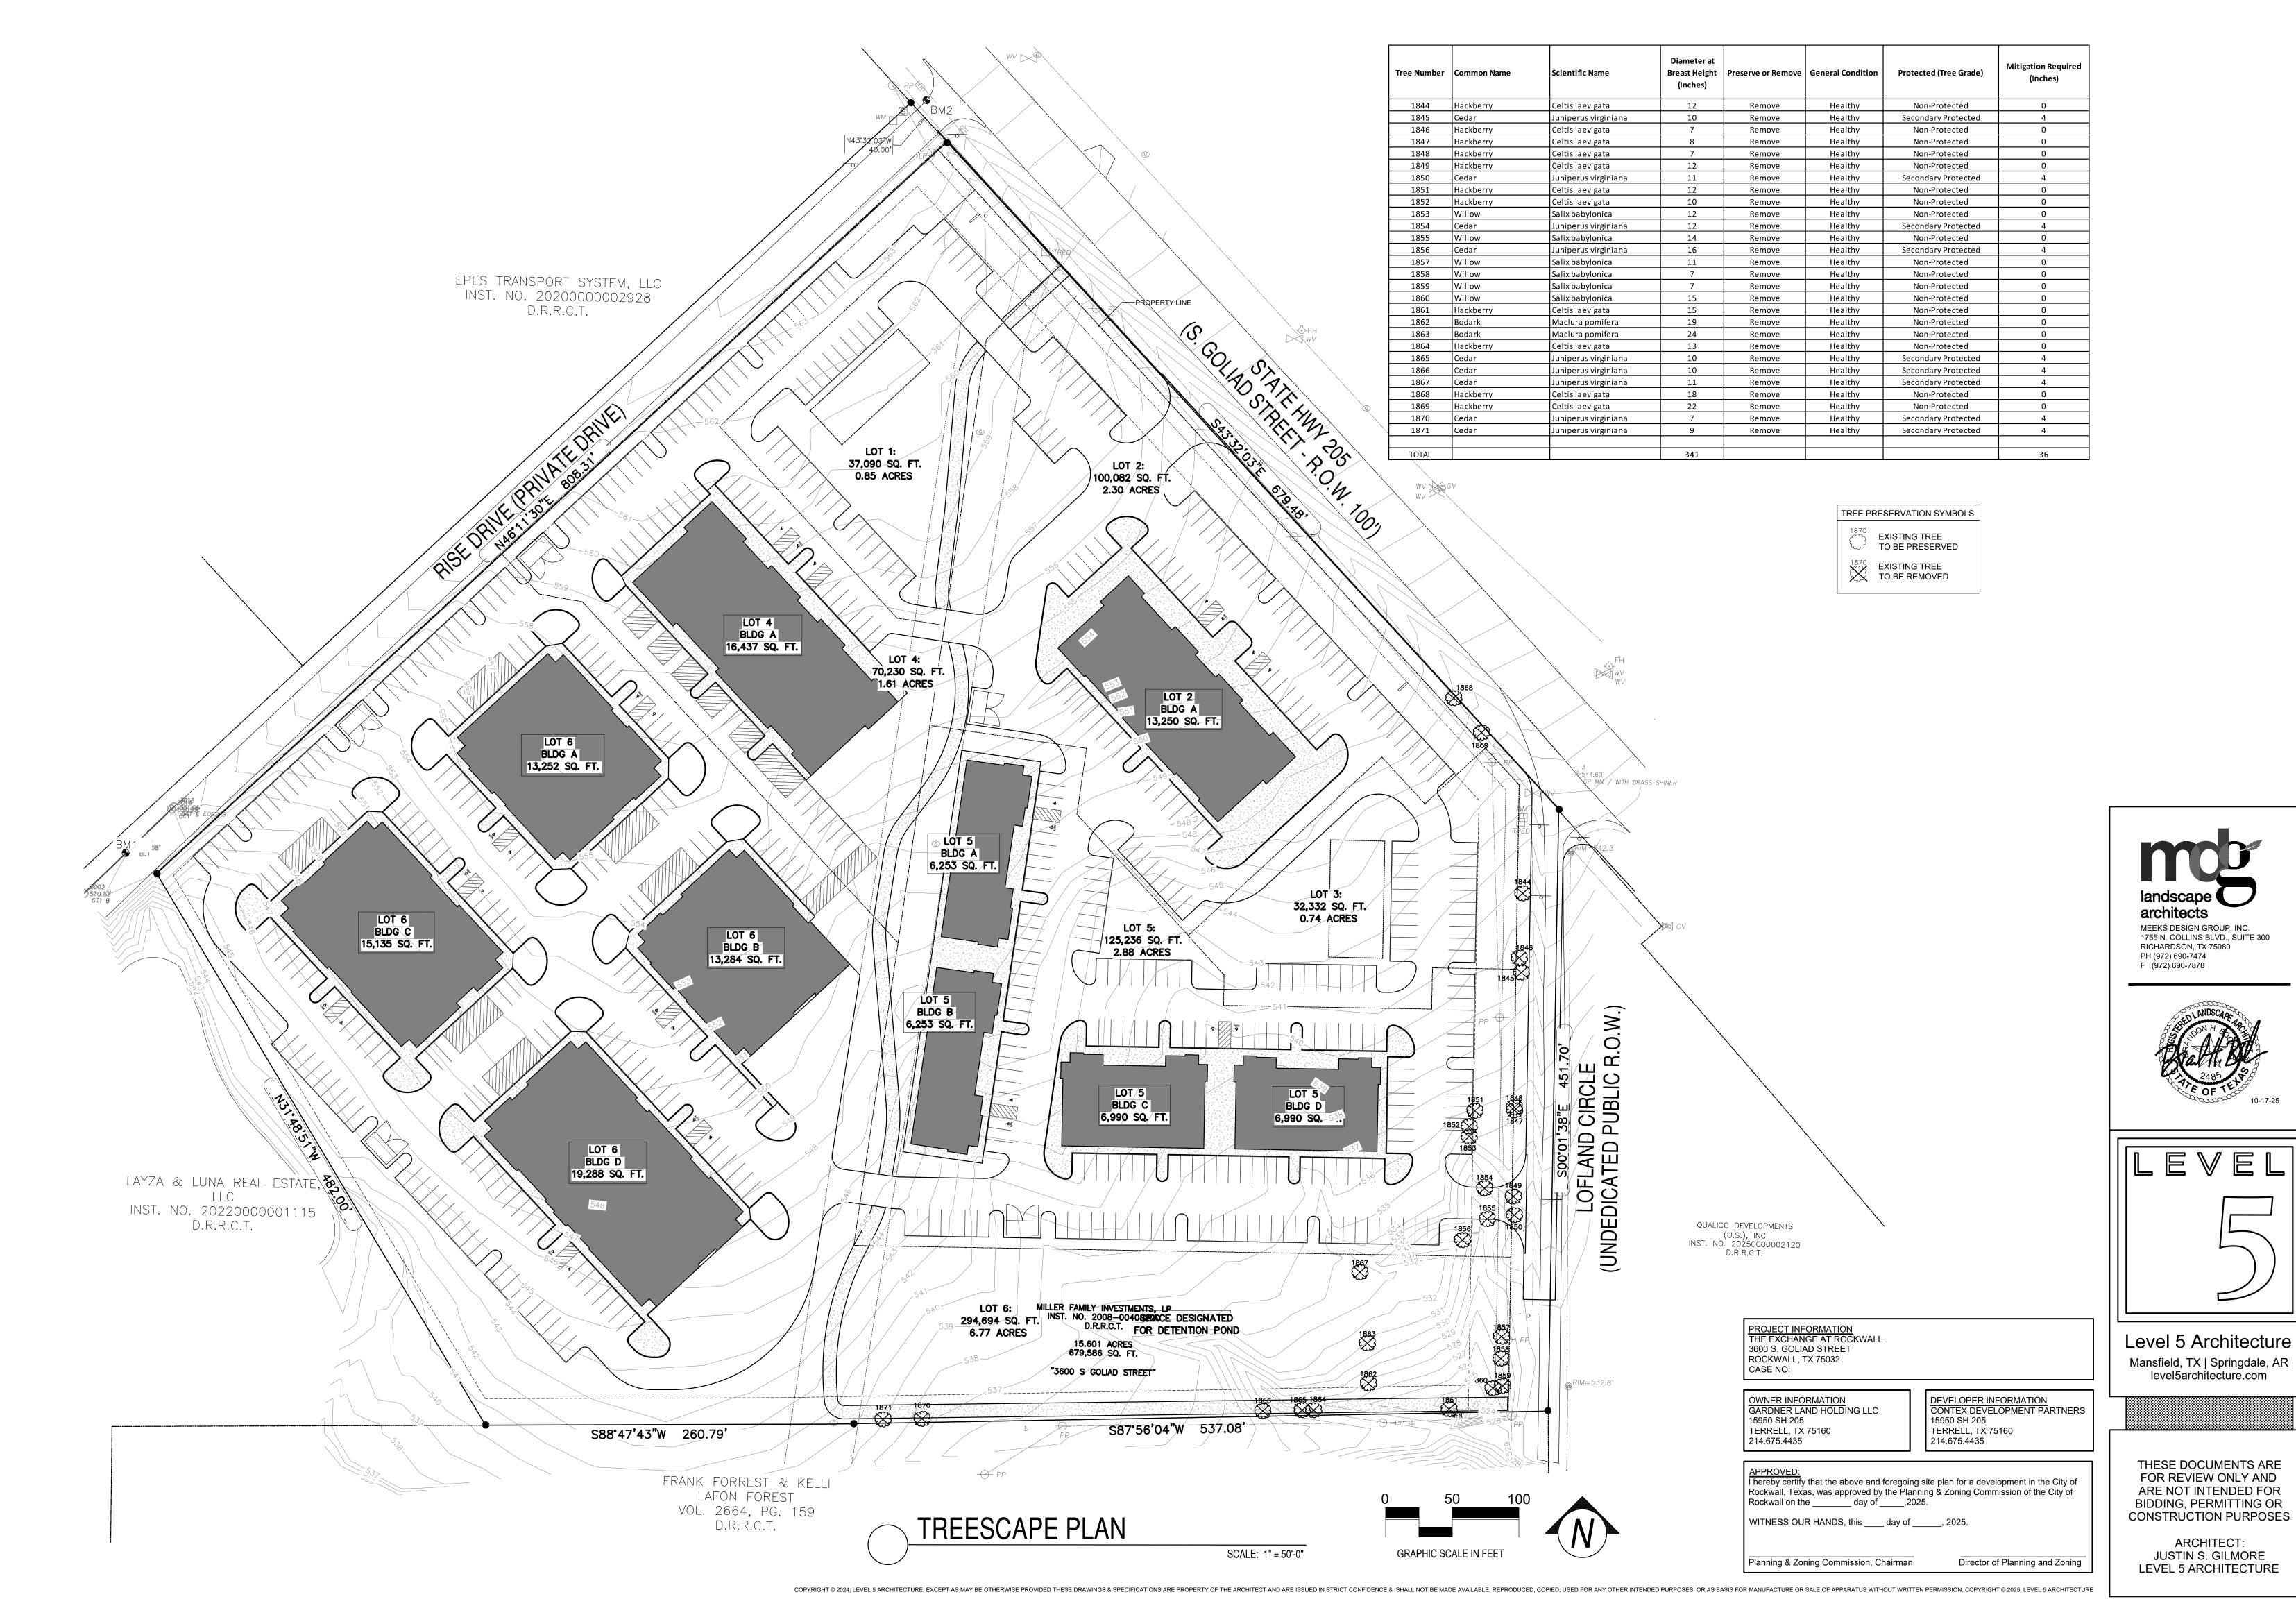




I. Surface reflectances: Vertical/Horizontal - 50/20. 2. Calculation values are at height indicated in summary table. 3. Mounting heights are designated on drawing with "MH." 4. Luminaire description does not necessarily reflect specification model number. Contact salesperson for verification. 5. Sylvania lamp data used unless otherwise noted. LED luminaires use integrated photometric lamp data provided by manufacturer. 6. Lighting power density is calculated based on estimated ballast/driver energy consumption. Engineer to verify. 7. For lumen output of scaled luminaires, multiply Total Lumen Output by User Defined Factor.

> **Architectural Lighting Alliance** 101 Turtle Creek Blvd. Dallas TX 75207 O 214-658-9000 | F 214-658-9002 www.alatx.com

PROJECT: ROCKWALL MIXED USE DEVELOPMENT

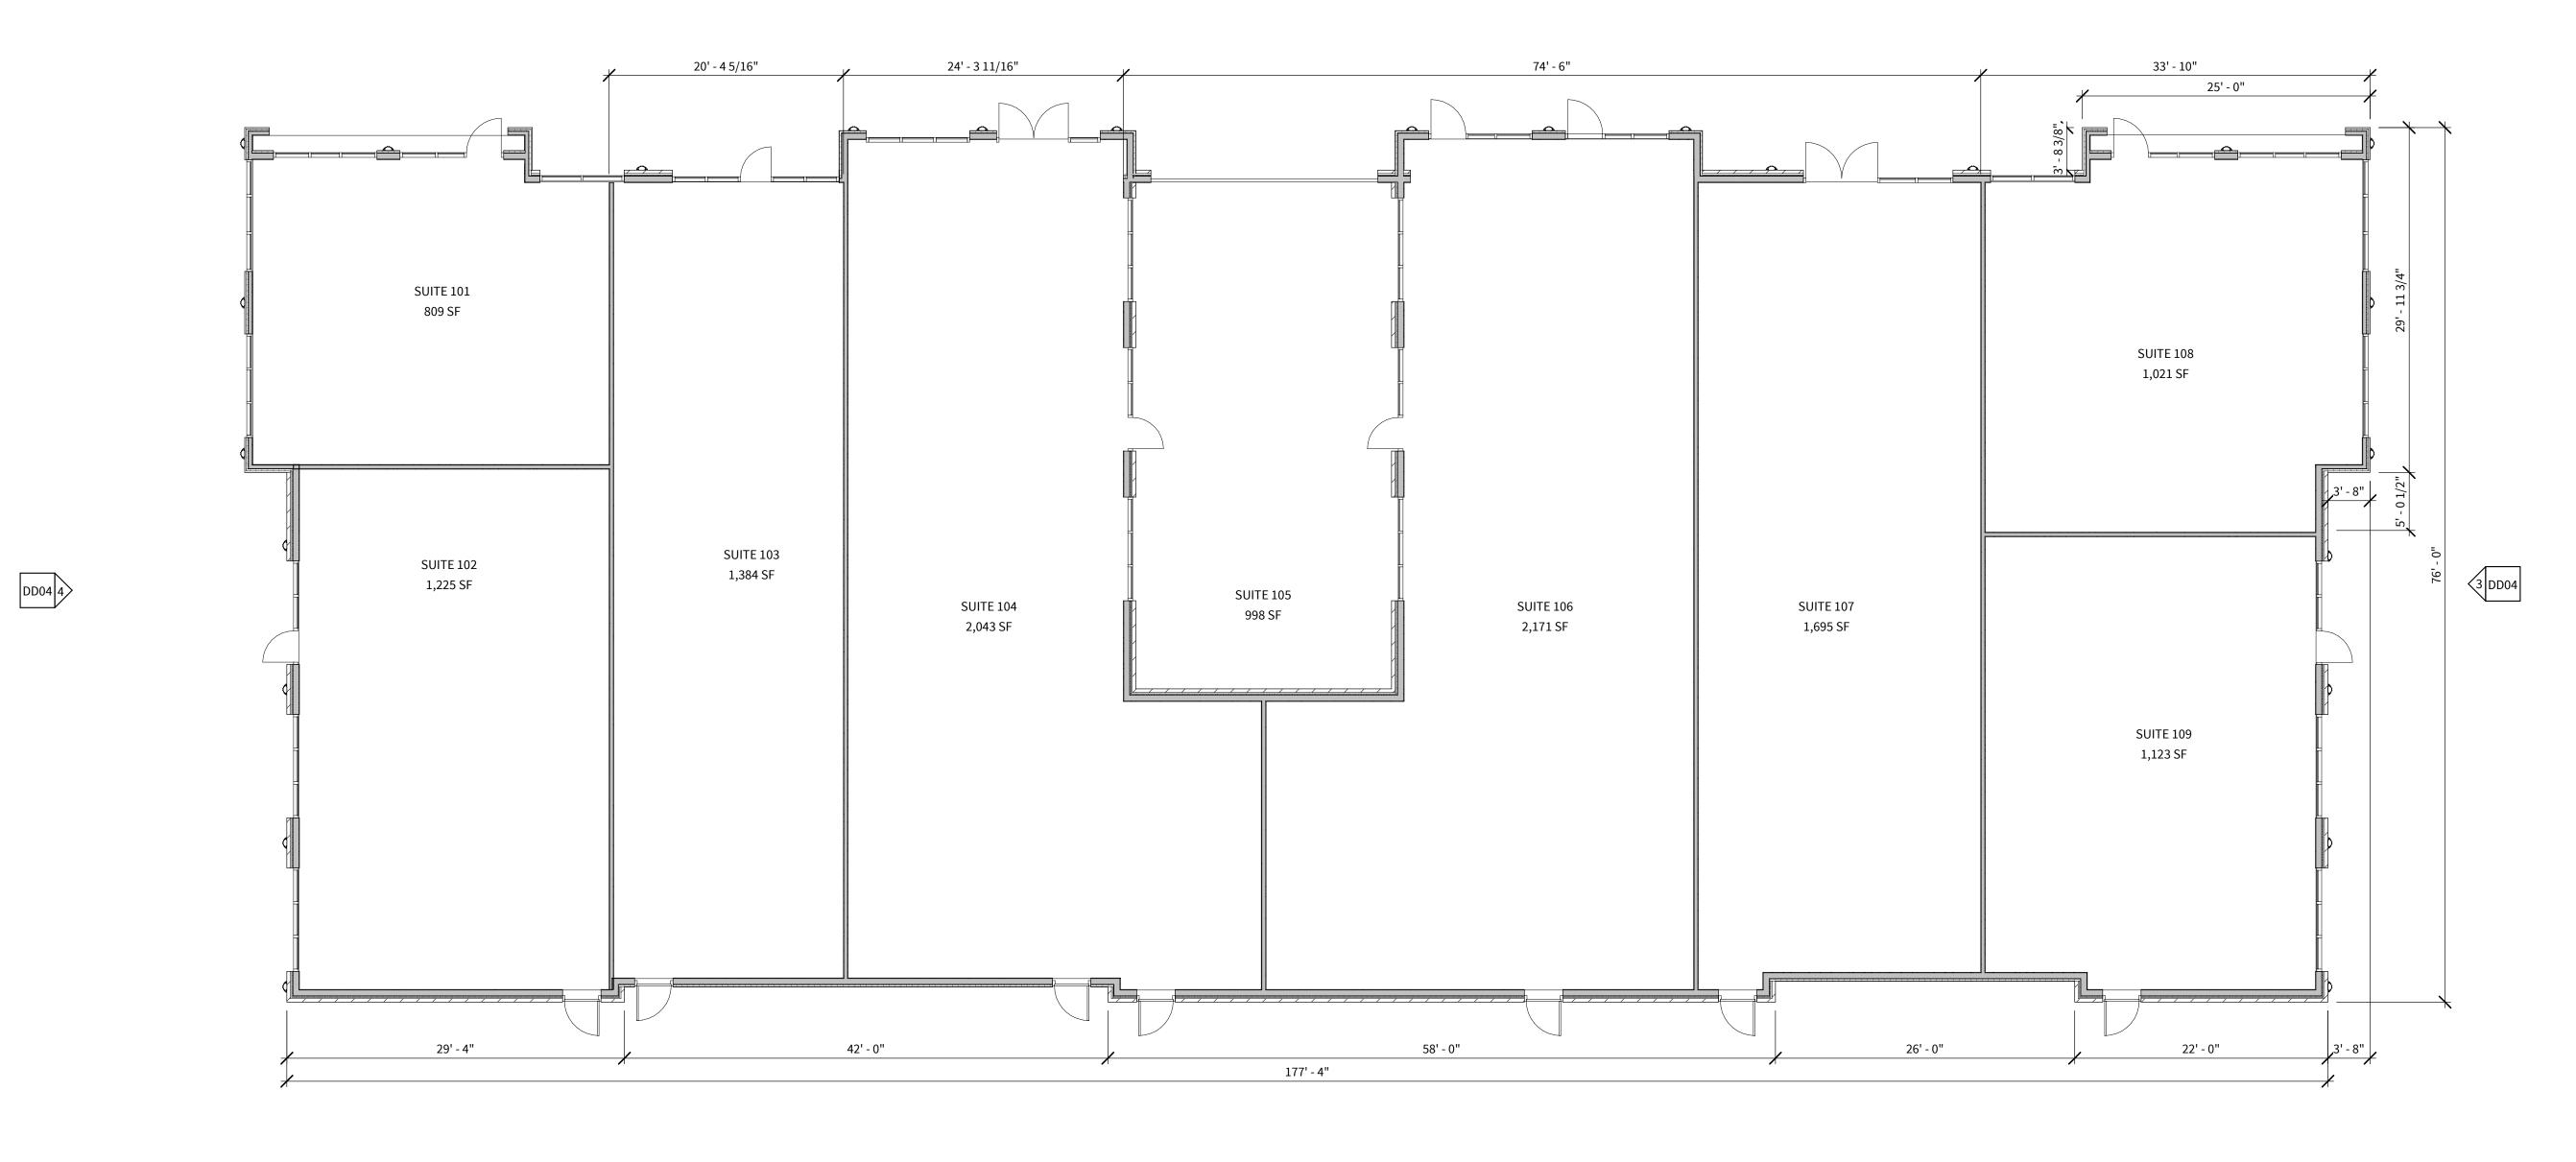

FLOOR PLAN - LOT 2 BUILDING A

SCALE: 1/8" = 1'-0"



LEVEL 5

Level 5 Architecture

Mansfield, TX | Springdale, AR
level5architecture.com

THESE DOCUMENTS ARE

FOR REVIEW ONLY AND

ARE NOT INTENDED FOR BIDDING, PERMITTING OR

CONSTRUCTION PURPOSES

OWNER INFORMATION
GARDNER LAND HOLDING LLC
15950 SH 205
TERRELL, TX 75160
214.675.4435

DEVELOPER INFORMATION
CONTEX DEVELOPMENT PARTNERS
15950 SH 205
TERRELL, TX 75160
214.675.4435


APPROVED:
I hereby certify that the above and foregoing site plan for a development in the City of Rockwall, Texas, was approved by the Planning & Zoning Commission of the City of Rockwall on the _____ day of _____,2025.

Director of Planning and Zoning

WITNESS OUR HANDS, this ____ day of _____, 2025.

Planning & Zoning Commission, Chairman

PROJECT INFORMATION
THE EXCHANGE AT ROCKWALL
3600 S. GOLIAD STREET
ROCKWALL, TX 75032
CASE NUMBER:

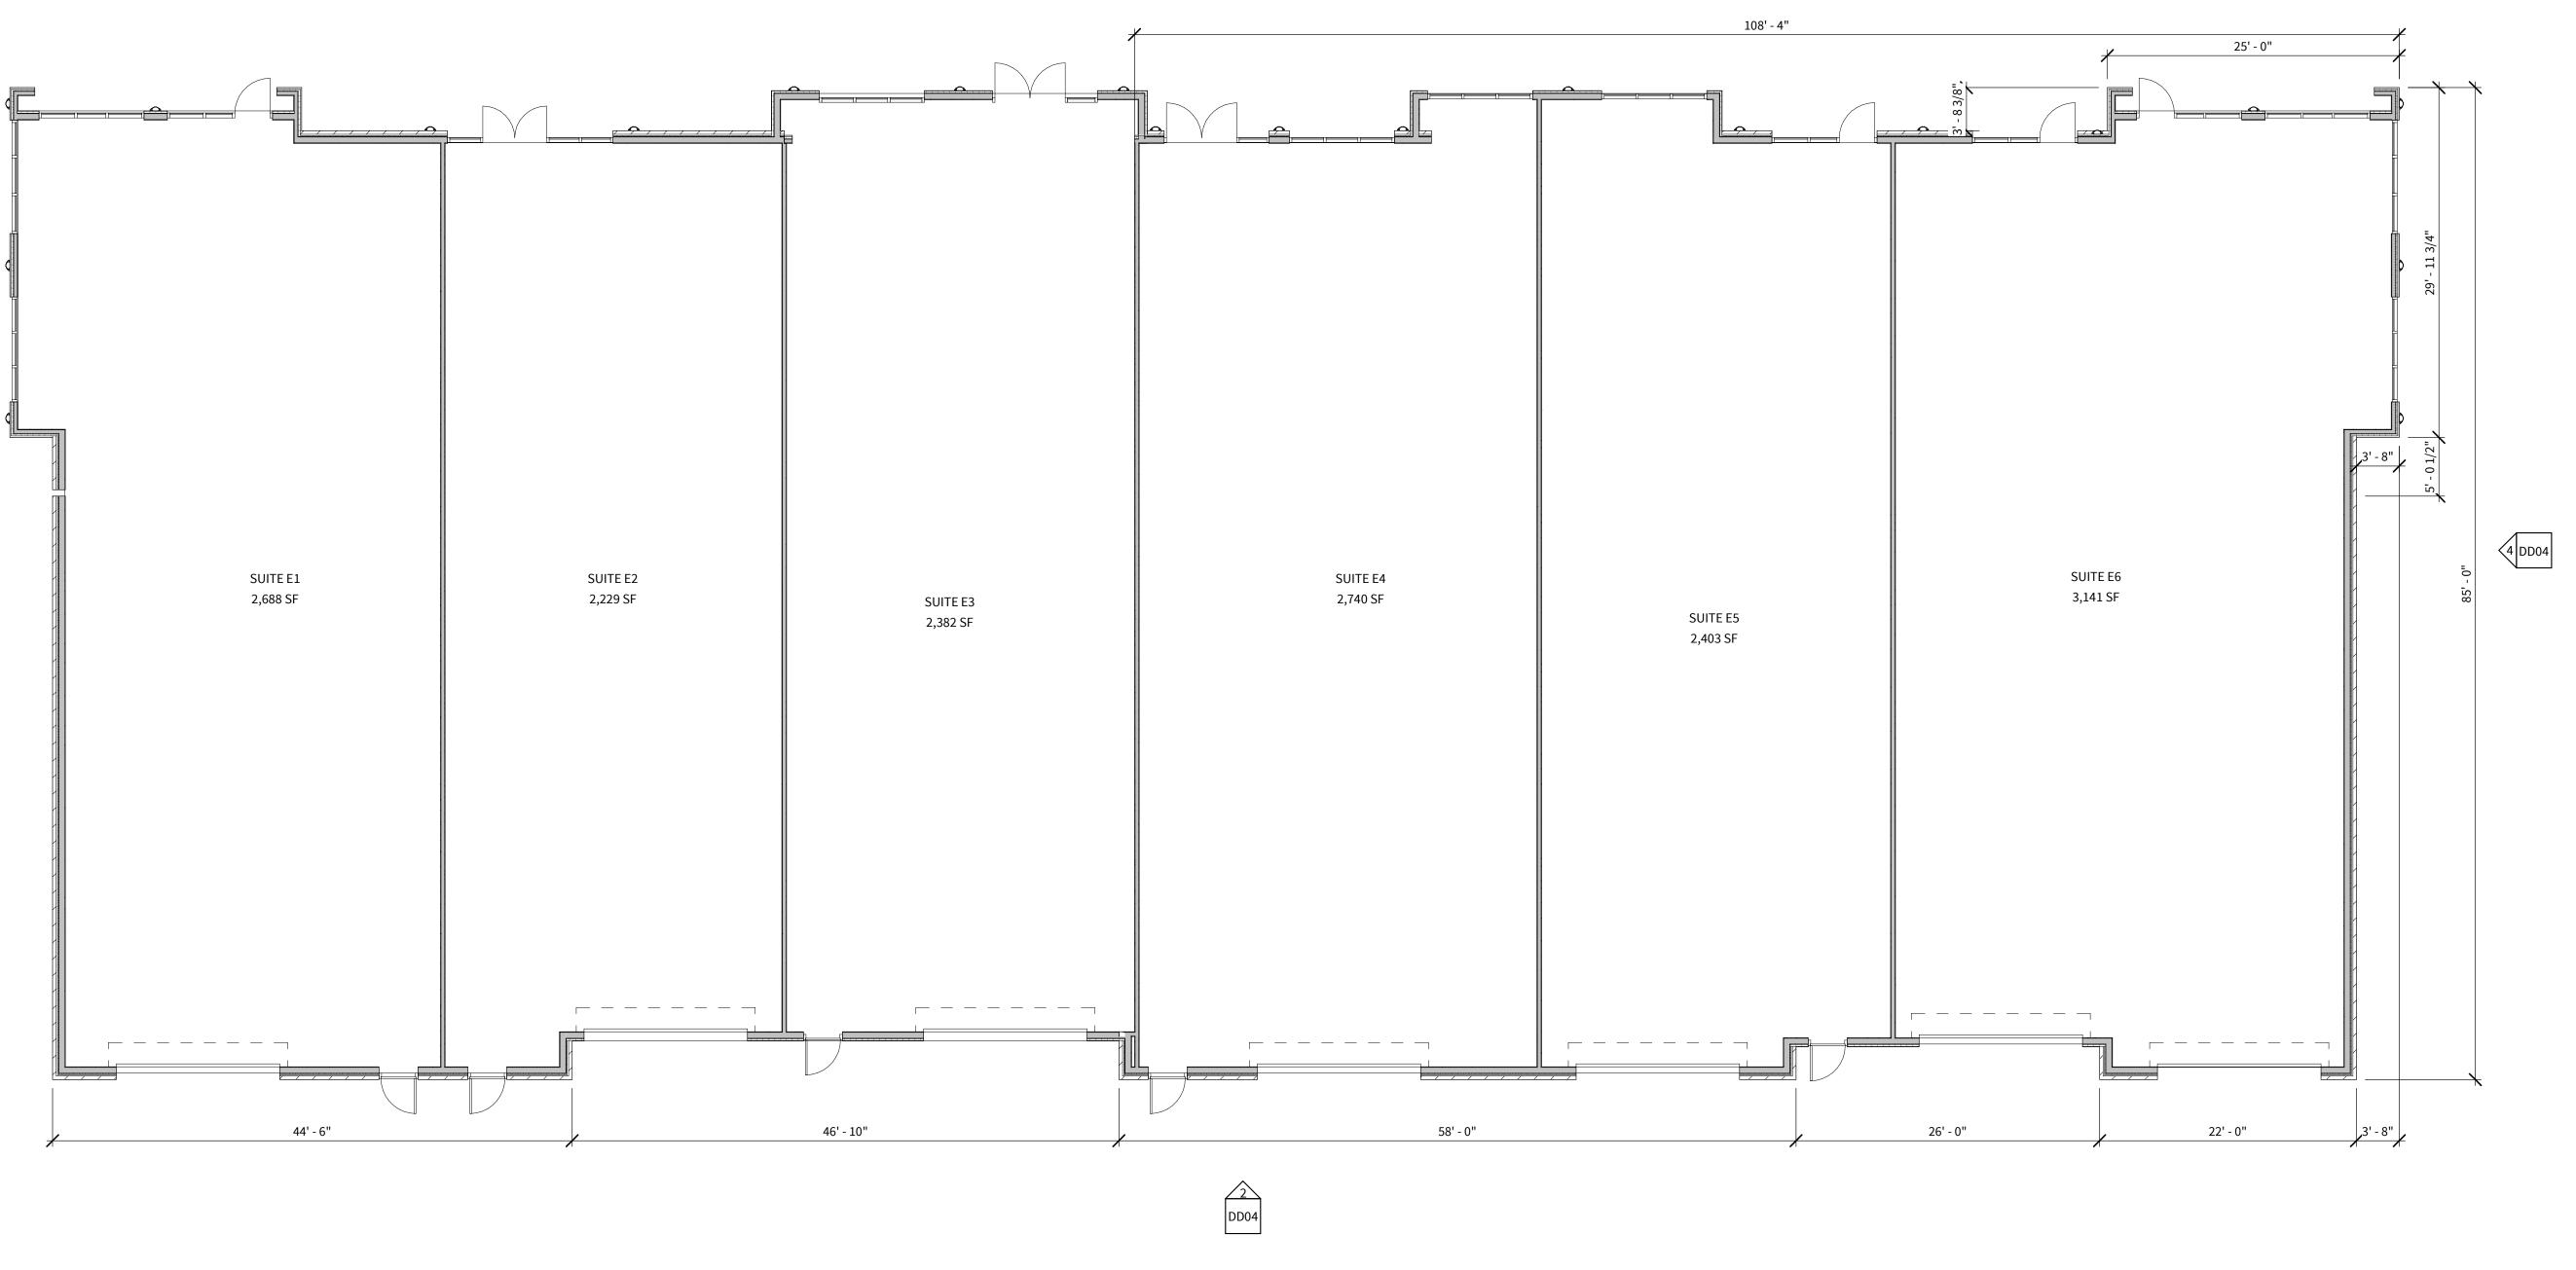

COPYRIGHT © 2024; LEVEL 5 ARCHITECTURE. EXCEPT AS MAY BE OTHERWISE PROVIDED THESE DRAWINGS & SPECIFICATIONS ARE PROPERTY OF THE ARCHITECT AND ARE ISSUED IN STRICT CONFIDENCE & SHALL NOT BE MADE AVAILABLE, REPRODUCED, COPIED, USED FOR ANY OTHER INTENDED PURPOSES, OR AS BASIS FOR MANUFACTURE OR SALE OF APPARATUS WITHOUT WRITTEN PERMISSION. COPYRIGHT © 2025; LEVEL 5 ARCHITECTURE

FLOOR PLAN - LOT 4 BUILDING A

SCALE: 1/8" = 1'-0"

PROJECT INFORMATION
THE EXCHANGE AT ROCKWALL
3600 S. GOLIAD STREET
ROCKWALL, TX 75032
CASE NUMBER:

OWNER INFORMATION
GARDNER LAND HOLDING LLC
15950 SH 205
TERRELL, TX 75160
214.675.4435

DEVELOPER INFORMATION
CONTEX DEVELOPMENT PARTNERS
15950 SH 205
TERRELL, TX 75160
214.675.4435

APPROVED:
I hereby certify that the above and foregoing site plan for a development in the City of Rockwall, Texas, was approved by the Planning & Zoning Commission of the City of Rockwall on the _____ day of _____,2025.

WITNESS OUR HANDS, this ____ day of _____, 2025.


Planning & Zoning Commission, Chairman Director of Planning and Zoning


LEVEL 5

Level 5 Architecture

Mansfield, TX | Springdale, AR
level5architecture.com

THESE DOCUMENTS ARE FOR REVIEW ONLY AND ARE NOT INTENDED FOR BIDDING, PERMITTING OR CONSTRUCTION PURPOSES

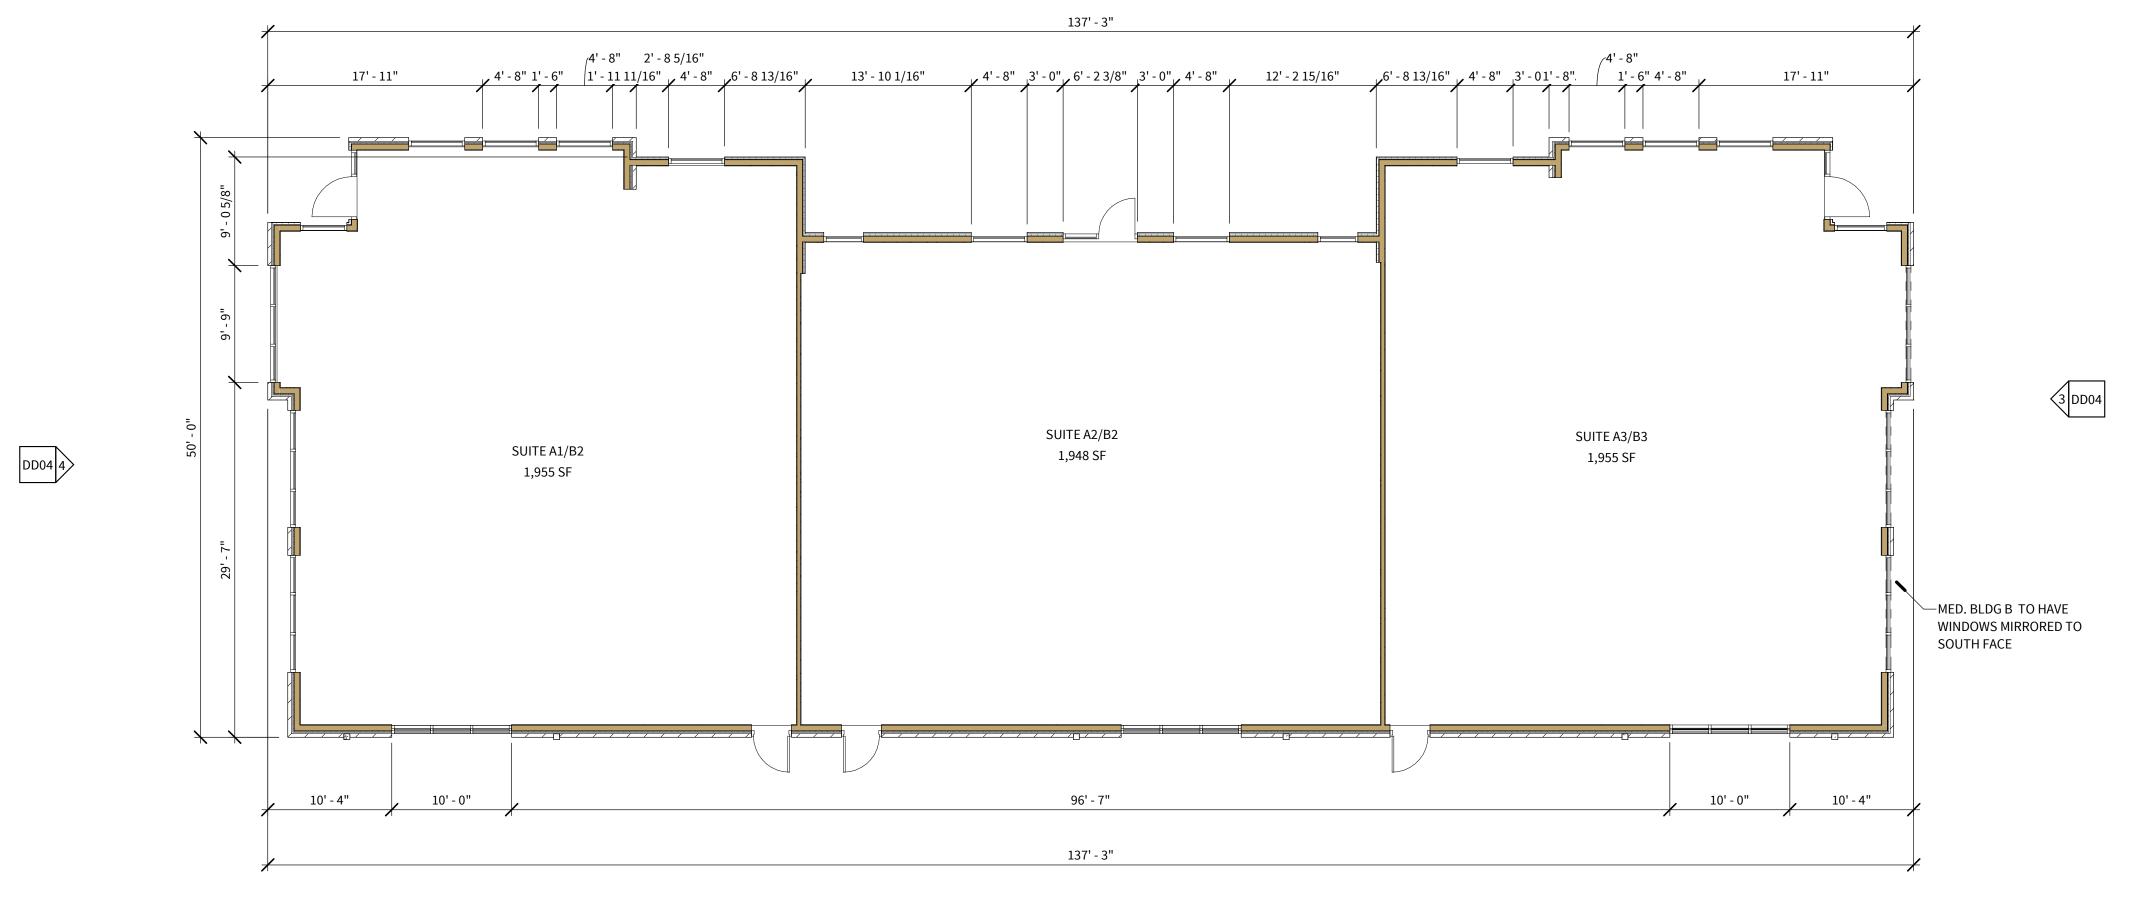

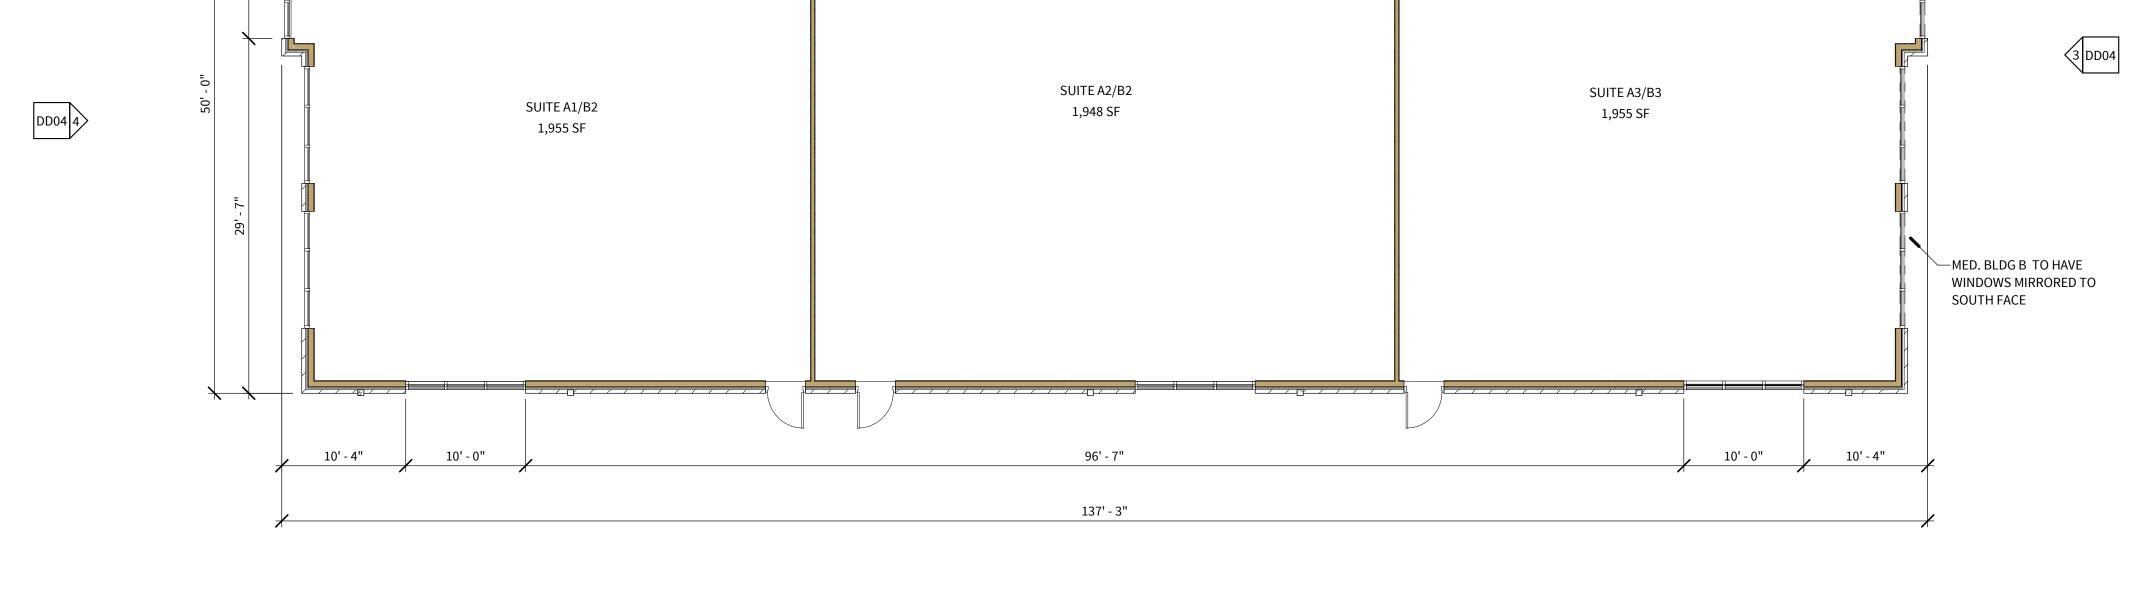



PROJECT INFORMATION
THE EXCHANGE AT ROCKWALL
3600 S. GOLIAD STREET
ROCKWALL, TX 75032
CASE NUMBER:

OWNER INFORMATION GARDNER LAND HOLDING LLC 15950 SH 205 TERRELL, TX 75160 214.675.4435

DEVELOPER INFORMATION CONTEX DEVELOPMENT PARTNERS 15950 SH 205 TERRELL, TX 75160 214.675.4435

APPROVED:
I hereby certify that the above and foregoing site plan for a development in the City of Rockwall, Texas, was approved by the Planning & Zoning Commission of the City of Rockwall on the _____ day of _____,2025.

WITNESS OUR HANDS, this ____ day of _____, 2025.

Planning & Zoning Commission, Chairman

ARCHITECT: JUSTIN S. GILMORE Director of Planning and Zoning LEVEL 5 ARCHITECTURE

Level 5 Architecture

Mansfield, TX | Springdale, AR level5architecture.com


THESE DOCUMENTS ARE

FOR REVIEW ONLY AND

ARE NOT INTENDED FOR BIDDING, PERMITTING OR

CONSTRUCTION PURPOSES

COPYRIGHT © 2024; LEVEL 5 ARCHITECTURE. EXCEPT AS MAY BE OTHERWISE PROVIDED THESE DRAWINGS & SPECIFICATIONS ARE PROPERTY OF THE ARCHITECT AND ARE ISSUED IN STRICT CONFIDENCE & SHALL NOT BE MADE AVAILABLE, REPRODUCED, COPIED, USED FOR ANY OTHER INTENDED PURPOSES, OR AS BASIS FOR MANUFACTURE OR SALE OF APPARATUS WITHOUT WRITTEN PERMISSION. COPYRIGHT © 2025; LEVEL 5 ARCHITECTURE

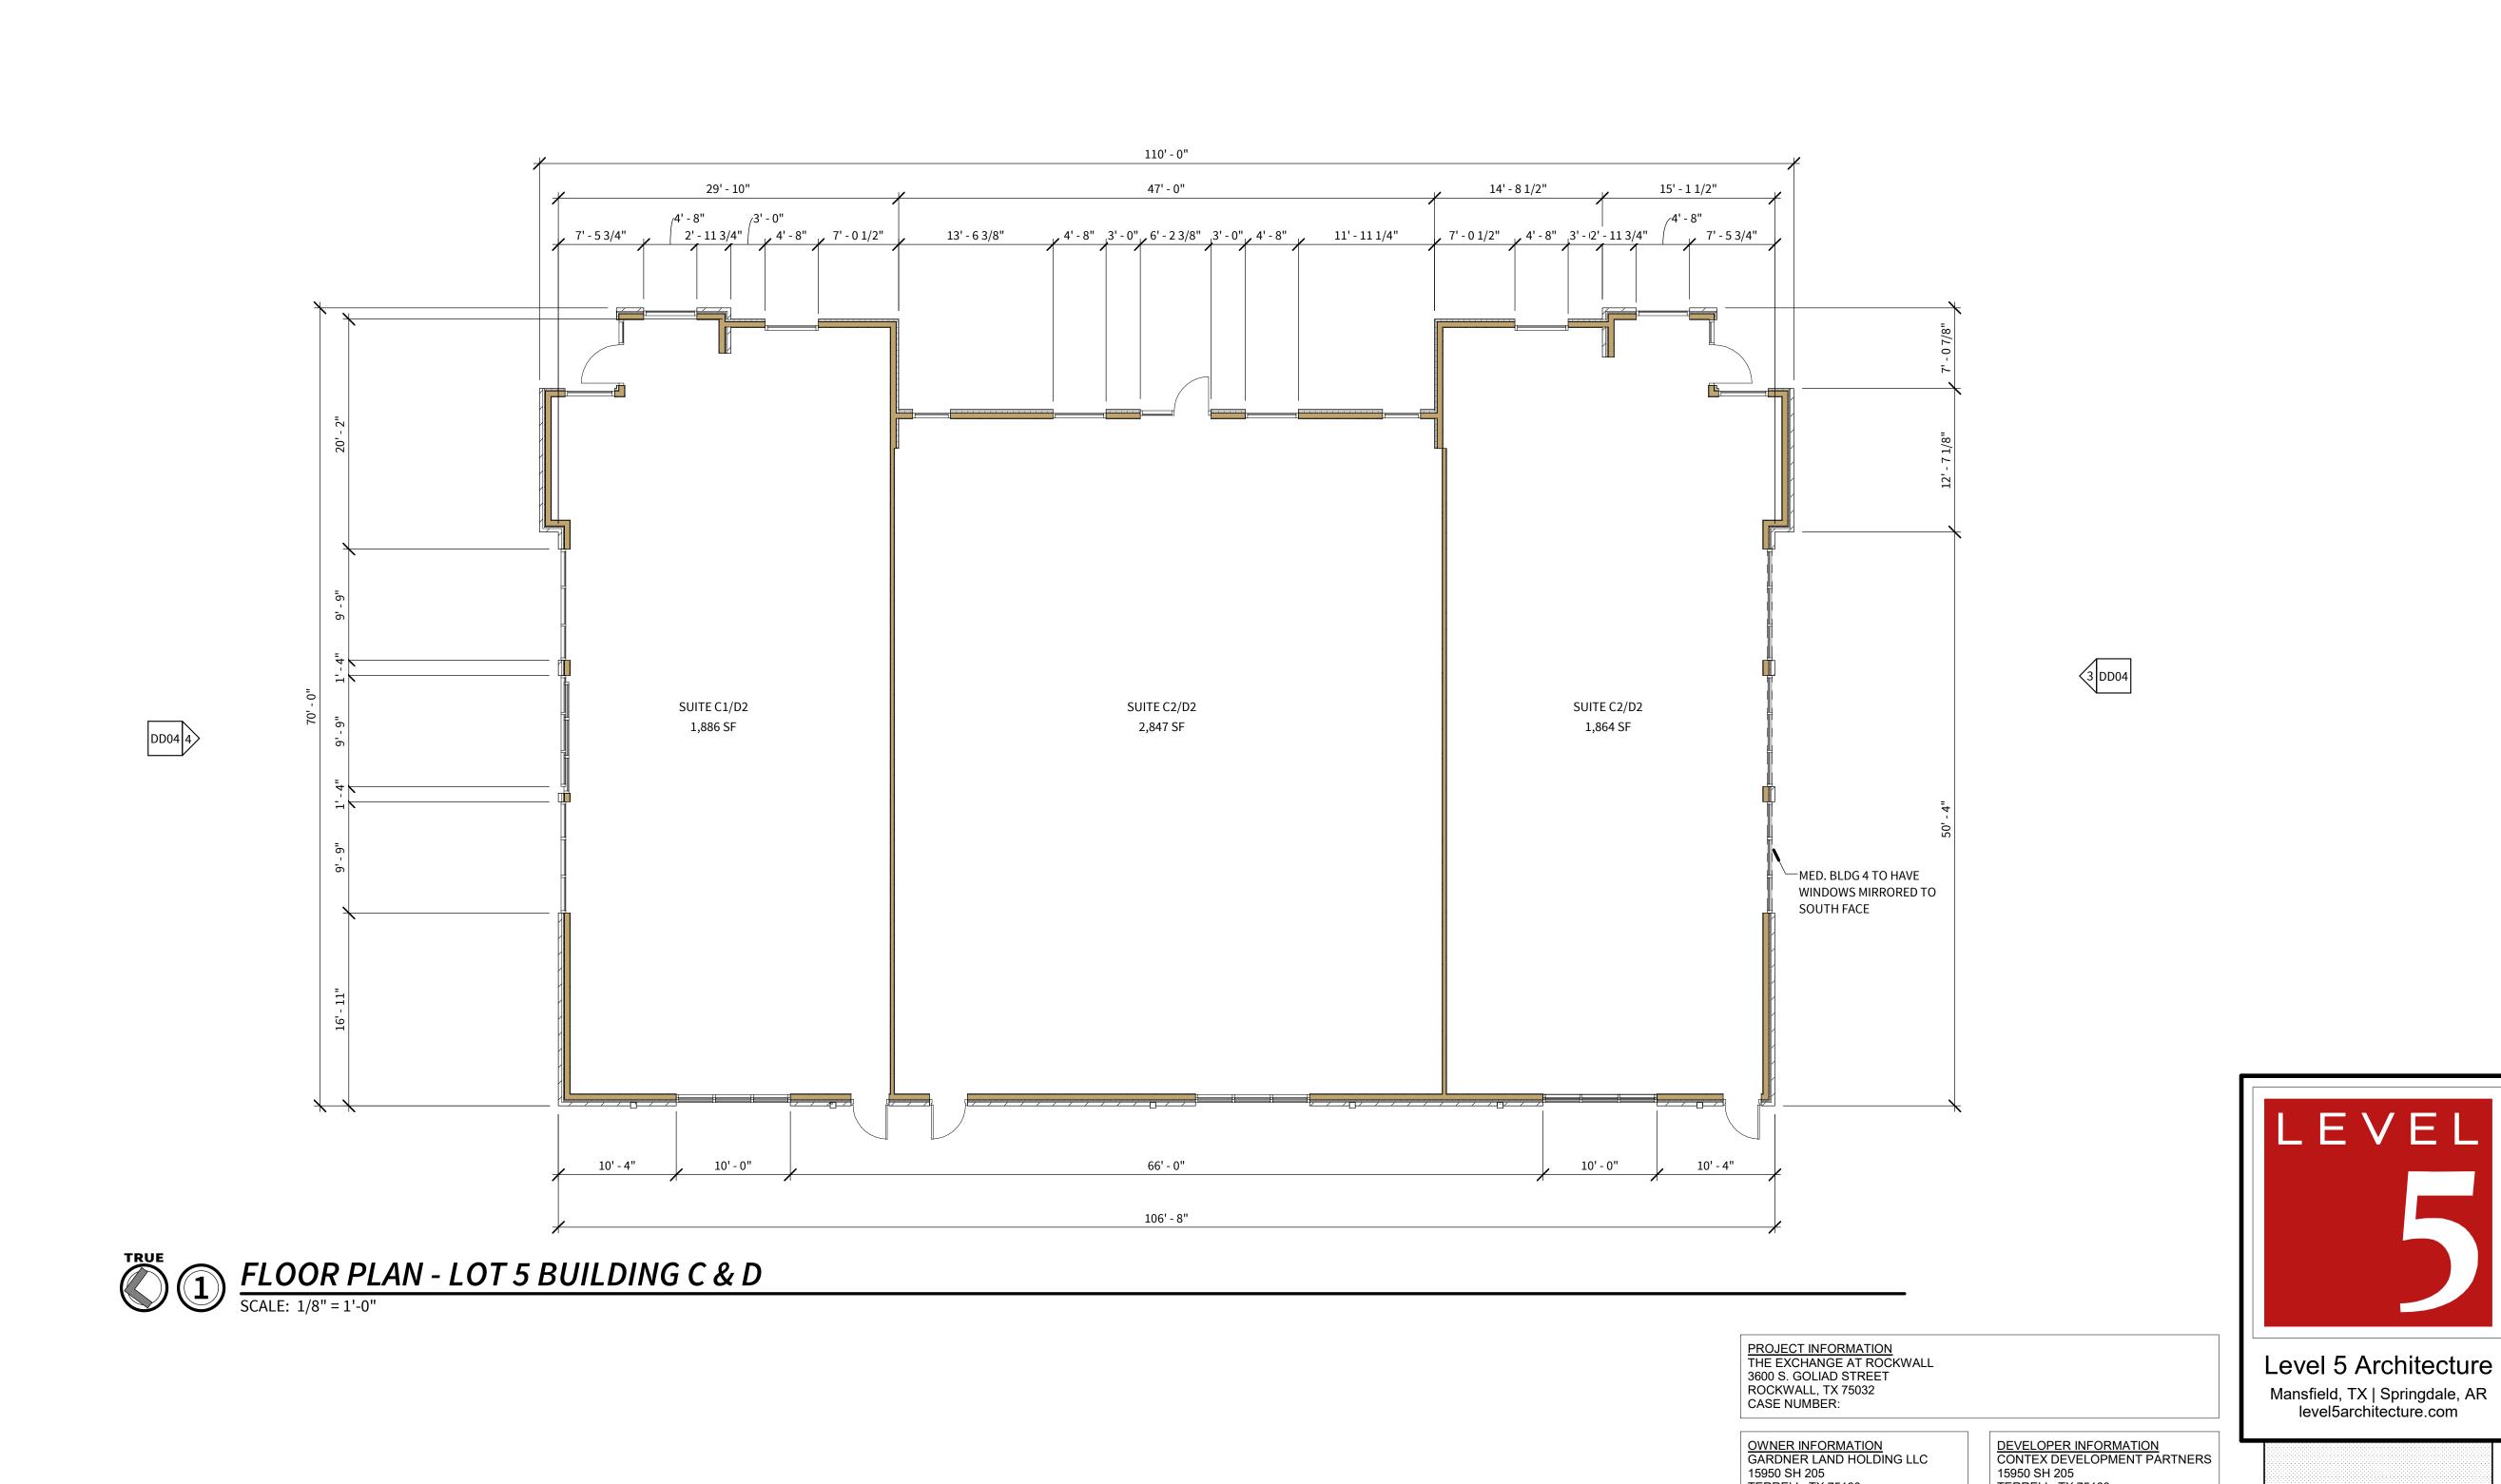

COPYRIGHT © 2024; LEVEL 5 ARCHITECTURE. EXCEPT AS MAY BE OTHERWISE PROVIDED THESE DRAWINGS & SPECIFICATIONS ARE PROPERTY OF THE ARCHITECT AND ARE ISSUED IN STRICT CONFIDENCE & SHALL NOT BE MADE AVAILABLE, REPRODUCED, COPIED, USED FOR ANY OTHER INTENDED PURPOSES, OR AS BASIS FOR MANUFACTURE OR SALE OF APPARATUS WITHOUT WRITTEN PERMISSION. COPYRIGHT © 2025; LEVEL 5 ARCHITECTURE

THESE DOCUMENTS ARE

FOR REVIEW ONLY AND

ARE NOT INTENDED FOR BIDDING, PERMITTING OR

CONSTRUCTION PURPOSES


TERRELL, TX 75160 214.675.4435 TERRELL, TX 75160 214.675.4435

Director of Planning and Zoning

APPROVED:
I hereby certify that the above and foregoing site plan for a development in the City of Rockwall, Texas, was approved by the Planning & Zoning Commission of the City of Rockwall on the _____ day of _____,2025.


WITNESS OUR HANDS, this ____ day of _____, 2025.

Planning & Zoning Commission, Chairman

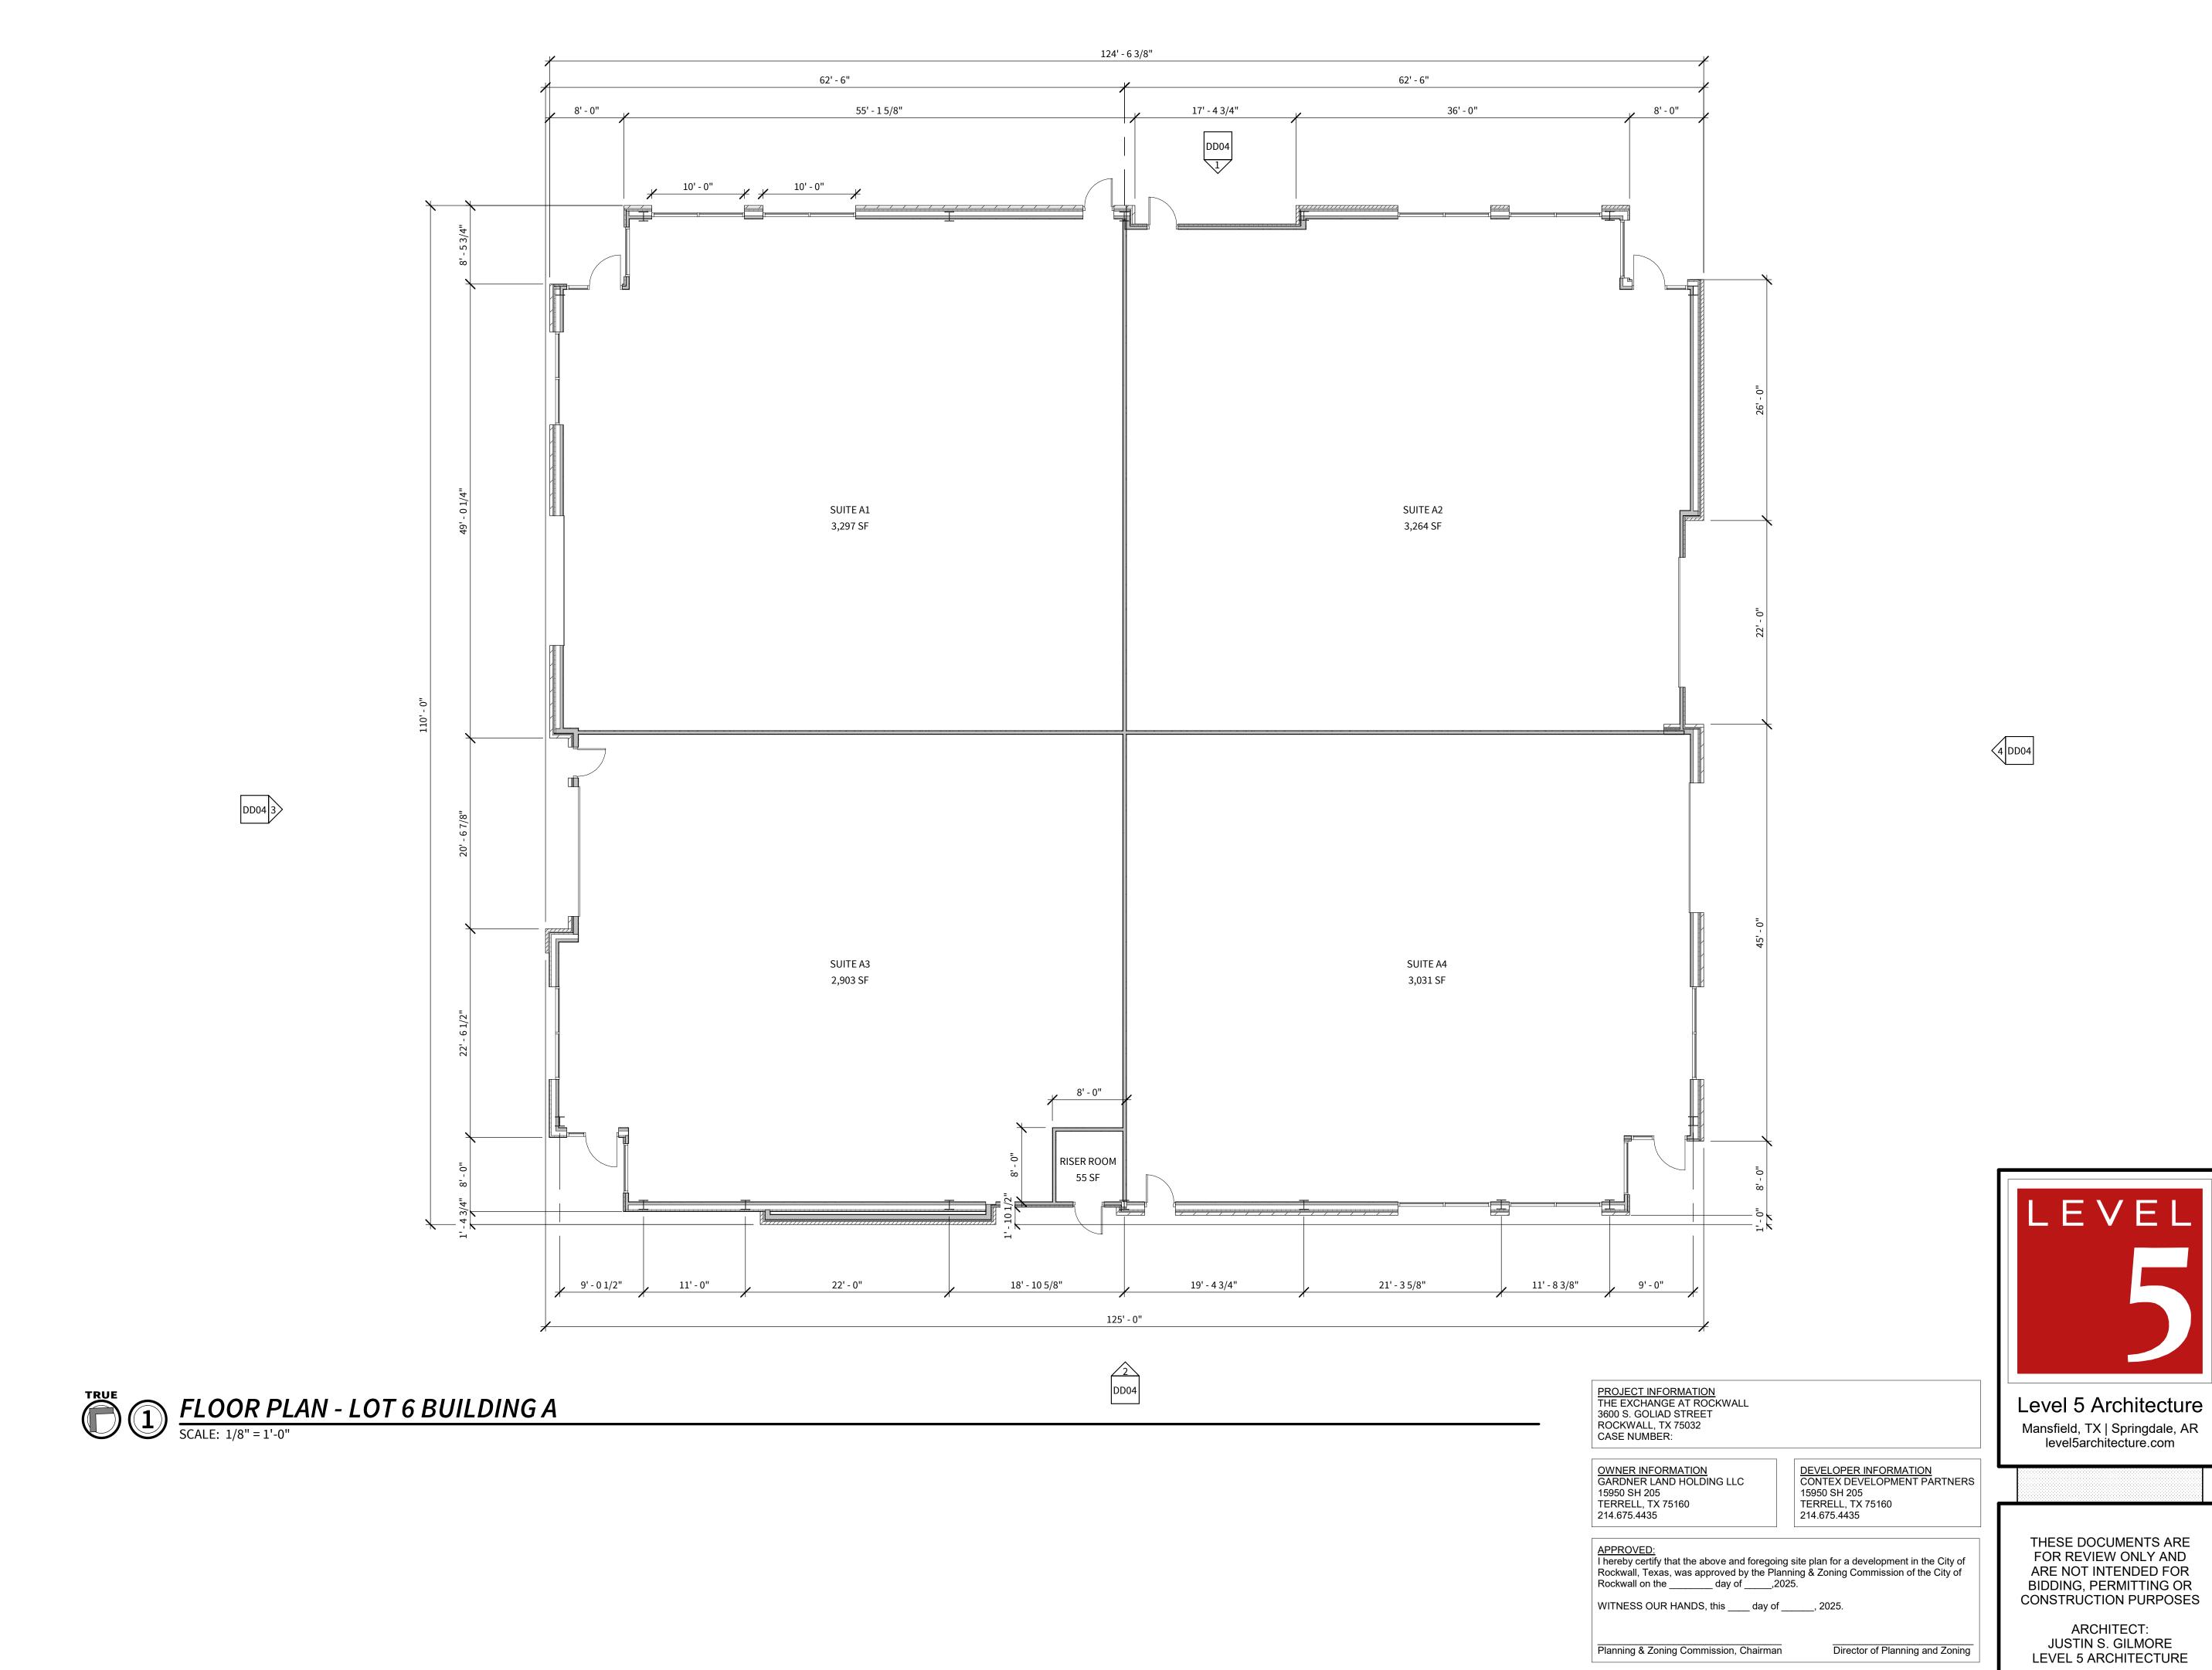


10/17/2023 10:03:22 AIM

COPYRIGHT © 2024; LEVEL 5 ARCHITECTURE. EXCEPT AS MAY BE OTHERWISE PROVIDED THESE DRAWINGS & SPECIFICATIONS ARE PROPERTY OF THE ARCHITECT AND ARE ISSUED IN STRICT CONFIDENCE & SHALL NOT BE MADE AVAILABLE, REPRODUCED, COPIED, USED FOR ANY OTHER INTENDED PURPOSES, OR AS BASIS FOR MANUFACTURE OR SALE OF APPARATUS WITHOUT WRITTEN PERMISSION. COPYRIGHT © 2025; LEVEL 5 ARCHITECTURE

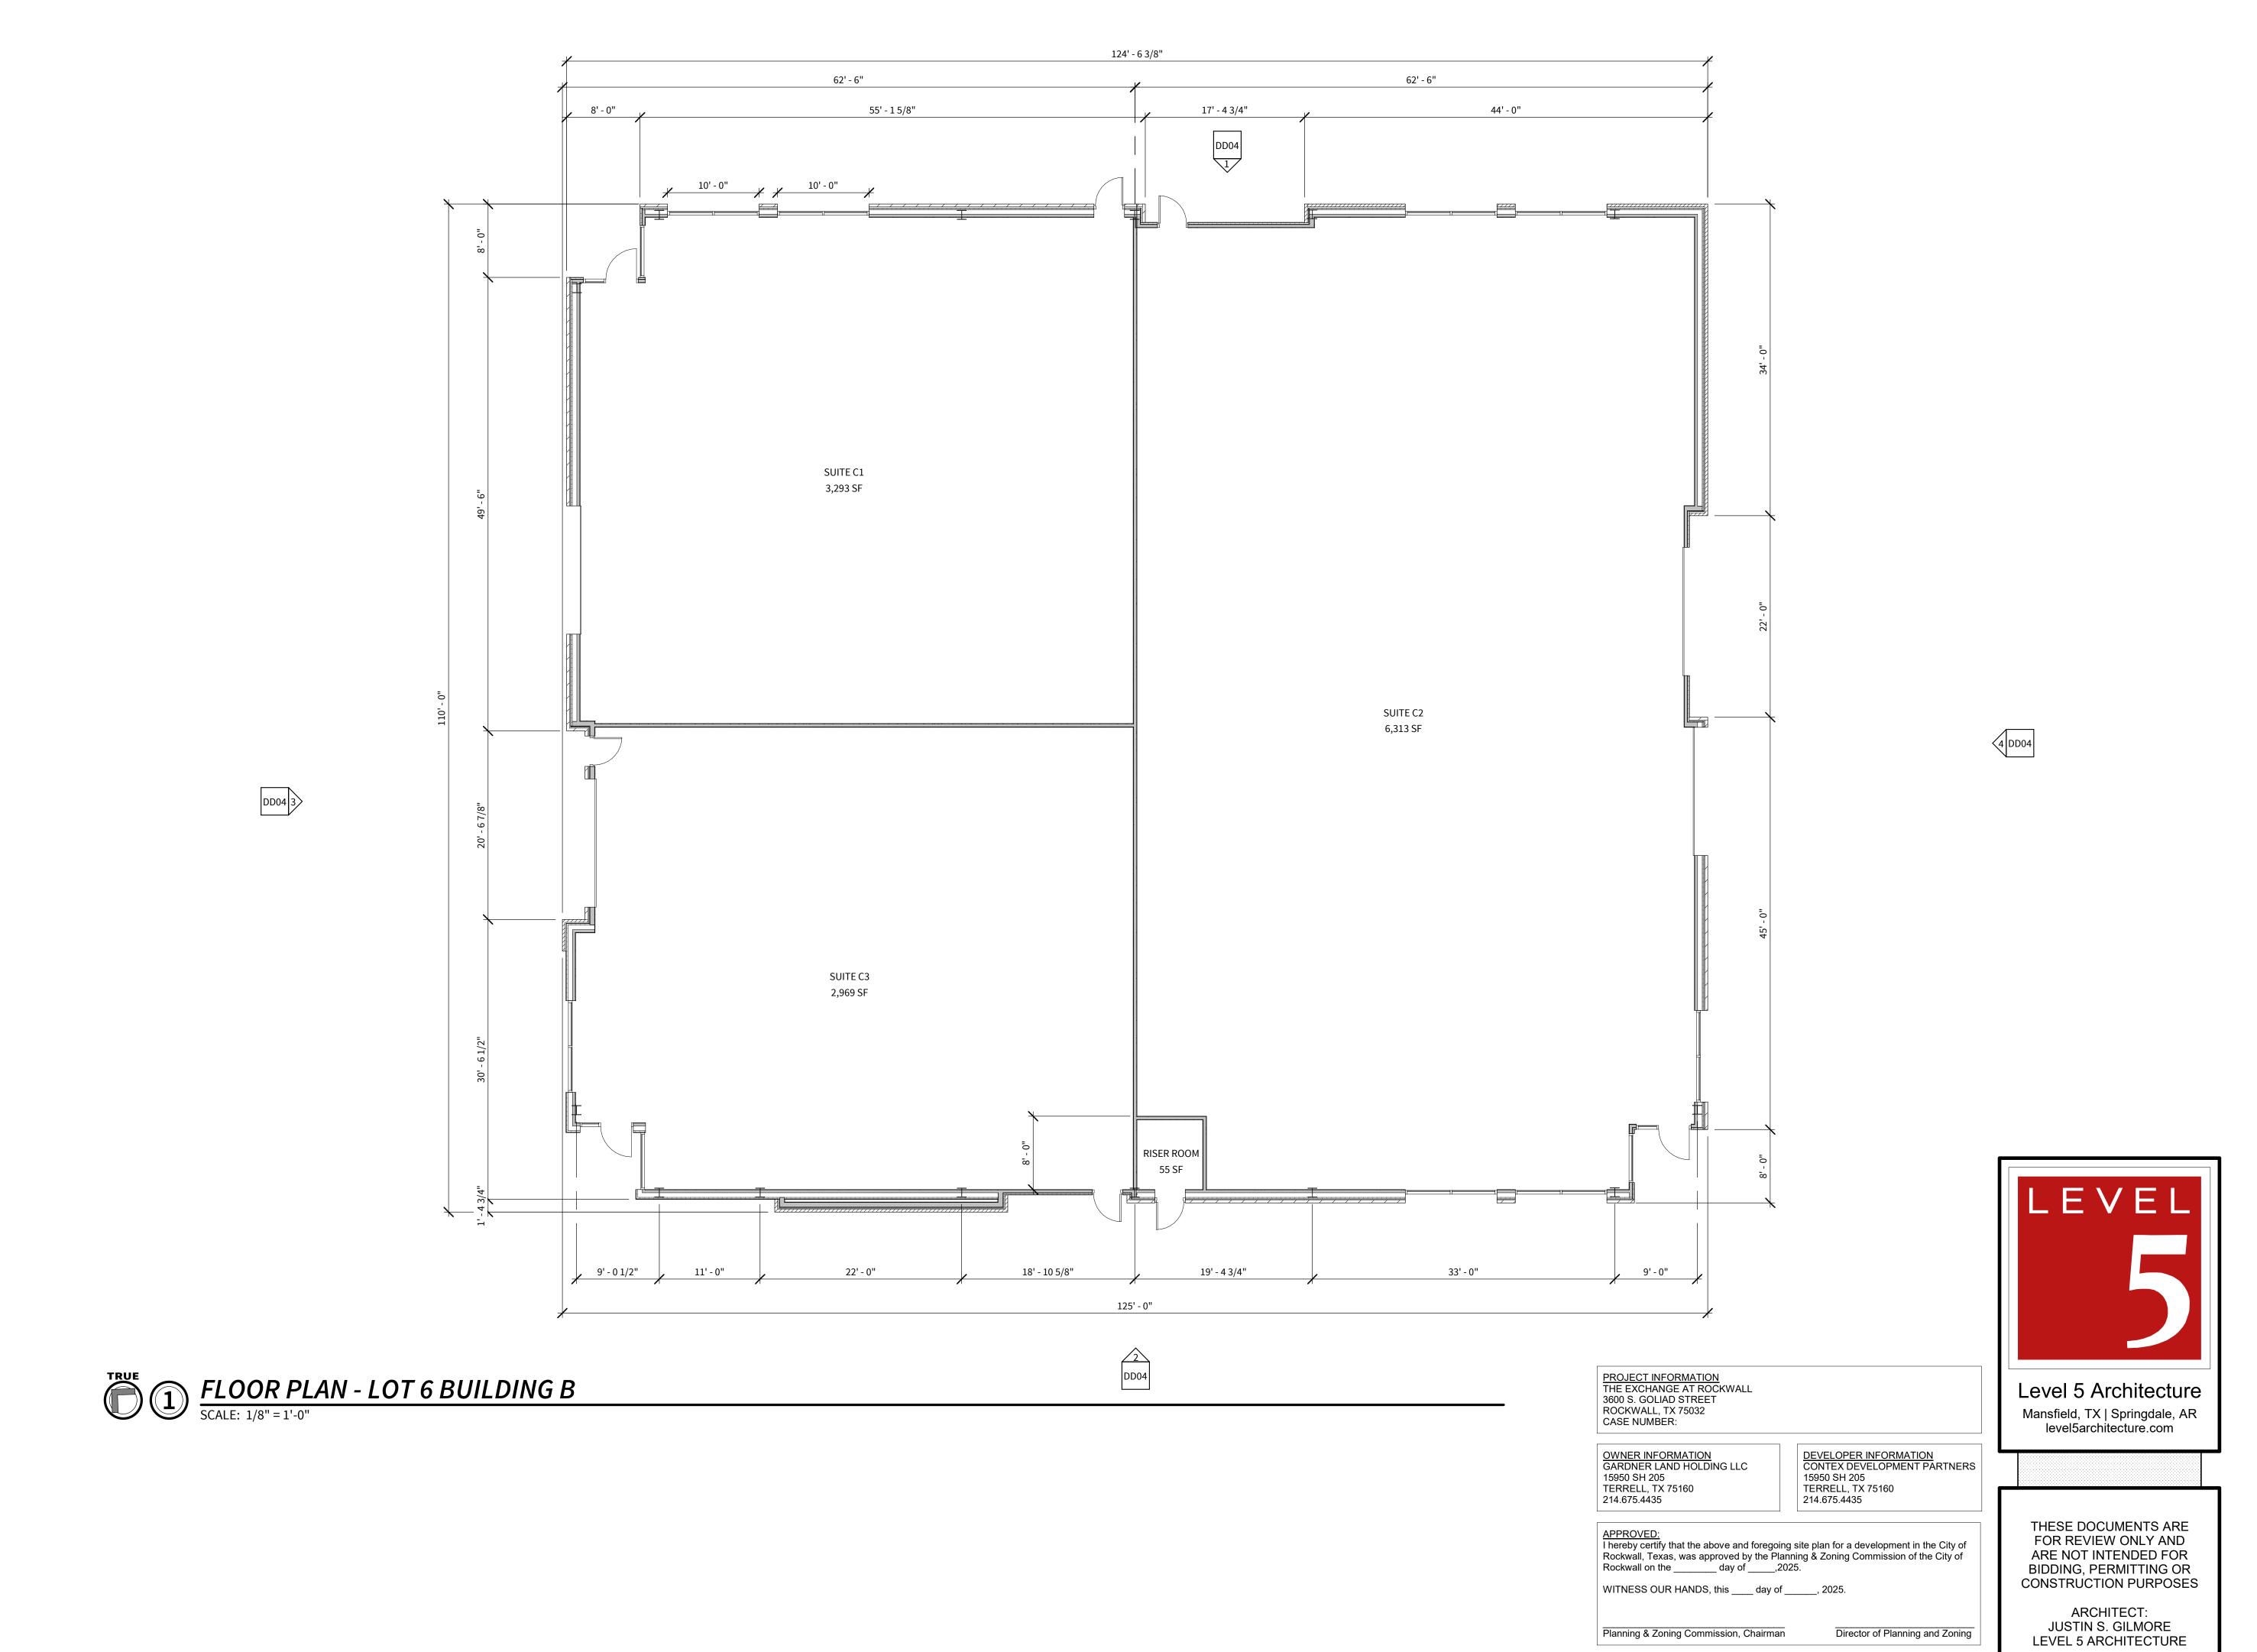


0/17/2025 10:11:32 AN

COPYRIGHT © 2024; LEVEL 5 ARCHITECTURE. EXCEPT AS MAY BE OTHERWISE PROVIDED THESE DRAWINGS & SPECIFICATIONS ARE PROPERTY OF THE ARCHITECT AND ARE ISSUED IN STRICT CONFIDENCE & SHALL NOT BE MADE AVAILABLE, REPRODUCED, COPIED, USED FOR ANY OTHER INTENDED PURPOSES, OR AS BASIS FOR MANUFACTURE OR SALE OF APPARATUS WITHOUT WRITTEN PERMISSION. COPYRIGHT © 2025; LEVEL 5 ARCHITECTURE

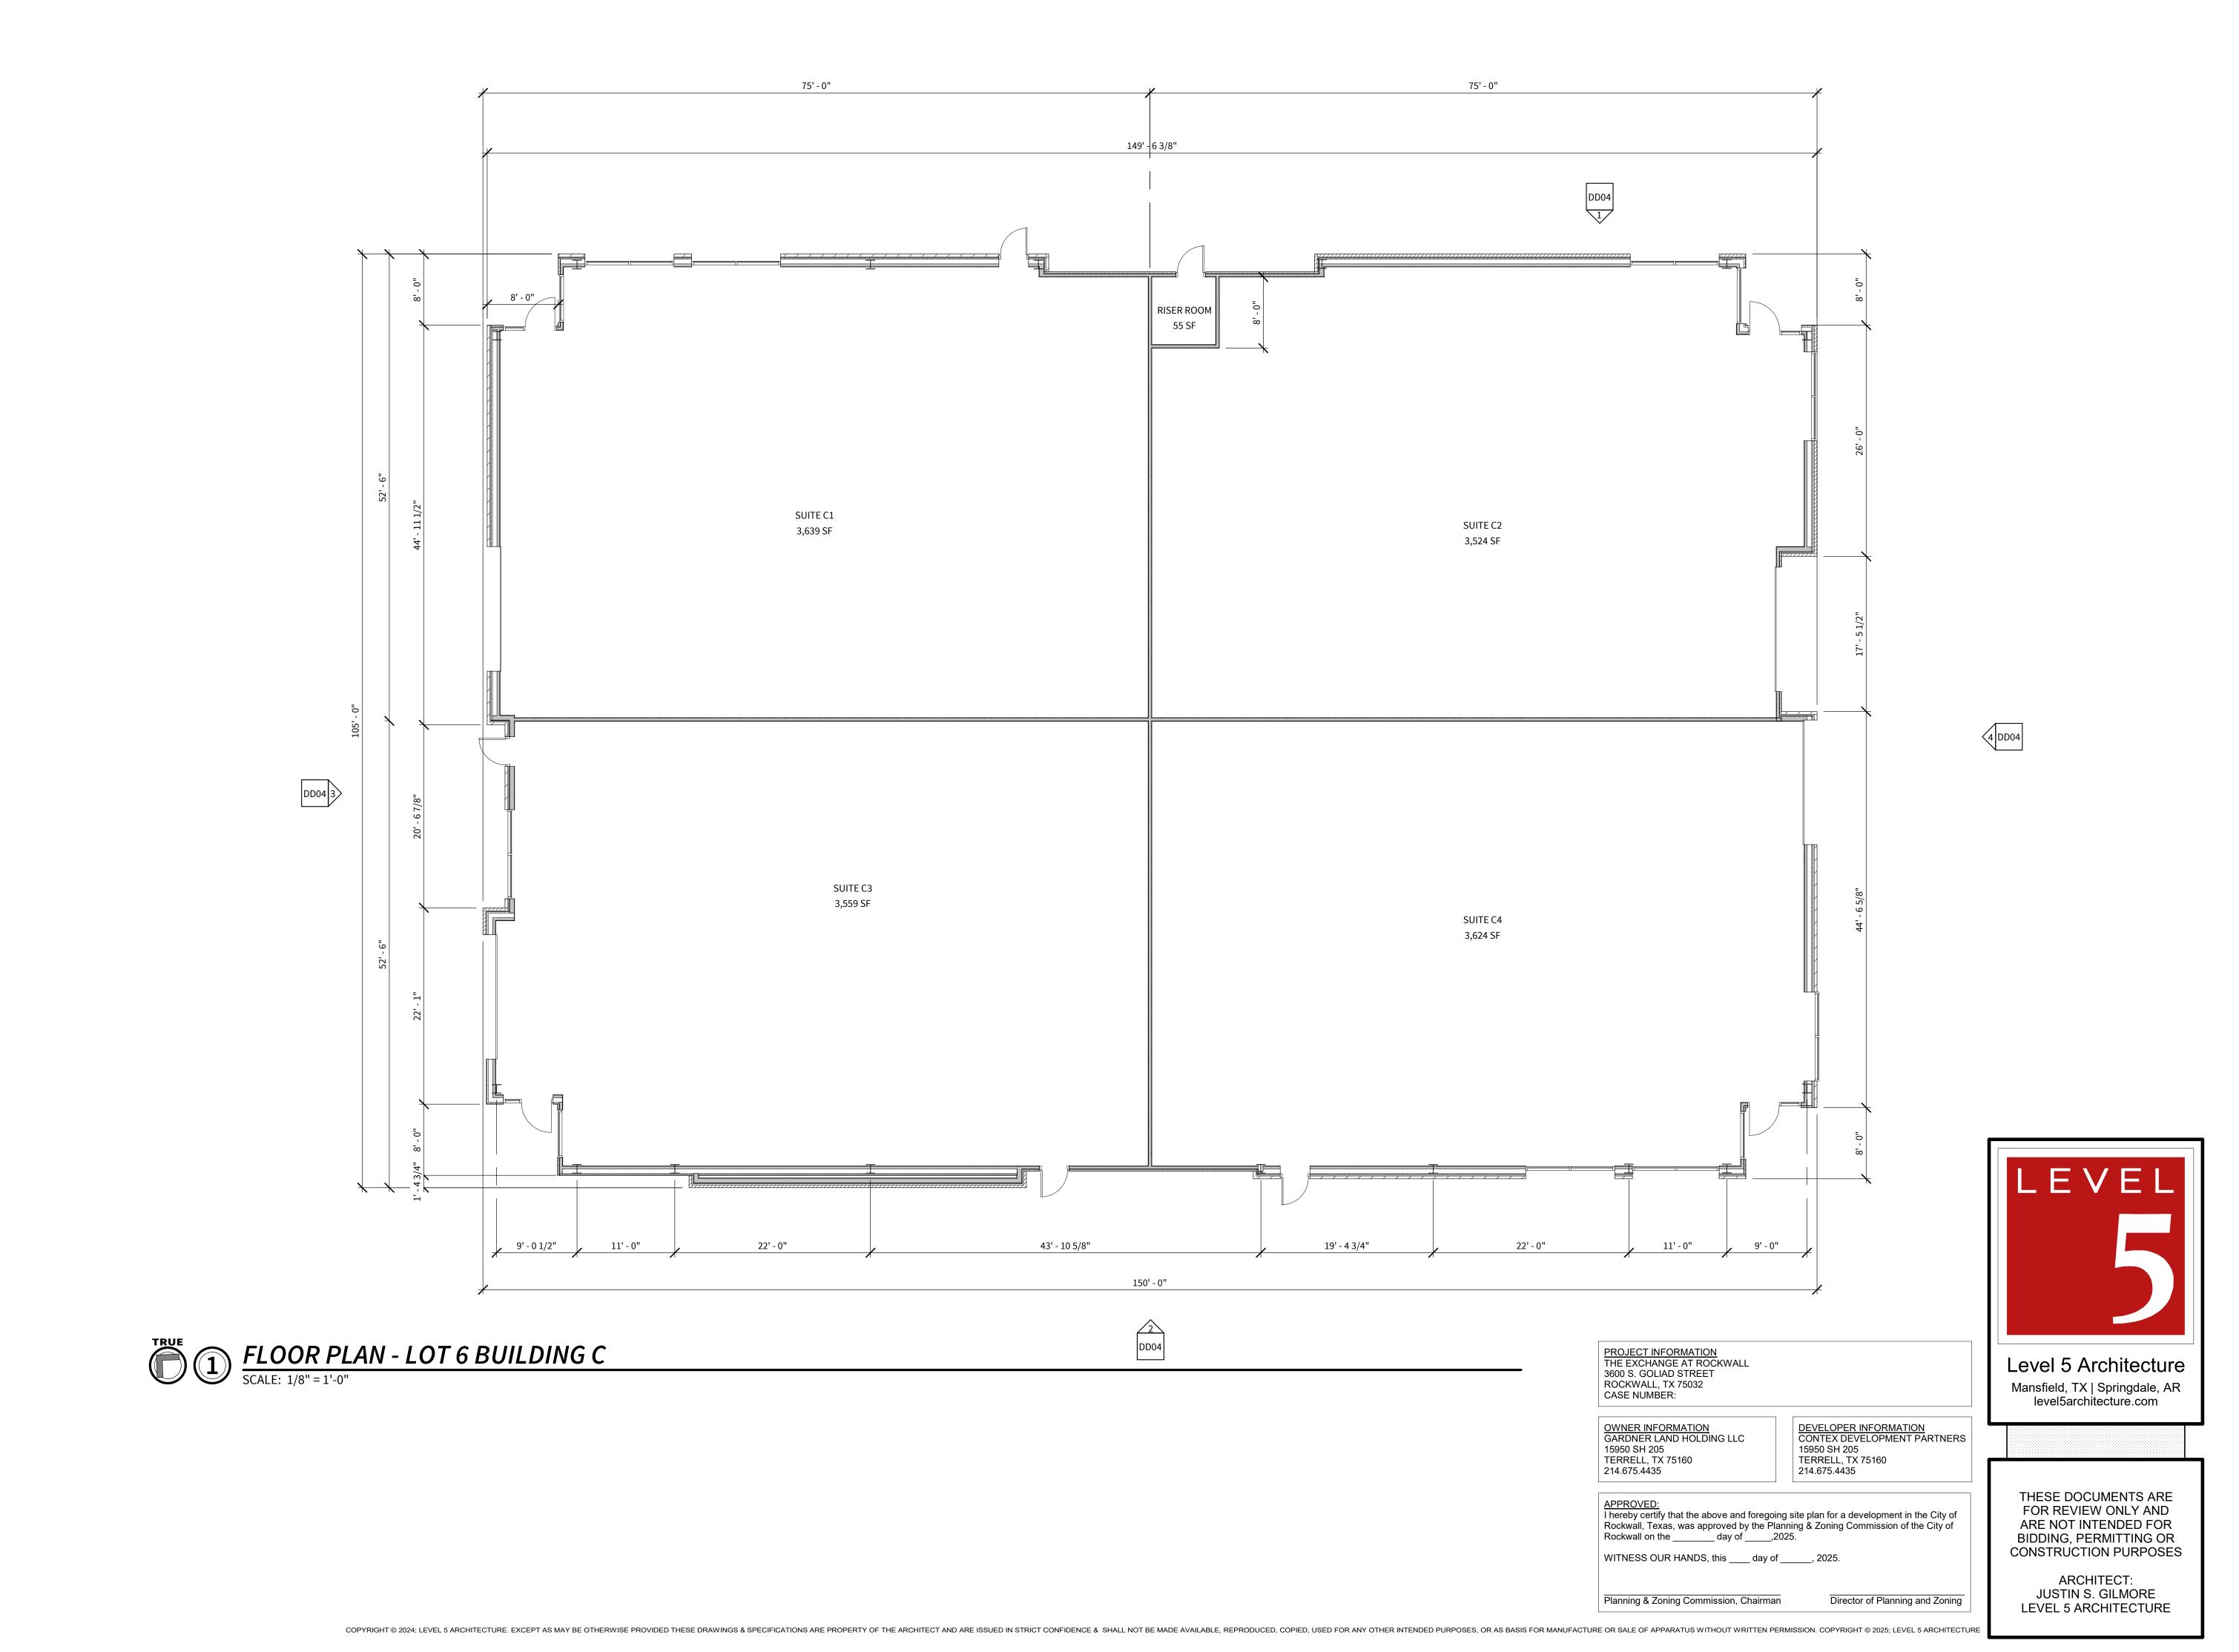


10/17/2025 10:14:45 AM

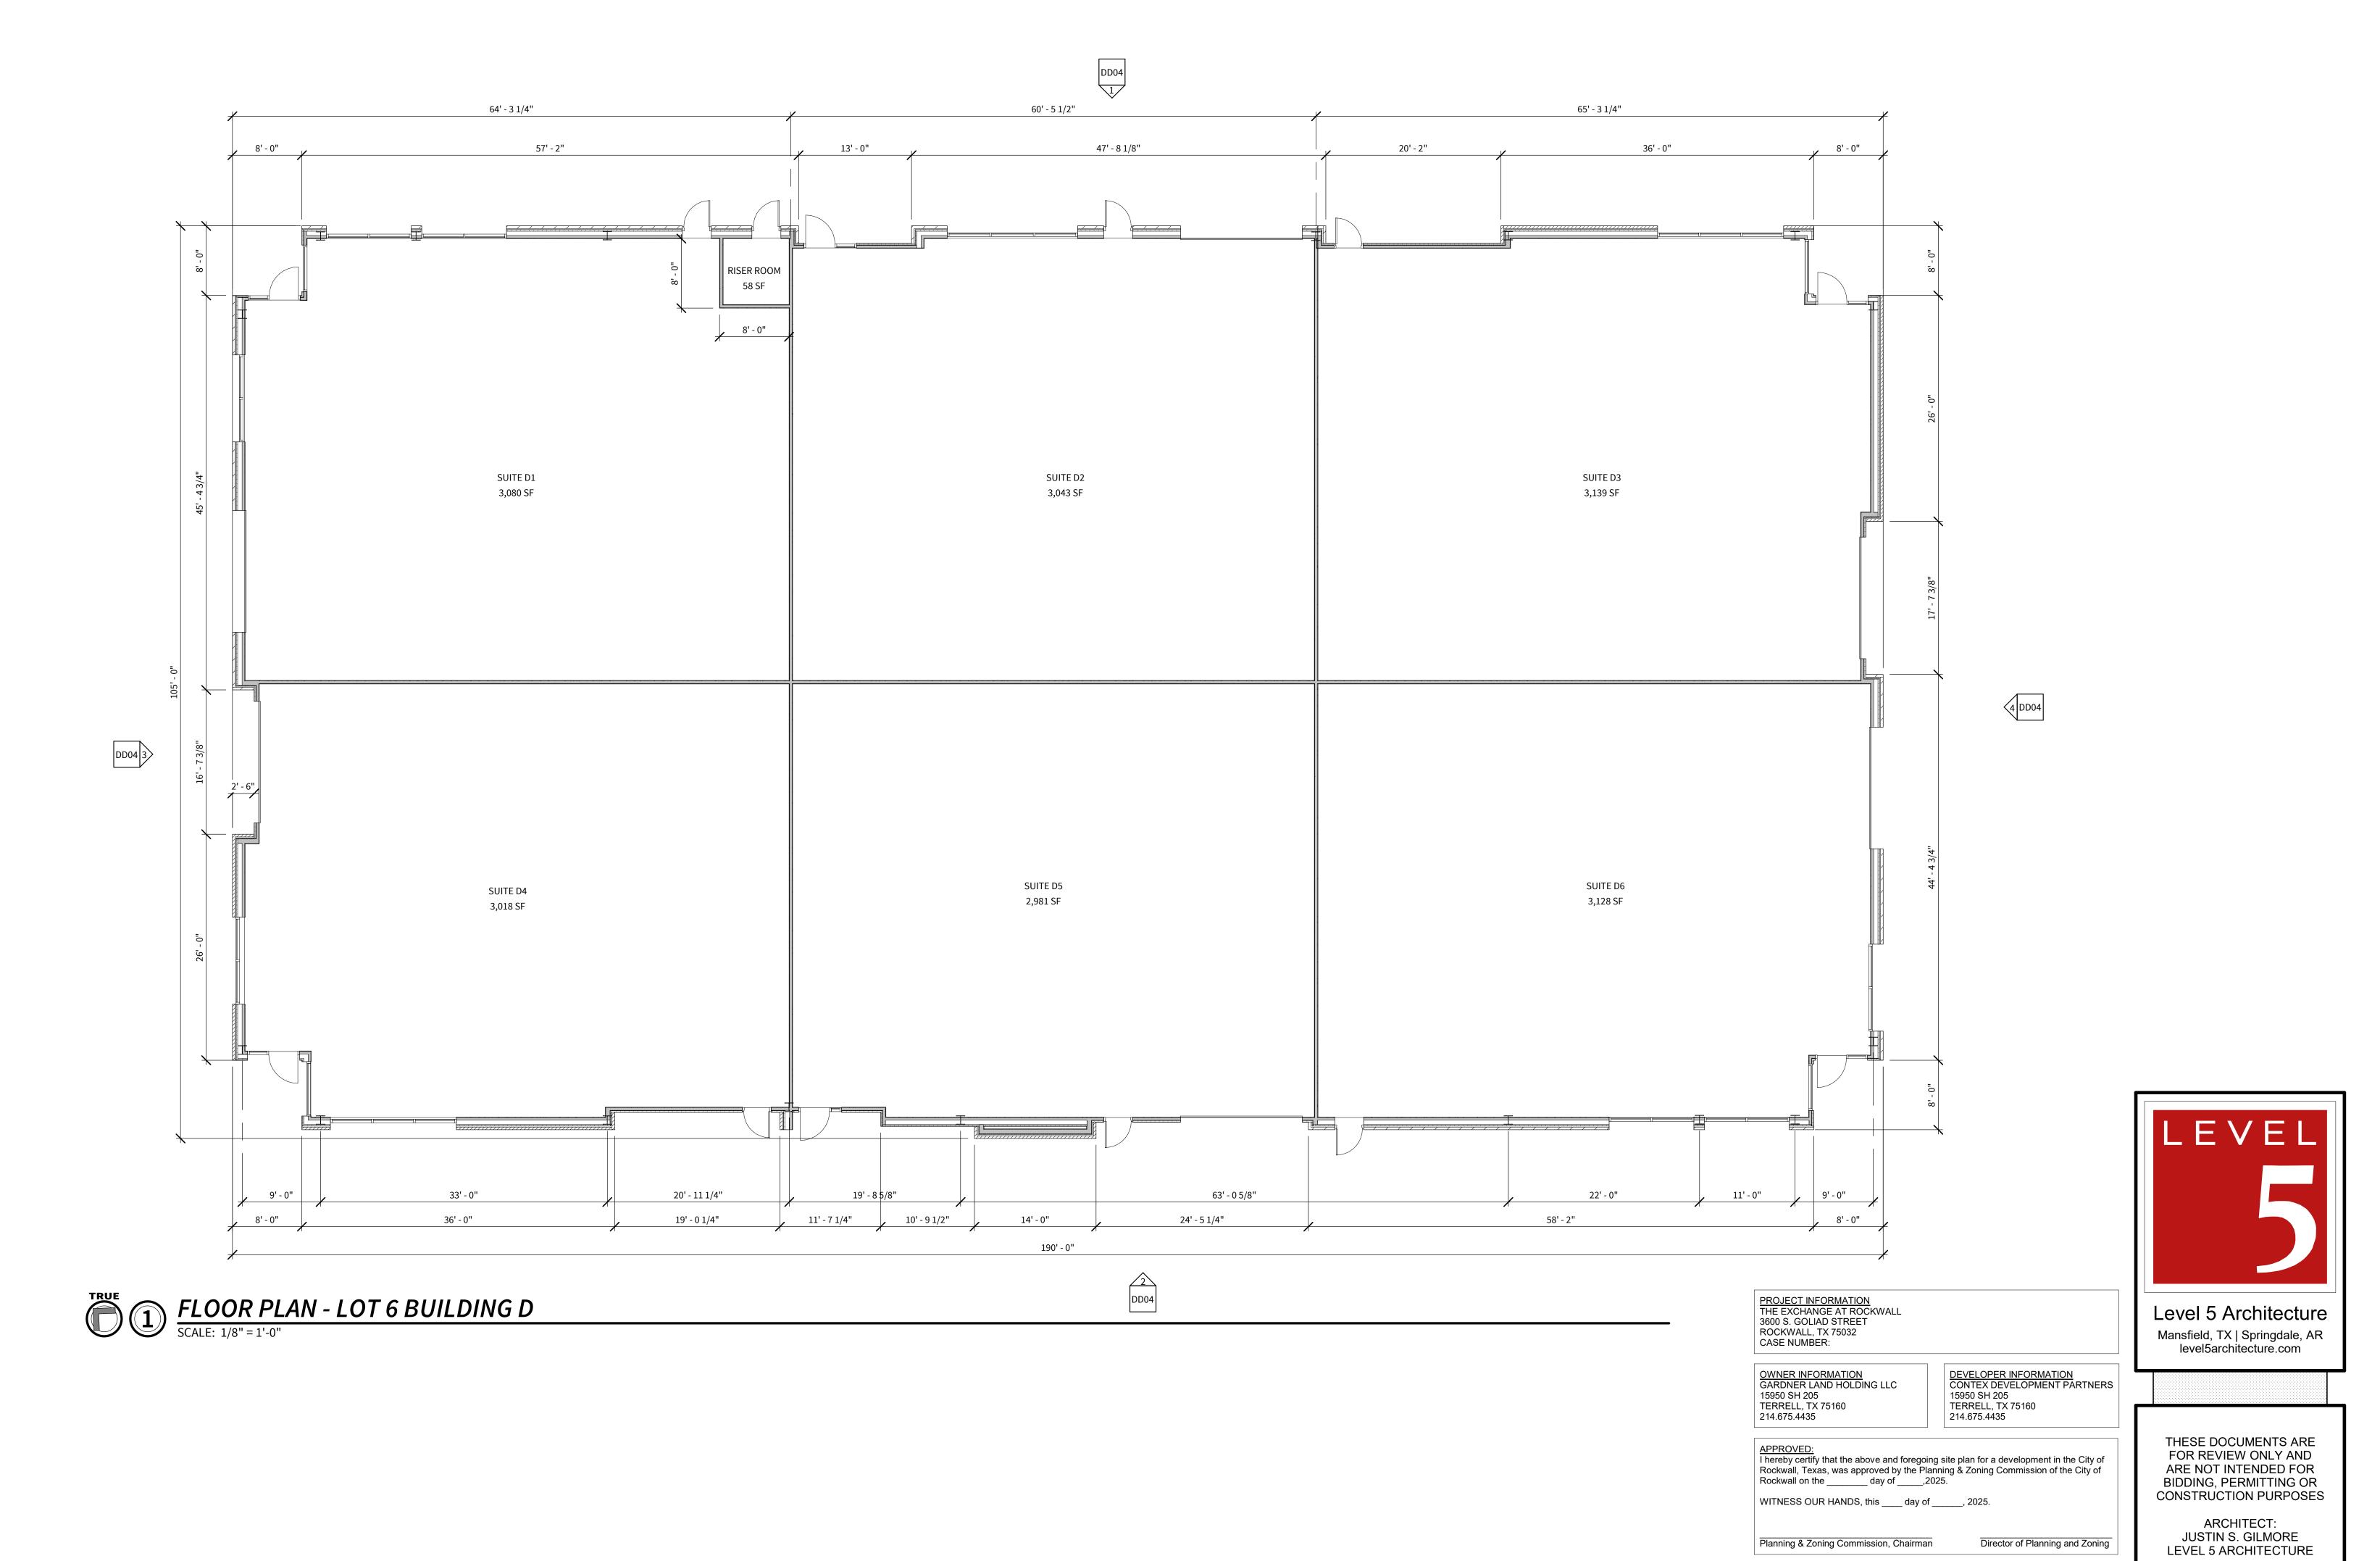

U/17/2025 10:22:25 AN

COPYRIGHT © 2024; LEVEL 5 ARCHITECTURE. EXCEPT AS MAY BE OTHERWISE PROVIDED THESE DRAWINGS & SPECIFICATIONS ARE PROPERTY OF THE ARCHITECT AND ARE ISSUED IN STRICT CONFIDENCE & SHALL NOT BE MADE AVAILABLE, REPRODUCED, COPIED, USED FOR ANY OTHER INTENDED PURPOSES, OR AS BASIS FOR MANUFACTURE OR SALE OF APPARATUS WITHOUT WRITTEN PERMISSION. COPYRIGHT © 2025; LEVEL 5 ARCHITECTURE

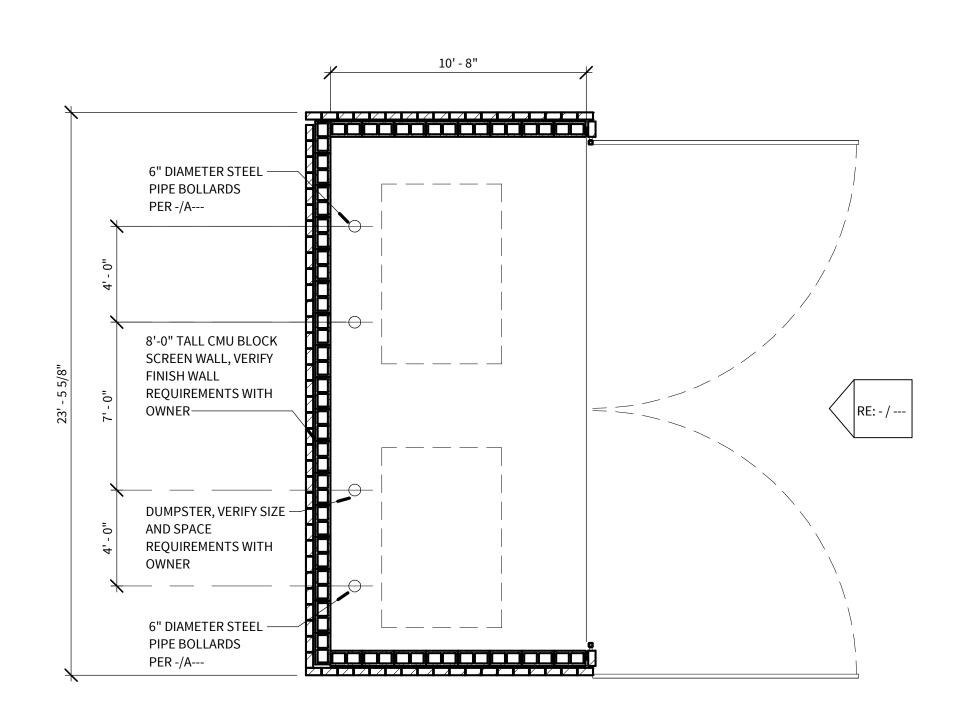

DUMPSTER ENCLOSURE ENLARGED PLAN SCALE: 1/4" = 1'-0"

WALL FINISH OVER 8" CMU
SELECTED BY OWNER


4X4X3/18" TUBE STEEL

FRAME AND CROSS
BRACING BEHIND WOOD

1X6 CIDER WOOD GATE TO
ENCLOSE DUMPSTER, STAIN
SELECTED BY OWNER

1 PR. STANLEY #1010-18 CANE
BOLTS WITH STEEL SLEEVES
IN PAVEMENT, SHIM TO FACE
OF PANELS

DUMPMSTER ENCLOSURE GATE ELEVATION SCALE: 1/4" = 1'-0"

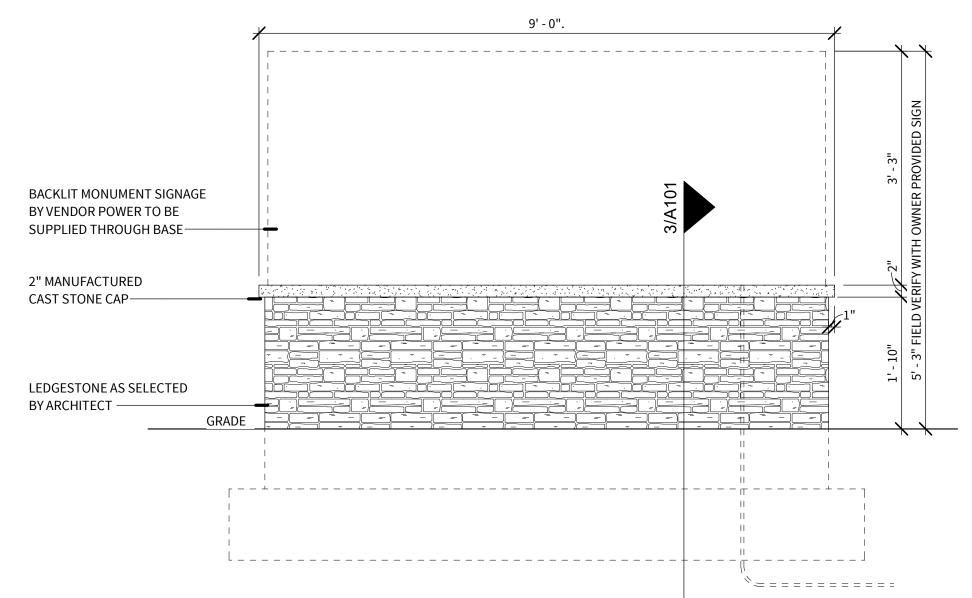

COPYRIGHT © 2024; LEVEL 5 ARCHITECTURE. EXCEPT AS MAY BE OTHERWISE PROVIDED THESE DRAWINGS & SPECIFICATIONS ARE PROPERTY OF THE ARCHITECT AND ARE ISSUED IN STRICT CONFIDENCE & SHALL NOT BE MADE AVAILABLE, REPRODUCED, COPIED, USED FOR ANY OTHER INTENDED PURPOSES, OR AS BASIS FOR MANUFACTURE OR SALE OF APPARATUS WITHOUT WRITTEN PERMISSION. COPYRIGHT © 2025; LEVEL 5 ARCHITECTURE

MONUMENT SINAGE ELEVATION

SCALE: 3/4" = 1'-0"

1'-10" 3'5'-3" FIELD VERIFY WITH OWNER PRO'
LI 50

PROJECT INFORMATION
THE EXCHANGE AT ROCKWALL
3600 S. GOLIAD STREET
ROCKWALL, TX 75032
CASE NUMBER:

OWNER INFORMATION
GARDNER LAND HOLDING LLC
15950 SH 205
TERRELL, TX 75160
214.675.4435

DEVELOPER INFORMATION
CONTEX DEVELOPMENT PARTNERS
15950 SH 205
TERRELL, TX 75160
214.675.4435

APPROVED:
I hereby certify that the above and foregoing site plan for a development in the City of Rockwall, Texas, was approved by the Planning & Zoning Commission of the City of Rockwall on the ______ day of _____,2025.

WITNESS OUR HANDS, this ____ day of _____, 2025.

Director of Planning and Zoning


Planning & Zoning Commission, Chairman

Level 5 Architecture

Mansfield, TX | Springdale, AR level5architecture.com

THESE DOCUMENTS ARE FOR REVIEW ONLY AND ARE NOT INTENDED FOR BIDDING, PERMITTING OR CONSTRUCTION PURPOSES

ARCHITECT: JUSTIN S. GILMORE LEVEL 5 ARCHITECTURE

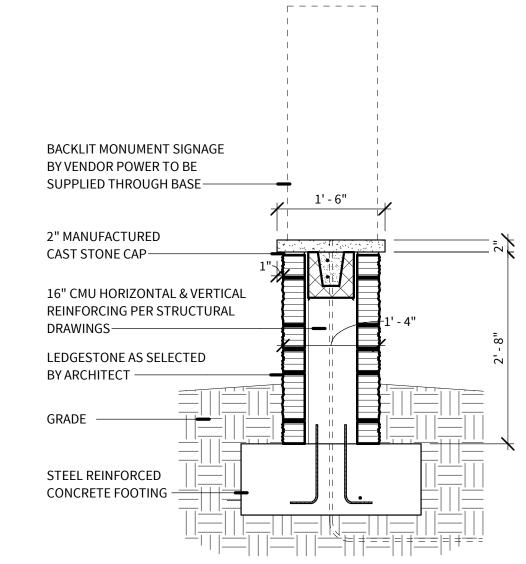

MONUMENT SINAGE SECTION